


CITY OF PHOENIX

AVIATION DEPARTMENT

DESIGN & CONSTRUCTION SERVICES



PROJECT NAME **PHOENIX GOODYEAR AIRPORT NEW APRON AND TAXIWAY CONNECTOR**
ADDRESS **1658 S LITCHFIELD RD, GOODYEAR, AZ 85338**
PROJECT NUMBER **AV41000077 FAA/ADOT**
FAA GRANT NUMBER
ADOT GRANT NUMBER

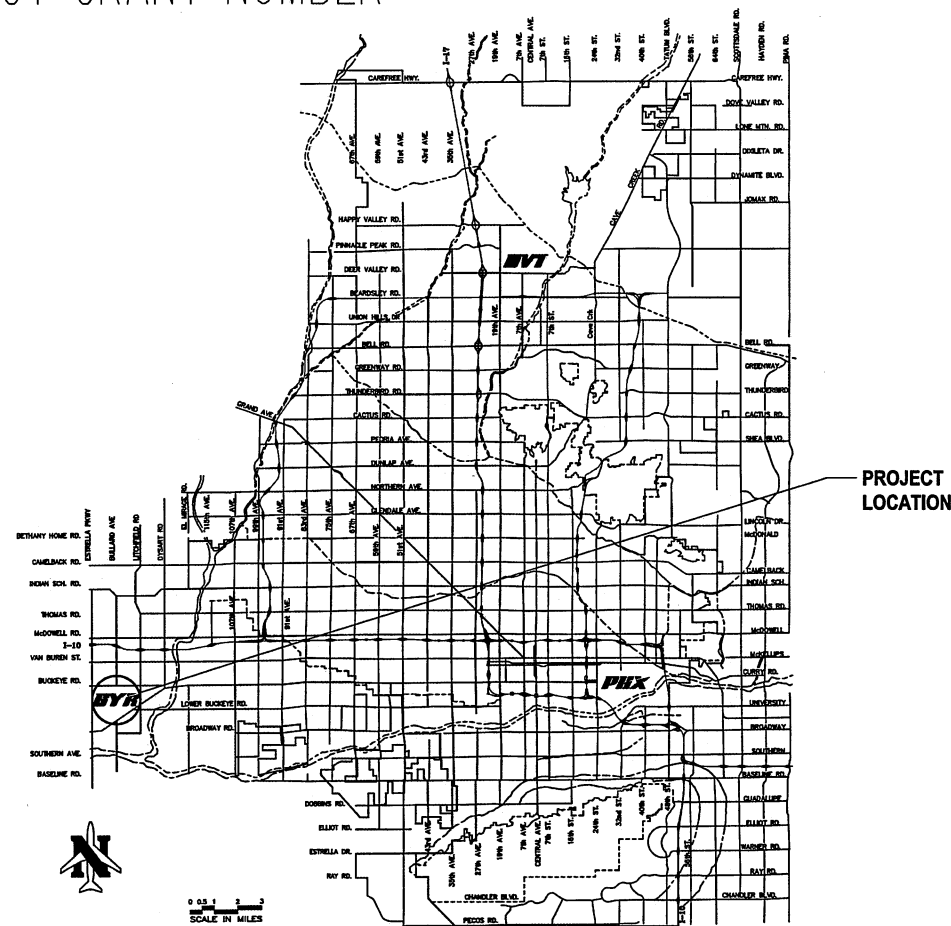

Vicinity Map

PER CITY OF PHOENIX CODE CHAPTER 2, SECTION 2-28. THESE PLANS ARE FOR OFFICIAL USE ONLY AND MAY NOT BE SHARED WITH OTHERS EXCEPT AS REQUIRED TO FULFILL THE OBLIGATIONS OF CONTRACTOR'S CONTRACT WITH THE CITY OF PHOENIX.

MAYOR
KATE GALLEG0

VICE MAYOR
CARLOS GARCIA

CITY COUNCIL

DISTRICT NO. 1 ANN O'BRIEN
DISTRICT NO. 2 JIM WARING
DISTRICT NO. 3 DEBRA STARK
DISTRICT NO. 4 LAURA PASTOR

DISTRICT NO. 5 BETTY GUARDADO
DISTRICT NO. 6 SAL DICICCIO
DISTRICT NO. 7 YASSAMIN ANSARI
DISTRICT NO. 8 CARLOS GARCIA

PHOENIX AVIATION ADVISORY BOARD

VALENCIA FISHER, CHAIR
SETH SCOTT, VICE CHAIR

RUBEN ALONZO
SETH SCOTT
ANDREW M. COHN
SANDRA FERNIZA
CAMILO HENAO, EX-OFFICIO

STEPHANIE FLEISCHMAN CHERNY
BRIAN J. FOSTER
RON PRICE
VALENCIA FISHER
VERMA PASTOR

CITY MANAGER

CITY ENGINEER

DIRECTOR OF AVIATION SERVICES

APPROVALS

Cum 48
DEPUTY AVIATION DIRECTOR
DESIGN & CONSTRUCTION SERVICES DIVISION

Ego J. Flores
CITY ENGINEER

JEFF BARTON

ERIC J. FROBERG, P.E.

CHAD R. MAKOVSKY, C.M.

02.07.2023
DATE

02/07/2023
DATE



G001

Sheet 1 of 61 Sheets

PHOENIX GOODYEAR AIRPORT NEW APRON AND TAXIWAY CONNECTOR

PHX DVT CYH
CITY OF PHOENIX AVIATION DEPARTMENT

SHEET NO.		REFERENCE NO.	TITLE
1	G-001	TITLE SHEET	
2	G-002	SHEET INDEX AND APPROXIMATE QUANTITIES	
3	G-003	ABBREVIATIONS AND LEGEND	
4	G-004	GENERAL NOTES	
5	V-101	GENERAL PLAN AND SURVEY CONTROL	
6	GC-101	CONSTRUCTION SAFETY AND PHASING PLAN	
7	GC-102	CONSTRUCTION SAFETY AND PHASING PLAN	
8	GC-201	EROSION CONTROL PLAN BASE BID	
9	GC-202	EROSION CONTROL PLAN BID ALT 1	
10	GC-203	EROSION CONTROL PLAN BID ALT 2	
11	GC-204	EROSION CONTROL PLAN BID ALT 3	
12	GC-205	EROSION CONTROL PLAN BID ALT 4	
13	CD-101	DEMOLITION PLAN BASE BID	
14	CD-102	DEMOLITION PLAN BID ALT 2	
15	CD-103	DEMOLITION PLAN BID ALT 3	
16	CD-104	DEMOLITION PLAN BID ALT 4	
17	CG-101	GEOMETRY PLAN BASE BID	
18	CG-102	GEOMETRY PLAN BID ALT 2	
19	CG-103	GEOMETRY PLAN BID ALT 3	
20	CG-104	GEOMETRY PLAN BID ALT 4	
21	CG-201	JOINT LAYOUT PLAN BASE BID	
22	CG-202	JOINT LAYOUT PLAN BID ALT 2	
23	CG-203	JOINT LAYOUT PLAN BID ALT 3	
24	CG-204	JOINT LAYOUT PLAN BID ALT 4	
25	CP-101	PAVING PLAN BASE BID	
26	CP-102	PAVING PLAN BASE BID	
27	CP-103	PAVING PLAN BID ALT 2	
28	CP-104	PAVING PLAN BID ALT 3	
29	CP-105	PAVING PLAN BID ALT 4	
30	CP-501	PAVING AND JOINT DETAILS	
31	CP-502	PAVING AND JOINT DETAILS	
32	CU-101	GRADING AND DRAINAGE PLAN BASE BID	
33	CU-102	GRADING AND DRAINAGE PLAN BID ALT 1	
34	CU-103	GRADING AND DRAINAGE PLAN BID ALT 2	
35	CU-104	GRADING AND DRAINAGE PLAN BID ALT 3	
36	CU-105	GRADING AND DRAINAGE PLAN BID ALT 4	
37	CU-106	GRADING AND DRAINAGE DETAILS	
38	CU-107	GRADING AND DRAINAGE DETAILS	
39	CM-101	MARKING PLAN BASE BID	
40	CM-102	MARKING PLAN BID ALT 2	
41	CM-103	MARKING PLAN BID ALT 3	
42	CM-104	MARKING PLAN BID ALT 4	
43	CM-501	MARKING DETAILS	
44	E-101	ELECTRICAL LEGEND AND NOTES	
45	E-102	ELECTRICAL NOTES	
46	ED-101	AIRFIELD ELECTRICAL DEMOLITION SITE PLAN	
47	EA-101	AIRFIELD ELECTRICAL INSTALLATION PLAN	
48	EA-102	AIRFIELD ELECTRICAL INSTALLATION PLAN	
49	EA-103	AIRFIELD ELECTRICAL INSTALLATION PLAN	
50	EA-104	AIRFIELD ELECTRICAL INSTALLATION PLAN	
51	EA-401	APRON LIGHT PHOTOMETRICS (BASE BID)	
52	EA-501	ELECTRICAL DUCTBANK DETAILS	
53	EA-502	GROUNDING DETAILS	
54	EA-503	HANDHOLD DETAILS	
55	EA-504	2' X 2' X 3' HANDHOLE AND JUNCTION BOX DETAILS	
56	EA-505	ELEVATED TAXIWAY EDGE LIGHT AND APRON LIGHT DETAILS	
57	EA-506	AIRFIELD GUIDANCE SIGN BASE DETAILS	
58	EA-507	AIRFIELD GUIDANCE SIGN DETAILS	
59	EA-601	SIGN SCHEDULE AND EQUIPMENT DATA TABLES	
60	EA-602	SINGLE LINE DIAGRAM AND LOAD CALCULATIONS	
61	EA-603	PANEL SCHEDULE AND LIGHTING CONTROL SCHEMATIC	

BASE BID			
1	C-100	CONTRACTOR QUALITY CONTROL PLAN (CQCP)	1 LS
2	C-102	TEMPORARY POLLUTION, EROSION, AND SILTATION CONTROL	1 LS
3	C-105	MOBILIZATION	1 LS
4	C-106	SAFETY, SECURITY AND MAINTENANCE OF TRAFFIC	1 LS
5	P-101-5.1	COLD MILLING	3640 SY
6	P-101-5.2	CONCRETE PAVEMENT REMOVAL	3760 SY
7	P-152-4.1	UNCLASSIFIED EXCAVATION	745 CY
8	P-152-4.2	REMOVAL AND REPLACEMENT OF UNSUITABLE MATERIAL (ALLOWANCES)	1 FA
9	P-154-5.1	6" THICK SUBBASE COURSE	11085 SY
10	P-209-5.1	12" CRUSHED AGGREGATE BASE COURSE	1745 CY
11	P-209-5.2	16" CRUSHED AGGREGATE BASE COURSE	25 CY
12	P-304-8.1	6" THICK CEMENT-TREATED BASE COURSE	11085 SY
13	P-401-8.1	4" THICK BITUMINOUS SURFACE COURSE	1215 TON
14	P-401-8.2	9" THICK BITUMINOUS SURFACE COURSE	30 TON
15	P-501-8.1	17" PORTLAND CEMENT CONCRETE PAVEMENT	11085 SY
16	P-602-5.1	BITUMINOUS PRIME COAT	25 TON
17	P-620-5.1	TAXIWAY PAINTSTRIPING (YELLOW, REFLECTORIZED)	2470 SF
18	P-620-5.1	EXISTING PAVEMENT MARKING REMOVAL	260 SF
19	D-701-5.1	24" DIAMETER REINFORCED CONCRETE PIPE	380 LF
20	D-750-5.1	12" AIRCRAFT RATED TRENCH DRAIN	290 LF
21	D-751-5.1	AIRCRAFT RATED CATCH BASIN	1 EA
22	TSP-1	SOIL STERILANT	16310 SY
23	TSP-2	MISCELLANEOUS REMOVALS AND OTHER WORK	1 LS
24	TSP-3	ADJUST UTILITY BOX AND COVER TO GRADE	3 EA
25	TSP-4	EXISTING UTILITY RELOCATION (ALLOWANCES)	1 FA
26	TSP-5	RIP RAP (DS0-6", DEPTH=24")	70 CY
27	L-100-5.1	REMOVE AND SALVAGE FAA SWS EQUIPMENT FOR REINSTALLATION. DEMO	1 LS
28	L-100-5.2	TEMPORARY AIRFIELD LIGHTING CABLE JUMPERS	1 LS
29	L-100-5.3	REMOVE AND SALVAGE EXISTING EDGE LIGHT AND ISOLATION TRANSFORMER	1 EA
30	L-100-5.4	REMOVE, TEMPORARILY MOUNT AND POWER AIRFIELD GUIDANCE SIGN AND	1 EA
31	L-100-5.5	REINSTALL FAA SWS EQUIPMENT ON NEW FOUNDATION AND GROUNDING,	1 LS
32	L-100-5.6	REMOVE, RELOCATE, REPLACE CIRCUIT BREAKERS IN SWS SHELTER PANEL. AI	1 EA
33	L-108-5.1	L-824, TYPE C, 2/C #8 AWG, 5KV CABLE	2895 LF
34	L-108-5.2	3-4/0, 4/0 GND (SWS CIRCUIT)	4162 LF
35	L-110-5.1	SINGLE-WAY, (1) - 2" CONDUIT, SLURRY ENCASED	680 LF
36	L-110-5.2	MULTIPLE-WAY, (4) - 2" CONDUIT, SLURRY ENCASED	645 LF
37	L-110-5.3	MULTIPLE-WAY, (4) - 2" CONDUIT, CONCRETE ENCASED	105 LF
38	L-110-5.4	MULTIPLE-WAY, (5) - 2" CONDUIT, SLURRY ENCASED	3950 LF
39	L-110-5.5	MULTIPLE-WAY, (5) - 2" CONDUIT, CONCRETE ENCASED	325 LF
40	L-115-5.1	NEW HANDHOLE, PREFABRICATED CONCRETE 2'X3'X3' WITH AIRCRAFT RATED	10 EA
41	L-115-5.2	NEW PULLBOX, SIZE 5, (12"X24") FURNISHED AND INSTALLED WITH GRAVEL S	2 EA
42	L-125-5.1	NEW L-858(L) SIZE 2, 3-MODULE, AIRFIELD GUIDANCE SIGN, ON NEW SIGN BA	3 EA
43	L-125-5.2	NEW ELEVATED L-861(T)(L) LED TAXIWAY EDGE LIGHT AND ISOLATION TRANSFER	11 EA
44	L-125-5.3	INSTALL SALVAGED TAXIWAY EDGE LIGHT ON EXISTING BASE CAN	1 EA
45	L-125-5.4	INSTALL SALVAGED 3-MODULE AIRFIELD GUIDANCE SIGN ON NEW CONCRETE	1 EA
46	L-125-5.5	NEW ELEVATED L-861(T)(L) LED TAXIWAY EDGE LIGHT AND ISOLATION TRANSFER	1 EA

BID ALTERNATE 1			
1	C-100	CONTRACTOR QUALITY CONTROL PLAN (CQCP)	1 LS
2	C-102	TEMPORARY POLLUTION, EROSION, AND SILTATION CONTROL	1 LS
3	C-105	MOBILIZATION	1 LS
4	C-106	SAFETY, SECURITY AND MAINTENANCE OF TRAFFIC	1 LS
5	P-152-4.1	EMBANKMENT	18225 CY
6	P-152-4.2	REMOVAL AND REPLACEMENT OF UNSUITABLE MATERIAL (ALLOWANCES)	1 FA

BID ALTERNATE 2			
1	C-100	CONTRACTOR QUALITY CONTROL PLAN (CQCP)	1 LS
2	C-102	TEMPORARY POLLUTION, EROSION, AND SILTATION CONTROL	1 LS
3	C-105	MOBILIZATION	1 LS
4	C-106	SAFETY, SECURITY AND MAINTENANCE OF TRAFFIC	1 LS
5	P-101-5.1	COLD MILLING	670 SY
6	P-152-4.1	EMBANKMENT	435 CY
7	P-152-4.2	REMOVAL AND REPLACEMENT OF UNSUITABLE MATERIAL (ALLOWANCES)	1 FA
8	P-154-5.1	6" THICK SUBBASE COURSE	4690 SY
9	P-209-5.1	12" CRUSHED AGGREGATE BASE COURSE	770 CY
10	P-304-8.1	6" THICK CEMENT-TREATED BASE COURSE	4690 SY
11	P-401-8.1	4" THICK BITUMINOUS SURFACE COURSE	535 TON
12	P-501-8.1	17" PORTLAND CEMENT CONCRETE PAVEMENT	4690 SY
13	P-602-5.1	BITUMINOUS PRIME COAT	5 TON
14	P-620-5.1	TAXIWAY PAINTSTRIPING (YELLOW, REFLECTORIZED)	635 SF
15	TSP-1	SOIL STERILANT	6990 SY

BID ALTERNATE 3			
1	C-100	CONTRACTOR QUALITY CONTROL PLAN (CQCP)	1 LS
2	C-102	TEMPORARY POLLUTION, EROSION, AND SILTATION CONTROL	1 LS
3	C-105	MOBILIZATION	1 LS
4	C-106	SAFETY, SECURITY AND MAINTENANCE OF TRAFFIC	1 LS
5	P-101-5.1	COLD MILLING	830 SY
6	P-152-4.1	EMBANKMENT	610 CY
7	P-152-4.2	REMOVAL AND REPLACEMENT OF UNSUITABLE MATERIAL (ALLOWANCES)	1 FA
8	P-154-5.1	6" THICK SUBBASE COURSE	6800 SY
9	P-209-5.1	12" CRUSHED AGGREGATE BASE COURSE	810 CY
10	P-304-8.1	6" THICK CEMENT-TREATED BASE COURSE	6800 SY
11	P-401-8.1	4" THICK BITUMINOUS SURFACE COURSE	565 TON
12	P-501-8.1	17" PORTLAND CEMENT CONCRETE PAVEMENT	6800 SY
13	P-602-5.1	BITUMINOUS PRIME COAT	5 TON
14	P-620-5.1	TAXIWAY PAINTSTRIPING (YELLOW, REFLECTORIZED)	720 SF
15	P-620-5.1	EXISTING PAVEMENT MARKING REMOVAL	300 SF
16	TSP-1	SOIL STERILANT	9215 SY

BID ALTERNATE 4			
1	C-100	CONTRACTOR QUALITY CONTROL PLAN (CQCP)	1 LS
2	C-102	TEMPORARY POLLUTION, EROSION, AND SILTATION CONTROL	1 LS
3	C-105	MOBILIZATION	1 LS
4	C-106	SAFETY, SECURITY AND MAINTENANCE OF TRAFFIC	1 LS
5	P-101-5.1	COLD MILLING	435 SY
6	P-152-4.1	EMBANKMENT	3330 CY
7	P-152-4.2	REMOVAL AND REPLACEMENT OF UNSUITABLE MATERIAL (ALLOWANCES)	1 FA
8	P-154-5.1	6" THICK SUBBASE COURSE	3755 SY
9	P-209-5.1	12" CRUSHED AGGREGATE BASE COURSE	2320 CY
10	P-304-8.1	6" THICK CEMENT-TREATED BASE COURSE	3755 SY
11	P-401-8.1	4" THICK BITUMINOUS SURFACE COURSE	1620 TON
12	P-501-8.1	17" PORTLAND CEMENT CONCRETE PAVEMENT	3755 SY
13	P-602-5.1	BITUMINOUS PRIME COAT	15 TON
14	P-620-5.1	TAXIWAY PAINTSTRIPING (YELLOW, REFLECTORIZED)	1950 SF
15	P-620-5.1	EXISTING PAVEMENT MARKING REMOVAL	590 SF
16	TSP-1	SOIL STERILANT	10710 SY

PHX DOT CYR

CITY OF PHOENIX AVIATION DEPARTMENT

PHOENIX GOODYEAR AIRPORT

NEW APRON AND TAXIWAY CONNECTOR

AV41000077 FAA/ADOT

Designed by: LM

Drawn by: RB

Checked by: LM

Date: February 2023

Dwg scale: -----

Sheet Overview Title

SHEET INDEX AND APPROXIMATE QUANTITIES

Sheet Reference Number: G002

Sheet 2 of 61

A1

SHEET INDEX


NOT TO SCALE

A2

APPROXIMATE QUANTITIES

NOT TO SCALE

PER CITY OF PHOENIX CODE CHAPTER 2, SECTION 2-28, THESE PLANS ARE FOR OFFICIAL USE ONLY AND MAY NOT BE SHARED WITH OTHERS EXCEPT AS REQUIRED TO FULFILL THE OBLIGATIONS OF CONTRACTOR'S CONTRACT WITH THE CITY OF PHOENIX.

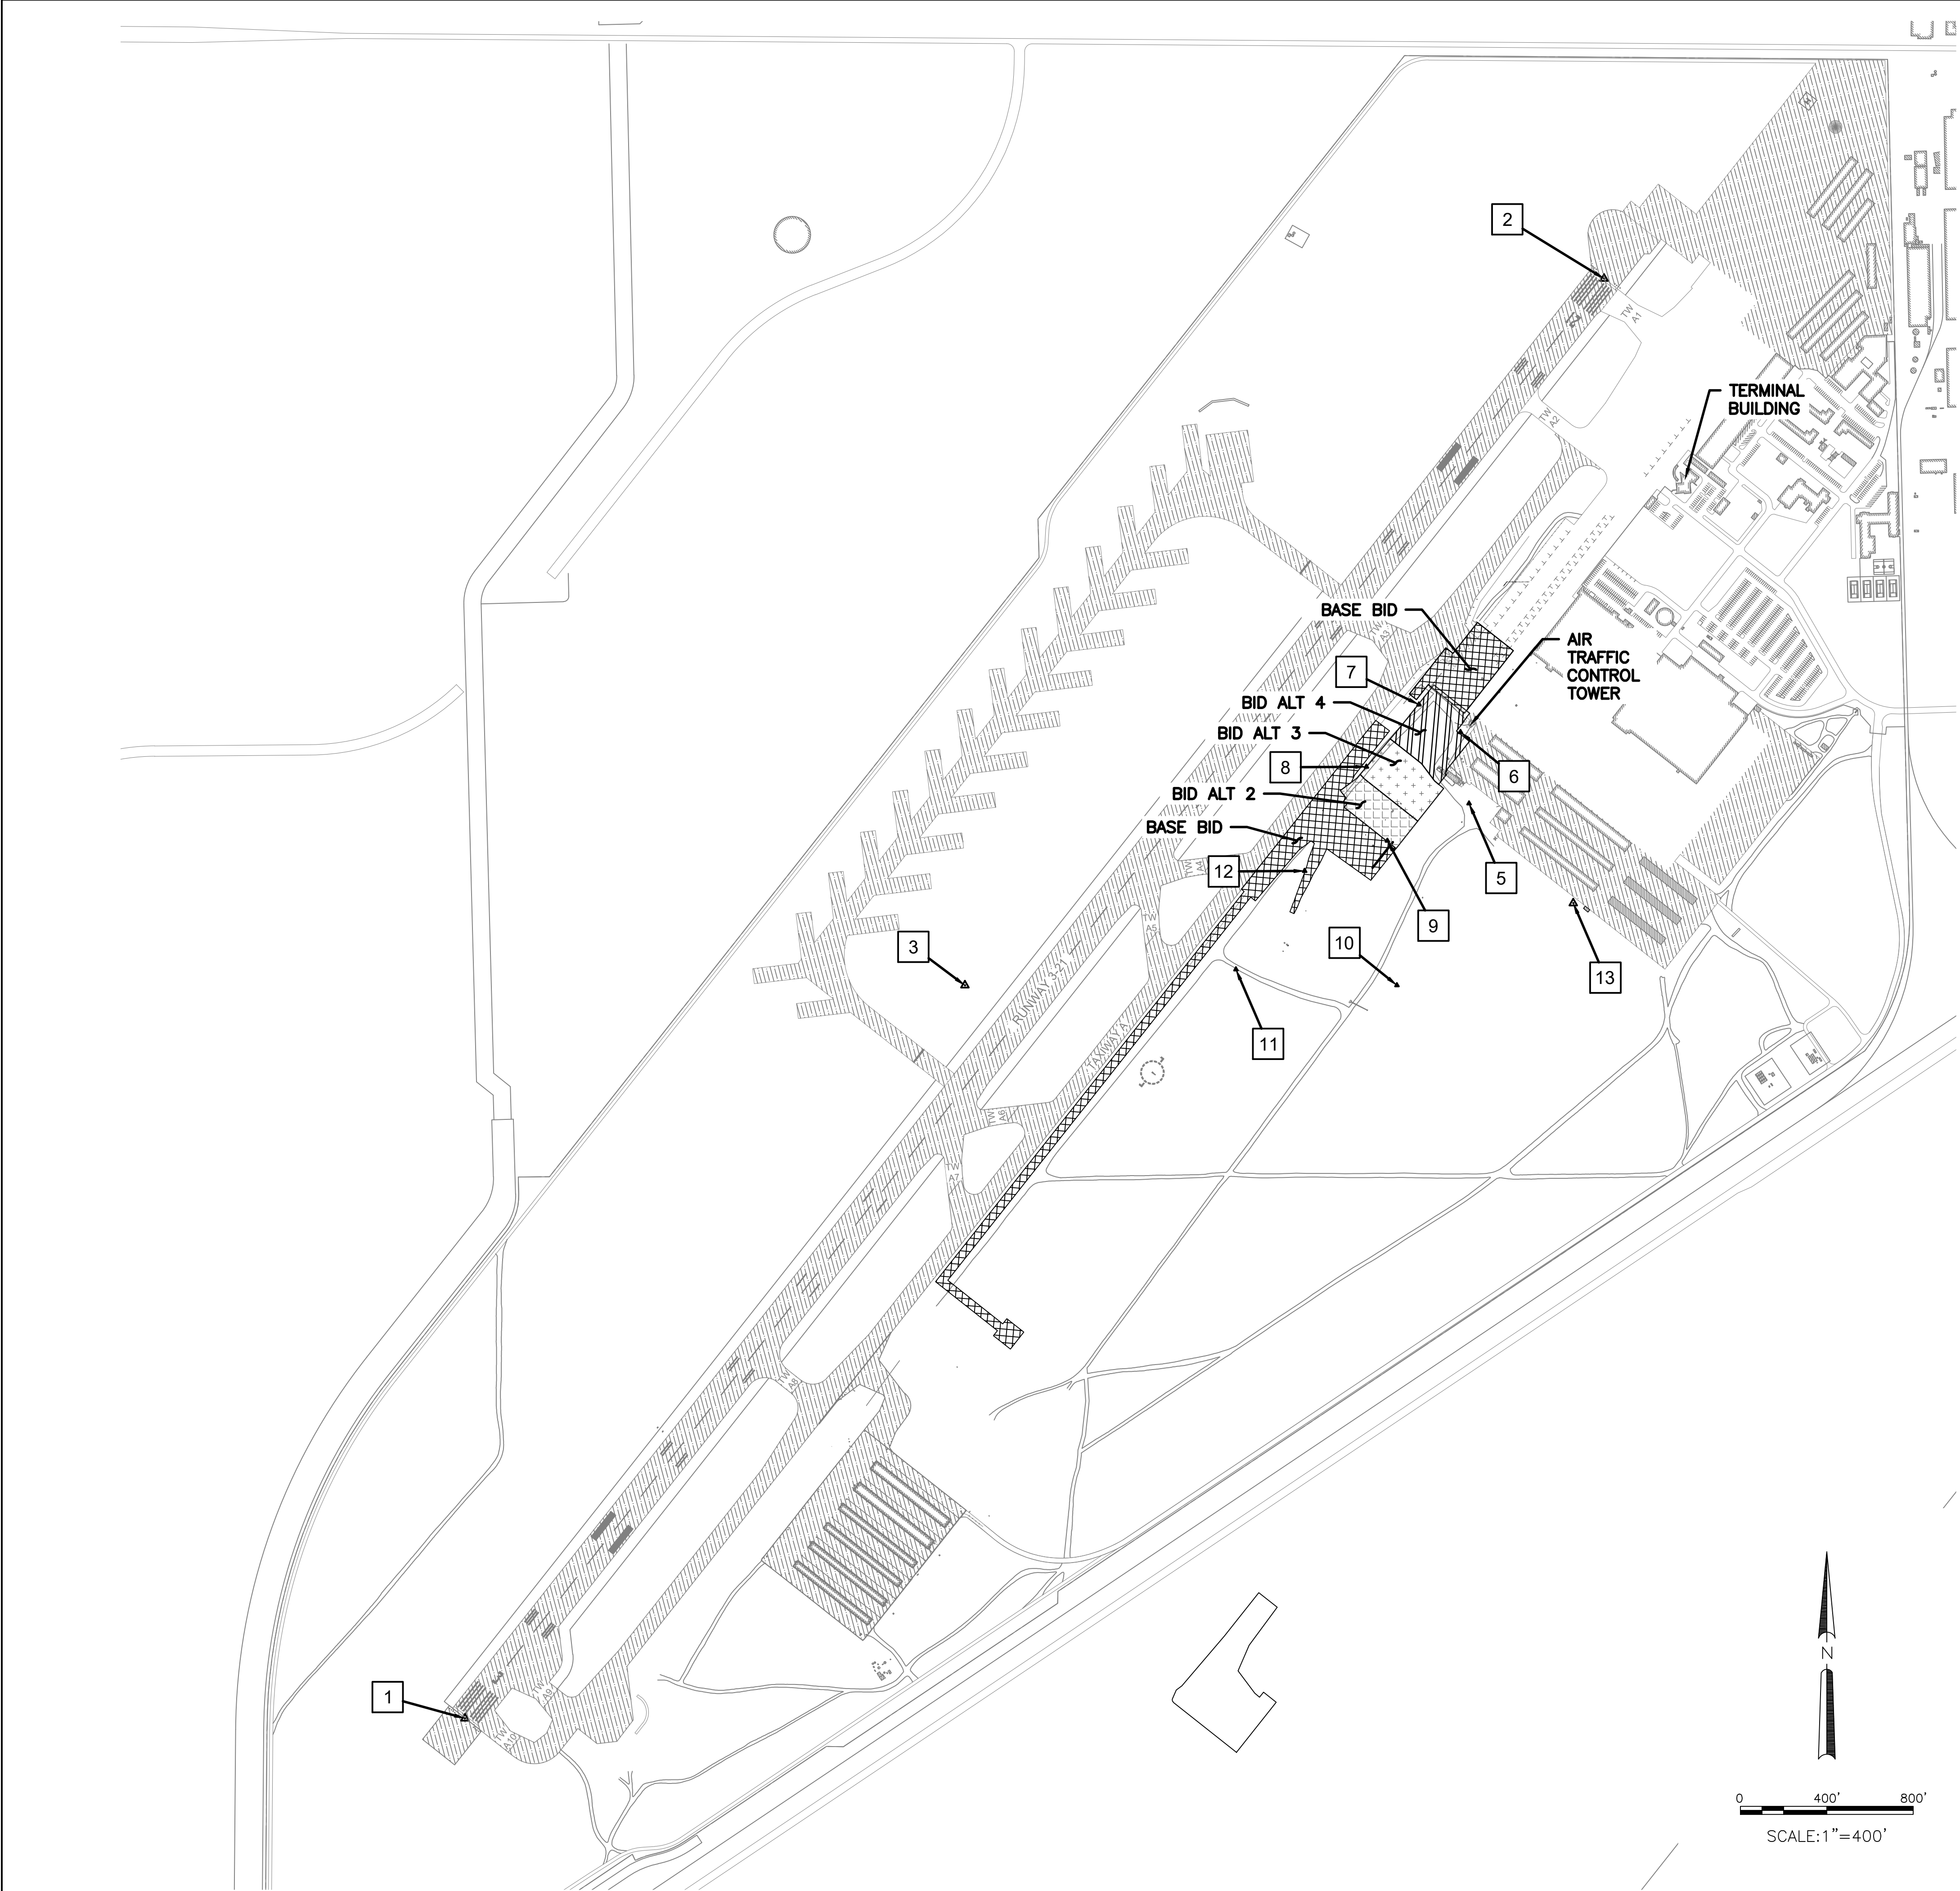

SURVEY CONTROL POINTS				
PT #	NORTHING	EASTING	ELEVATION	DESCRIPTION
1	878617.3520	557481.1470	942.49	BRASS CAP RW 3 END
2	885283.9050	562754.5240	968.75	BRASS CAP RW 21 END
3	882011.8030	559795.3290	956.52	CONTROL POINT
5	882853.7540	562129.3070	956.18	GY 5
6	883184.1390	562089.7990	956.07	CONTROL POINT
7	883312.0210	561897.2290	954.15	CONTROL POINT
8	883023.9080	561653.8940	953.32	CONTROL POINT
9	882681.2840	561751.1590	957.20	CONTROL POINT
10	882011.9950	561795.3050	950.06	GY 06
11	882085.5410	561050.0810	949.87	CONTROL POINT
12	882541.7020	561368.1670	950.35	CONTROL POINT
13	882392.0750	562611.7050	961.32	CONTROL POINT

NOTE:
1. CONTRACTOR SHALL PROTECT ALL CONTROL POINTS AND SURVEY MONUMENTS.
2. BID ALTERNATE 1 NOT SHOWN FOR CLARITY BUT INCLUDES THE INTERIM GRADING OF ALL OF BID ALTERNATE 2, 3 AND 4 AREAS.


C4 CONTROL POINTS
NOT TO SCALE

HORIZONTAL AND VERTICAL DATUM:

NAD 83 (1992 EPOCH) STATE PLANE GROUND COORDINATES, ARIZONA CENTRAL ZONE, USING A GRID TO GROUND ADJUSTMENT FACTOR OF 1.00012, FROM AIRPORT SURVEY CONTROL POINTS 5 (GY-06) AND 8 (GY-10).

A4 SURVEY SUPPORTING INFORMATION
NOT TO SCALE

PER CITY OF PHOENIX CODE CHAPTER 2, SECTION 2-28, THESE PLANS ARE FOR OFFICIAL USE ONLY AND MAY NOT BE SHARED WITH OTHERS EXCEPT AS REQUIRED TO FULFILL THE OBLIGATIONS OF CONTRACTOR'S CONTRACT WITH THE CITY OF PHOENIX.

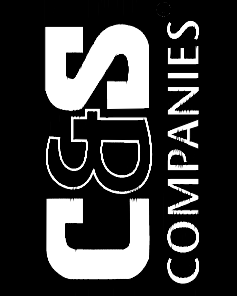

REGISTERED PROFESSIONAL ENGINEER
33442
LANCE R. MCINTOSH
Exp. 3-31-23

PER CITY OF PHOENIX CITY CODE CHAPTER 2, SECTION 2-28, THESE PLANS ARE FOR OFFICIAL USE ONLY AND MAY NOT BE SHARED WITH OTHERS EXCEPT AS REQUIRED TO FULFILL THE OBLIGATIONS OF YOUR CONTRACT WITH THE CITY OF PHOENIX.

NO.	REVISIONS / SUBMISSIONS	DATE



CITY OF PHOENIX AVIATION DEPARTMENT

PHOENIX GOODYEAR AIRPORT
NEW APRON AND TAXIWAY CONNECTOR

AV41000077 FAA/ADOT

Designed by: RB	Drawn by: RB	Checked by: LM	Dwg scale: 1"=400'


CIP NO.(S): AV41000077 FAA/ADOT

Sheet Overview Title

GENERAL PLAN AND SURVEY CONTROL

Sheet Reference Number:
V101

Sheet 5 of 61

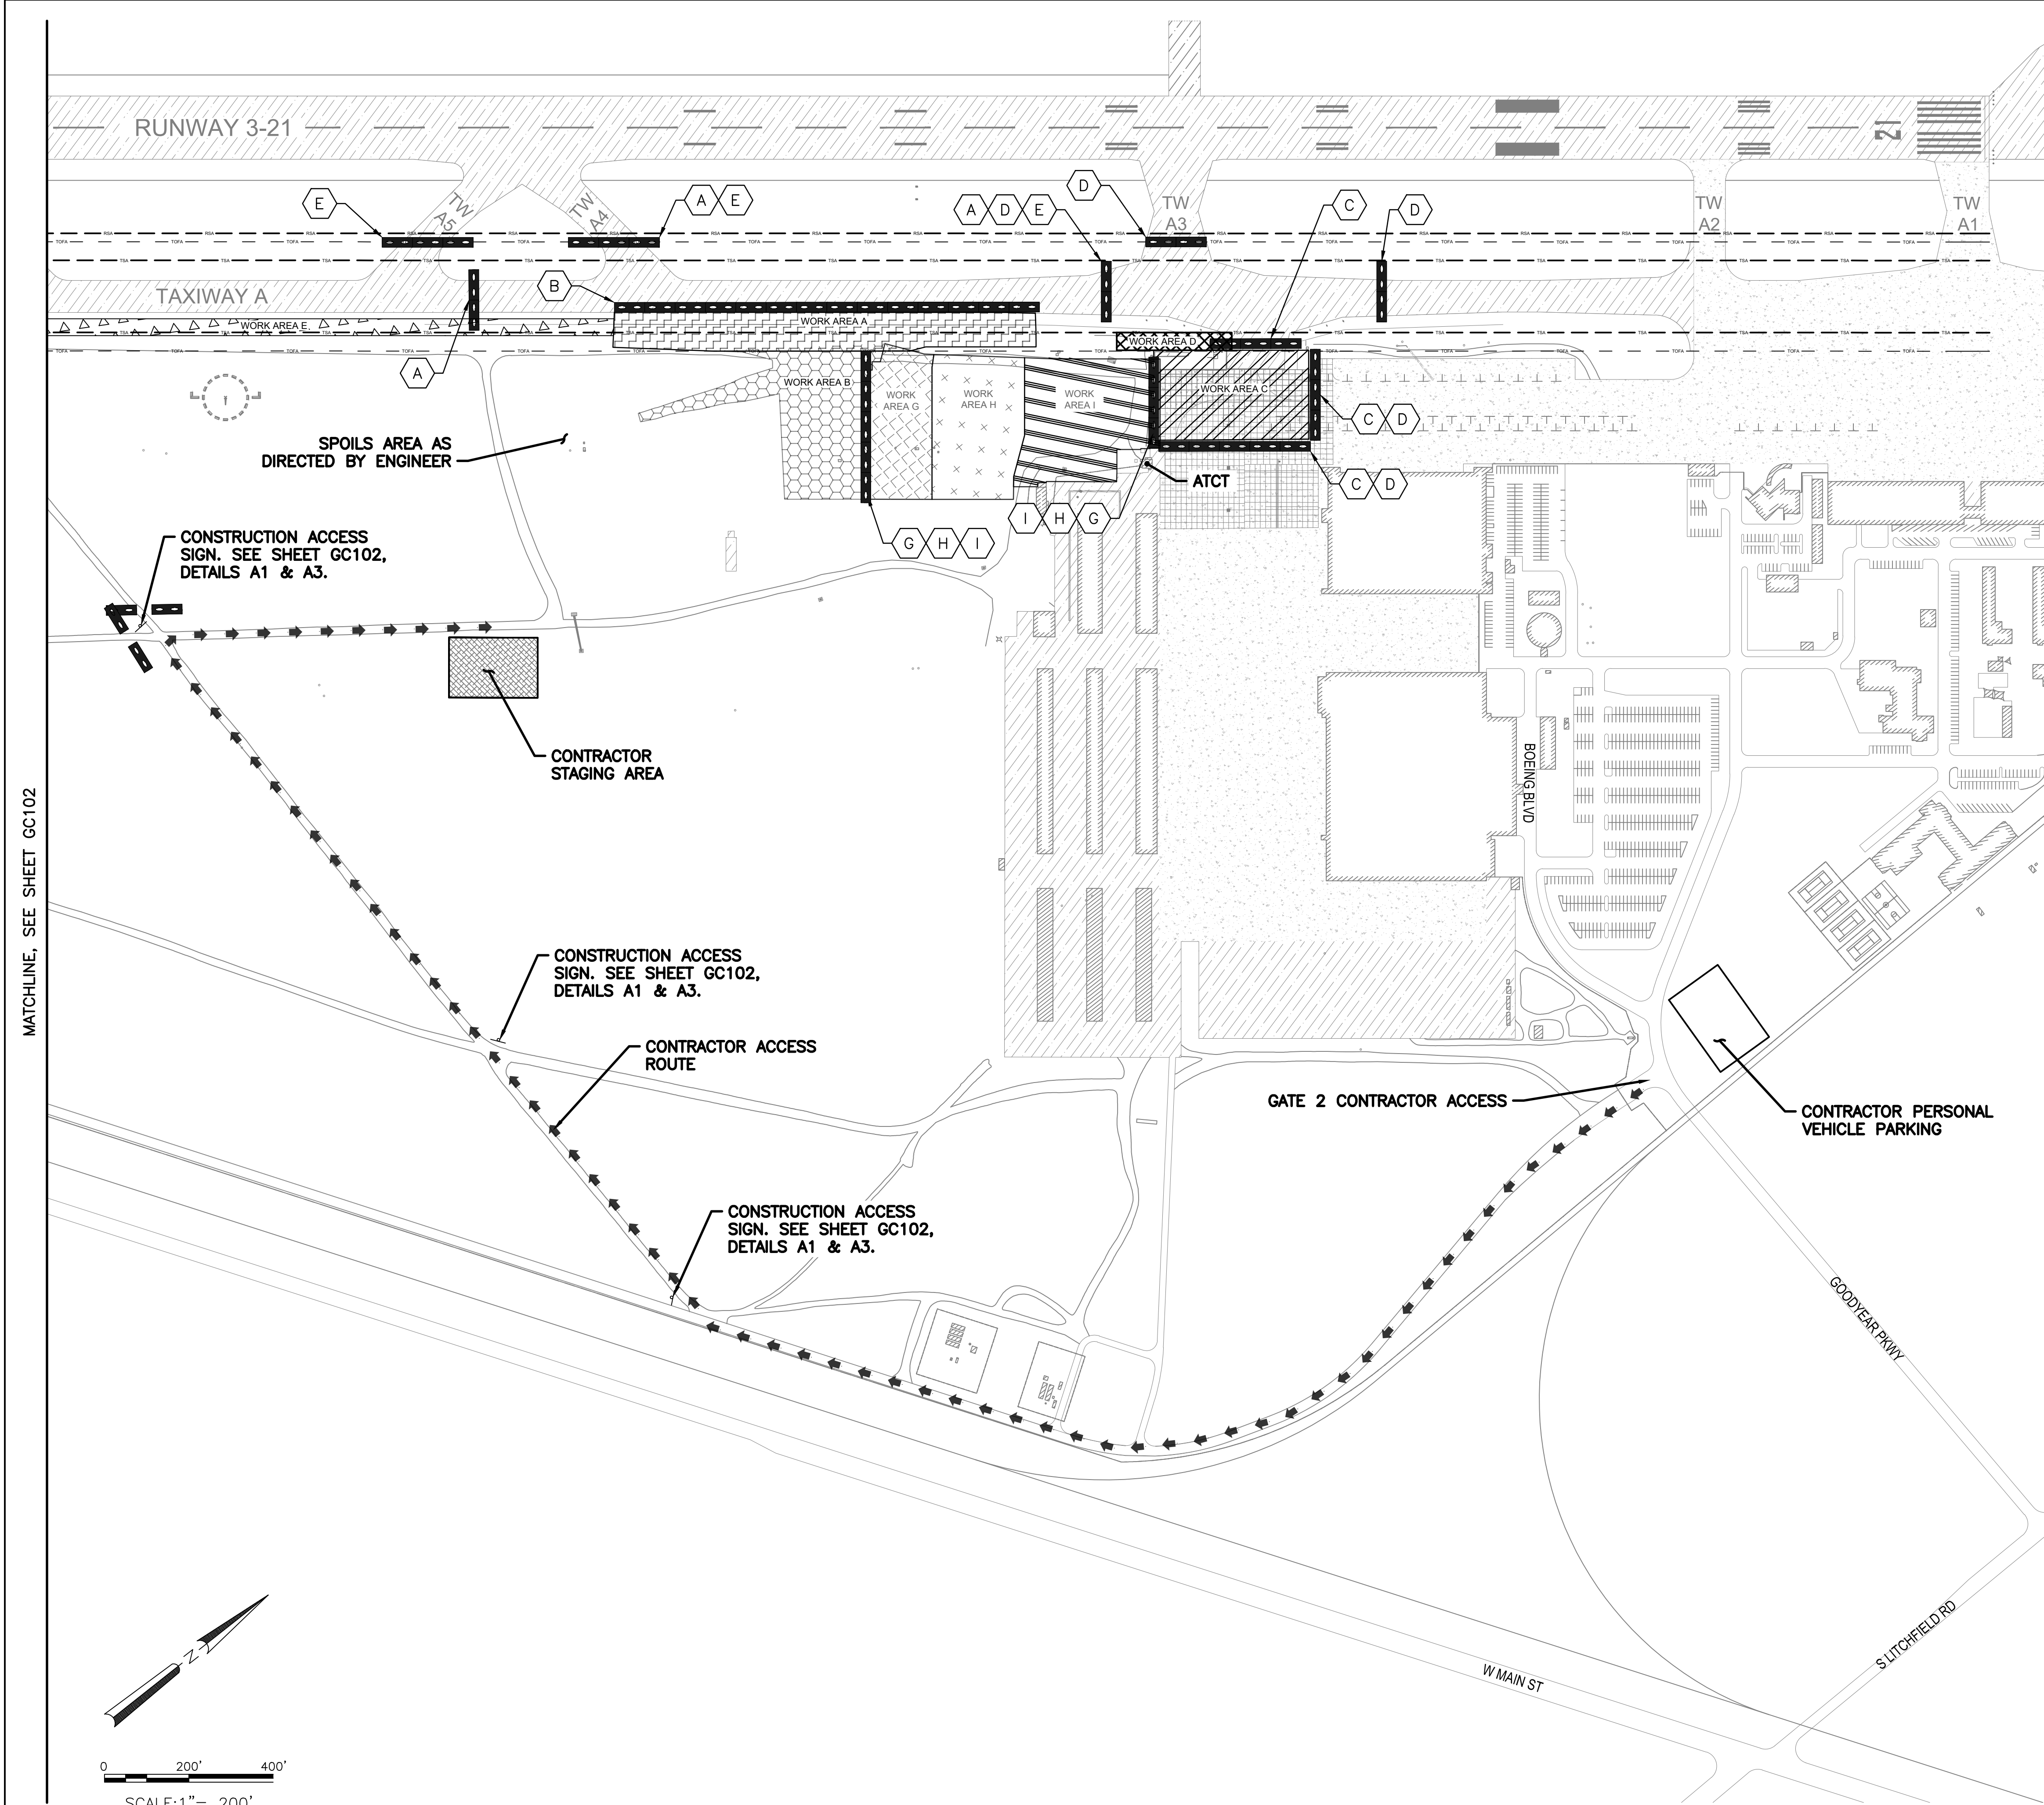

WORK AREA A
WORK AREA B
WORK AREA C
WORK AREA D

WORK AREA E
WORK AREA G
WORK AREA H
WORK AREA I

X


INDICATES BARRICADE
PLACEMENT PER WORK AREA

LOW PROFILE BARRICADES – FULL INTERLOCKED.
SEE DETAIL A4, THIS SHEET.

LOW PROFILE BARRICADES – 5' SPACED. SEE
DETAIL A4, THIS SHEET.

CONTRACTOR ACCESS ROUTE

D4 LEGEND
NOT TO SCALE

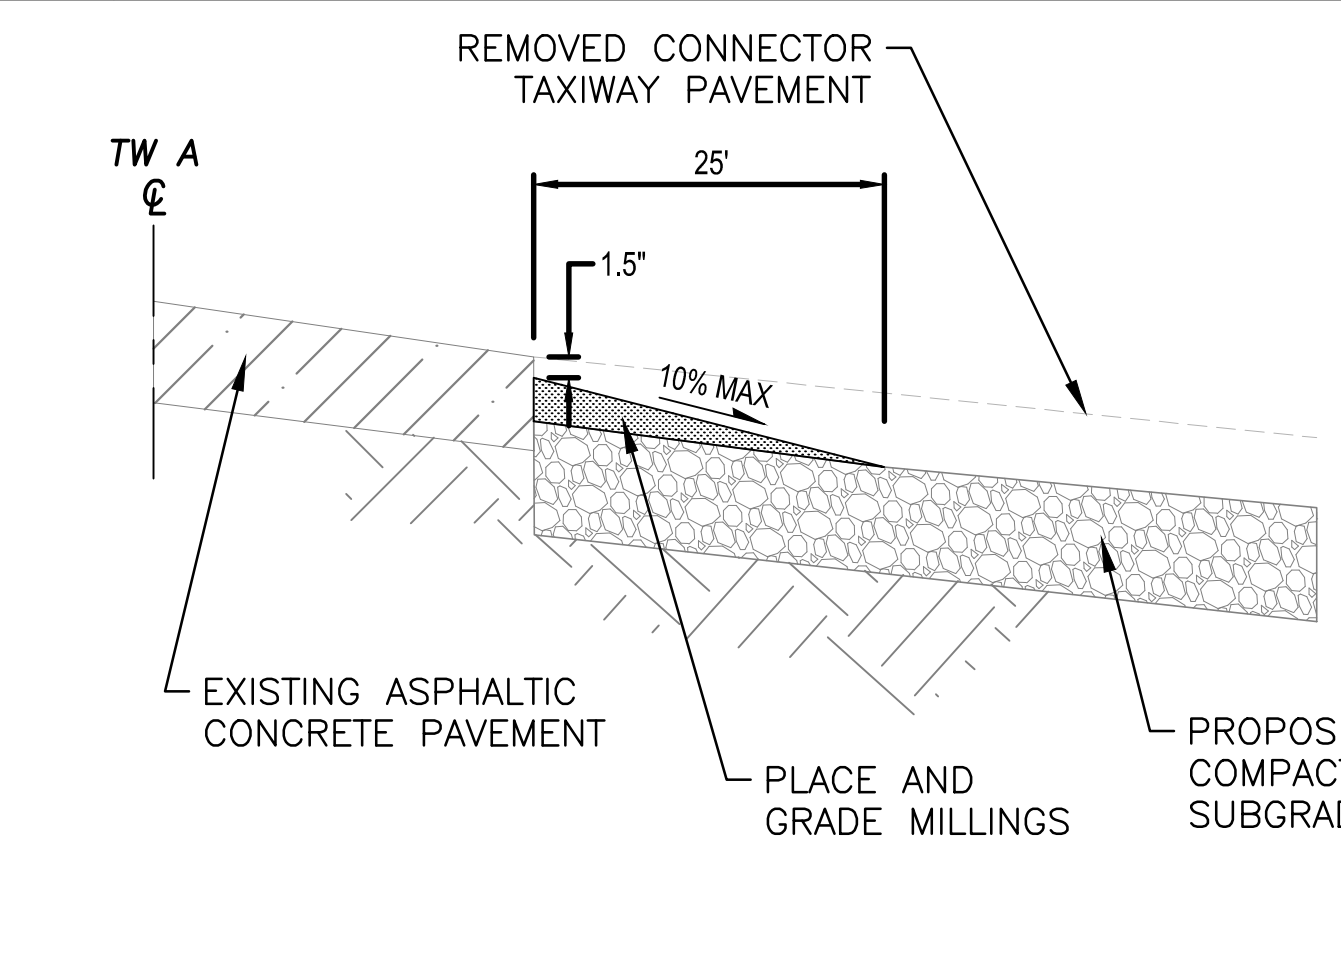


C4 TEMPORARY RAMP DETAIL
NOT TO SCALE

SEE CONSTRUCTION SAFETY AND PHASING PLAN IN SPECIFICATIONS FOR DETAILS ON CONSTRUCTION PHASING.

B4 GENERAL NOTES
NOT TO SCALE

- BARRICADE NOTES:**
1. BARRICADES SHALL BE INTERLOCKED OR SPACED 5' APART, PER PLAN.
 2. THE CONTRACTOR SHALL BE RESPONSIBLE FOR MAINTAINING PROPER POSITIONING OF ALL BARRICADES.
 3. WATER-FILLED TYPE BARRICADES SHALL BE USED (SEE SPECIFICATIONS)
 4. BARRICADES SHALL HAVE TWO FLASHING LAMPS.

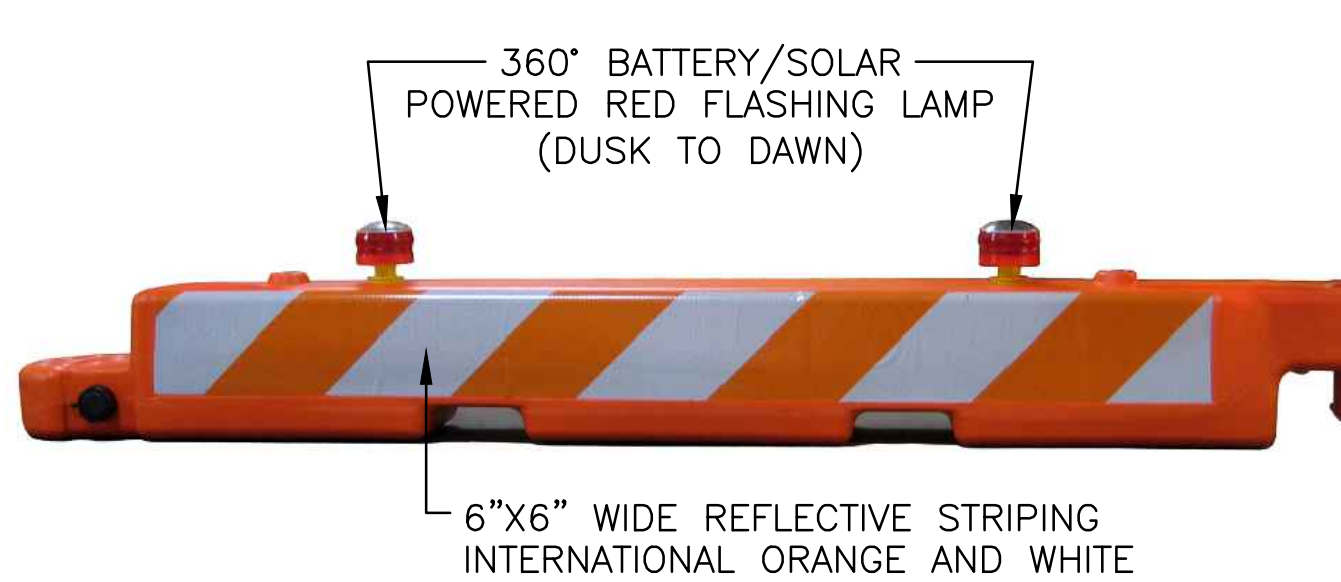

A4 LOW PROFILE SAFETY BARRICADE DETAIL
NOT TO SCALE

PER CITY OF PHOENIX CODE CHAPTER 2, SECTION 2-28, THESE PLANS ARE FOR OFFICIAL USE ONLY AND MAY NOT BE SHARED WITH OTHERS EXCEPT AS REQUIRED TO FULFILL THE OBLIGATIONS OF CONTRACTOR'S CONTRACT WITH THE CITY OF PHOENIX.

CS

COMPANIES

Professional Engineer
33442
LANCE R. MCINTOSH
Phoenix, AZ
Expires: 3-31-23

PER CITY OF PHOENIX CITY CODE CHAPTER 2, SECTION 2-28, THESE PLANS ARE FOR OFFICIAL USE ONLY AND MAY NOT BE SHARED WITH OTHERS EXCEPT AS REQUIRED TO FULFILL THE OBLIGATIONS OF YOUR CONTRACT WITH THE CITY OF PHOENIX.

NO.	REVISIONS / SUBMISSIONS	DATE


PHX DOT CYR
CITY OF PHOENIX AVIATION DEPARTMENT
PHOENIX GOODYEAR AIRPORT
NEW APRON AND TAXIWAY CONNECTOR
AV41000077 FAA/ADOT

Designed by: NM
Drawn by: RB
Checked by: LM
Date: February 2023
Dwg scale:


Sheet Overview Title
**CONSTRUCTION SAFETY
PHASING PLAN**

Sheet Reference Number:
GC101


Sheet 6 of 61

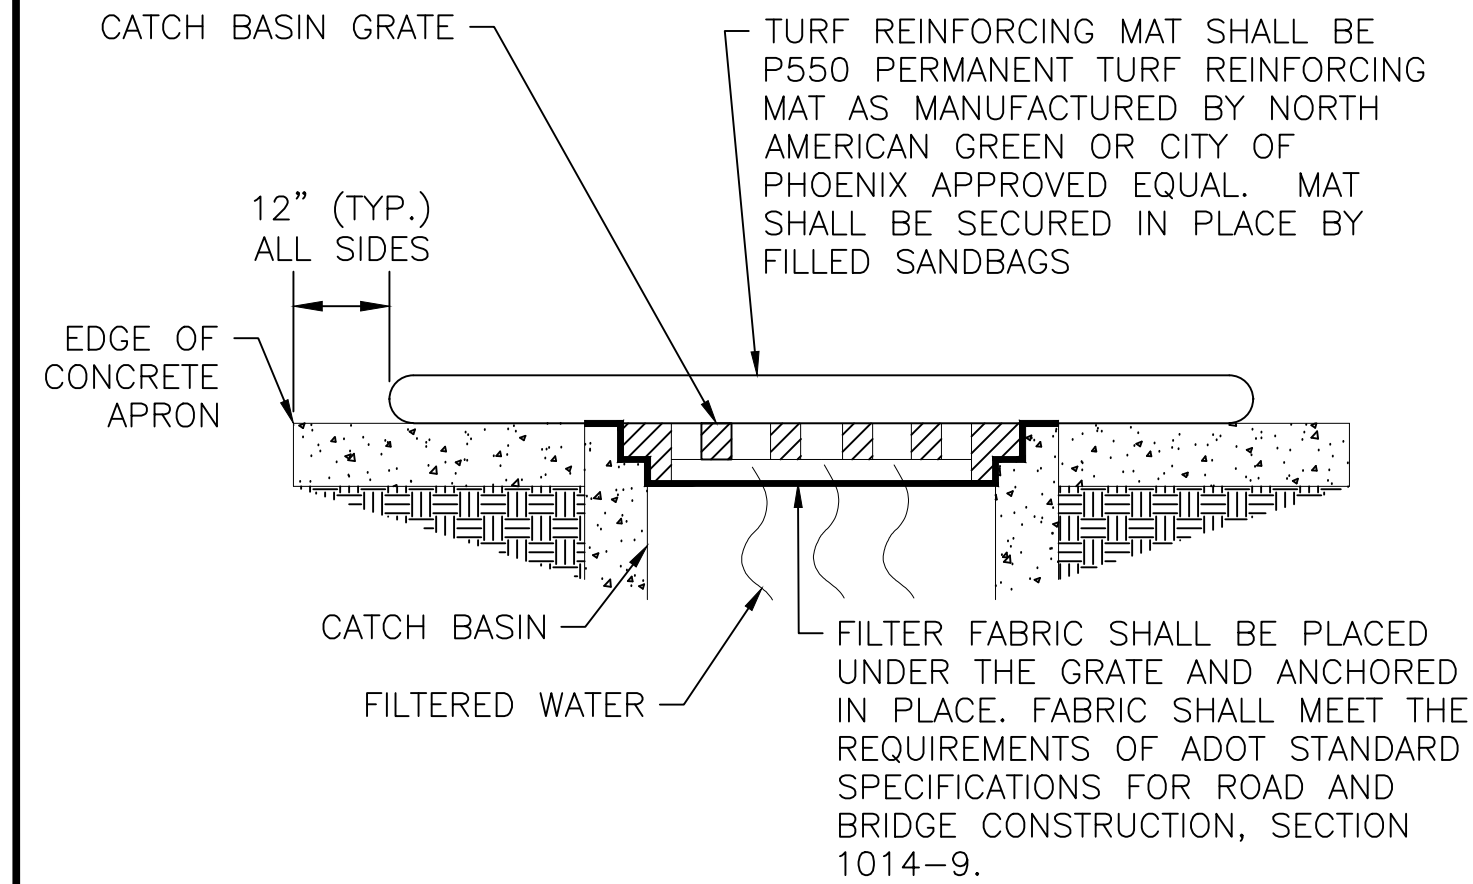

D1 STORM DRAIN INLET PROTECTION
NOT TO SCALE

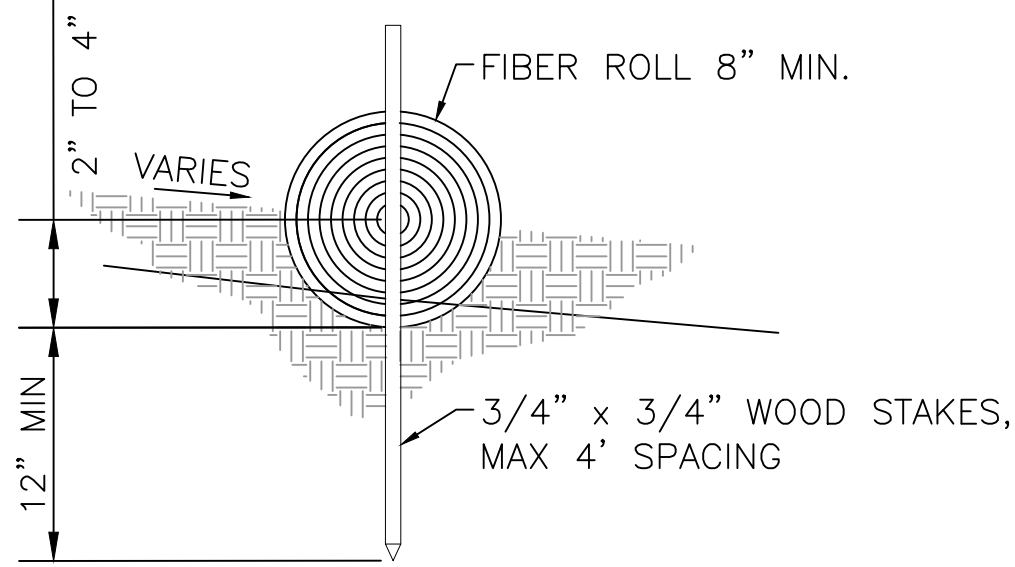


D2 TYPE 1 FIBER ROLL DETAIL
NOT TO SCALE

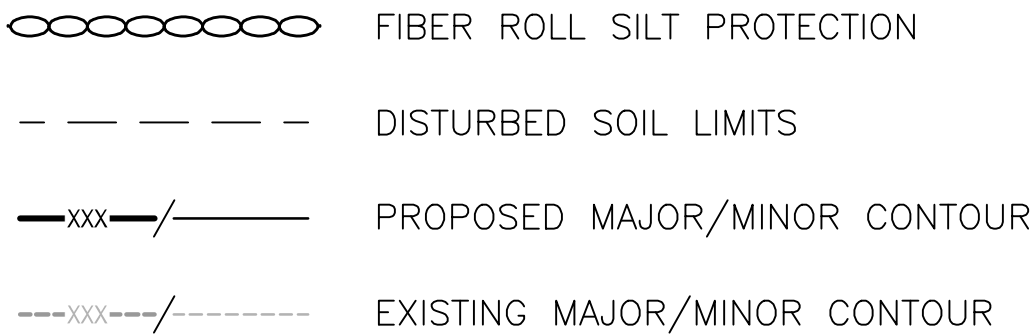

D3 LEGEND
NOT TO SCALE

- 1 CATCH BASIN INLET PROTECTION, SEE DETAIL D1, THIS SHEET. (BASE BID) ITEM C-102.
- 2 FIBER ROLL SILT PROTECTION, SEE DETAIL D2, THIS SHEET. (BASE BID) ITEM C-102.

D4 CONSTRUCTION NOTES
NOT TO SCALE

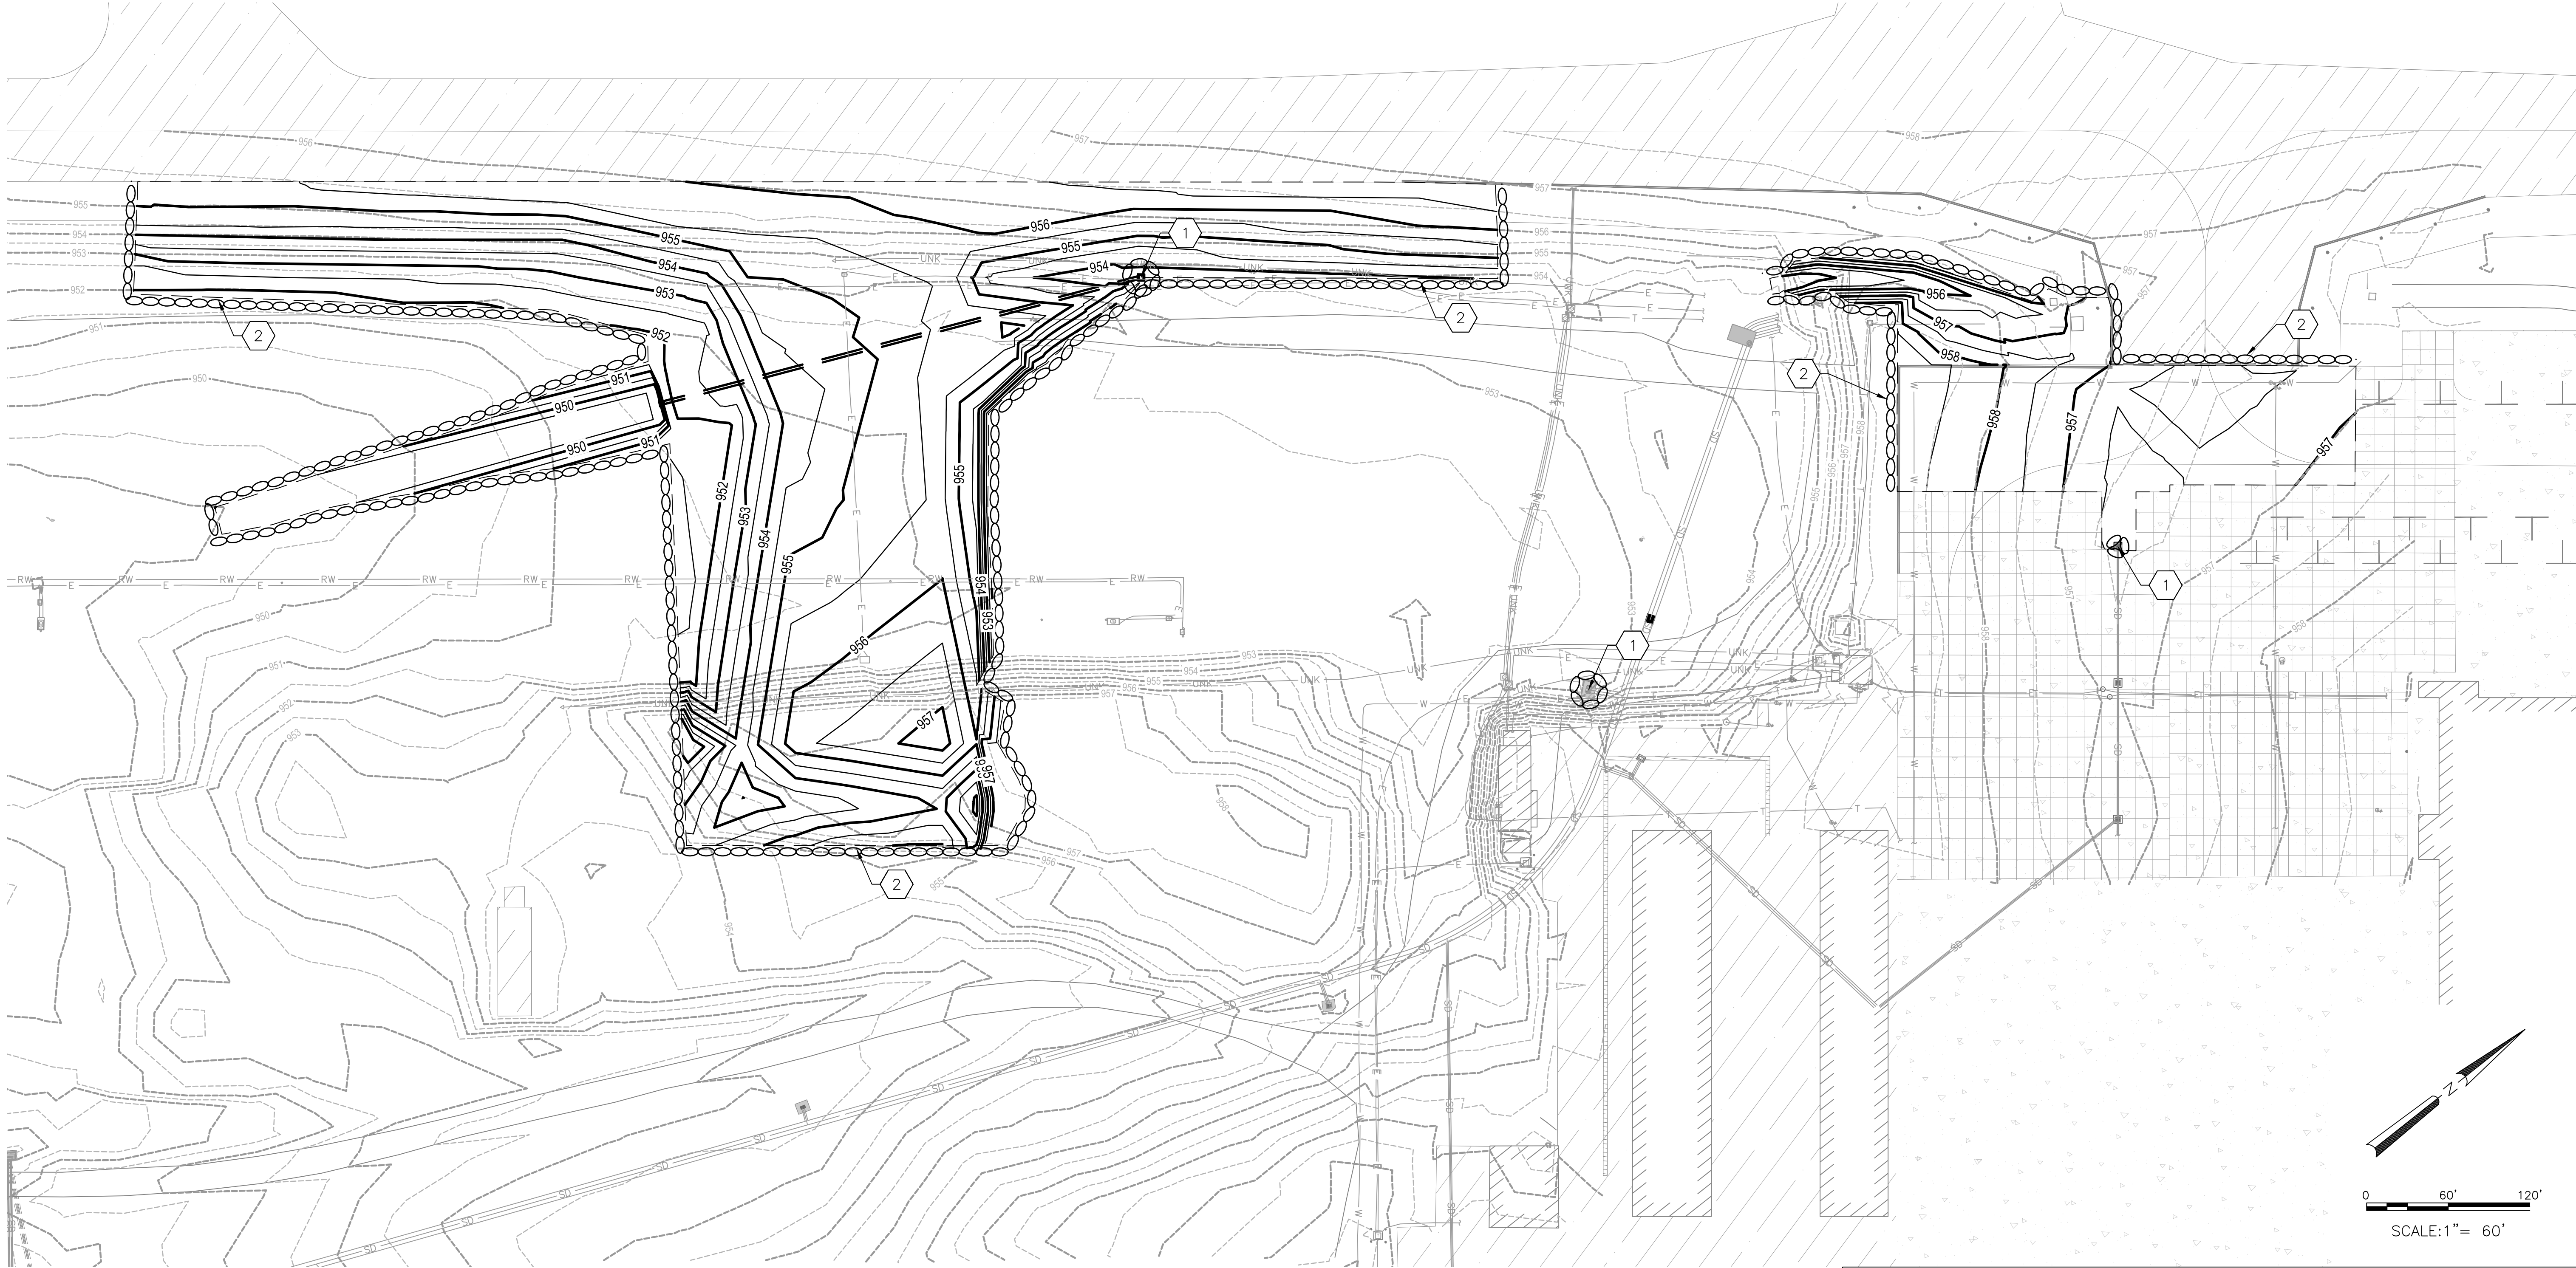

A1 EROSION CONTROL PLAN
SCALE: 1" = 60'

PER CITY OF PHOENIX CODE CHAPTER 2, SECTION 2-28, THESE PLANS ARE FOR OFFICIAL USE ONLY AND MAY NOT BE SHARED WITH OTHERS EXCEPT AS REQUIRED TO FULFILL THE OBLIGATIONS OF CONTRACTOR'S CONTRACT WITH THE CITY OF PHOENIX.

PER CITY OF PHOENIX CITY CODE CHAPTER 2, SECTION 2-28, THESE PLANS ARE FOR OFFICIAL USE ONLY AND MAY NOT BE SHARED WITH OTHERS EXCEPT AS REQUIRED TO FULFILL THE OBLIGATIONS OF YOUR CONTRACT WITH THE CITY OF PHOENIX.


PHX DVT CYR
CITY OF PHOENIX AVIATION DEPARTMENT
PHOENIX GOODYEAR AIRPORT
NEW APRON AND TAXIWAY CONNECTOR
AV41000077 FAA/ADOT

Designed by: NM
Drawn by: RB
Checked by: LM
Date: February 2023
Dwg. scale: —


Sheet Overview Title
**EROSION CONTROL PLAN
BASE BID**

Sheet Reference Number:
GC201




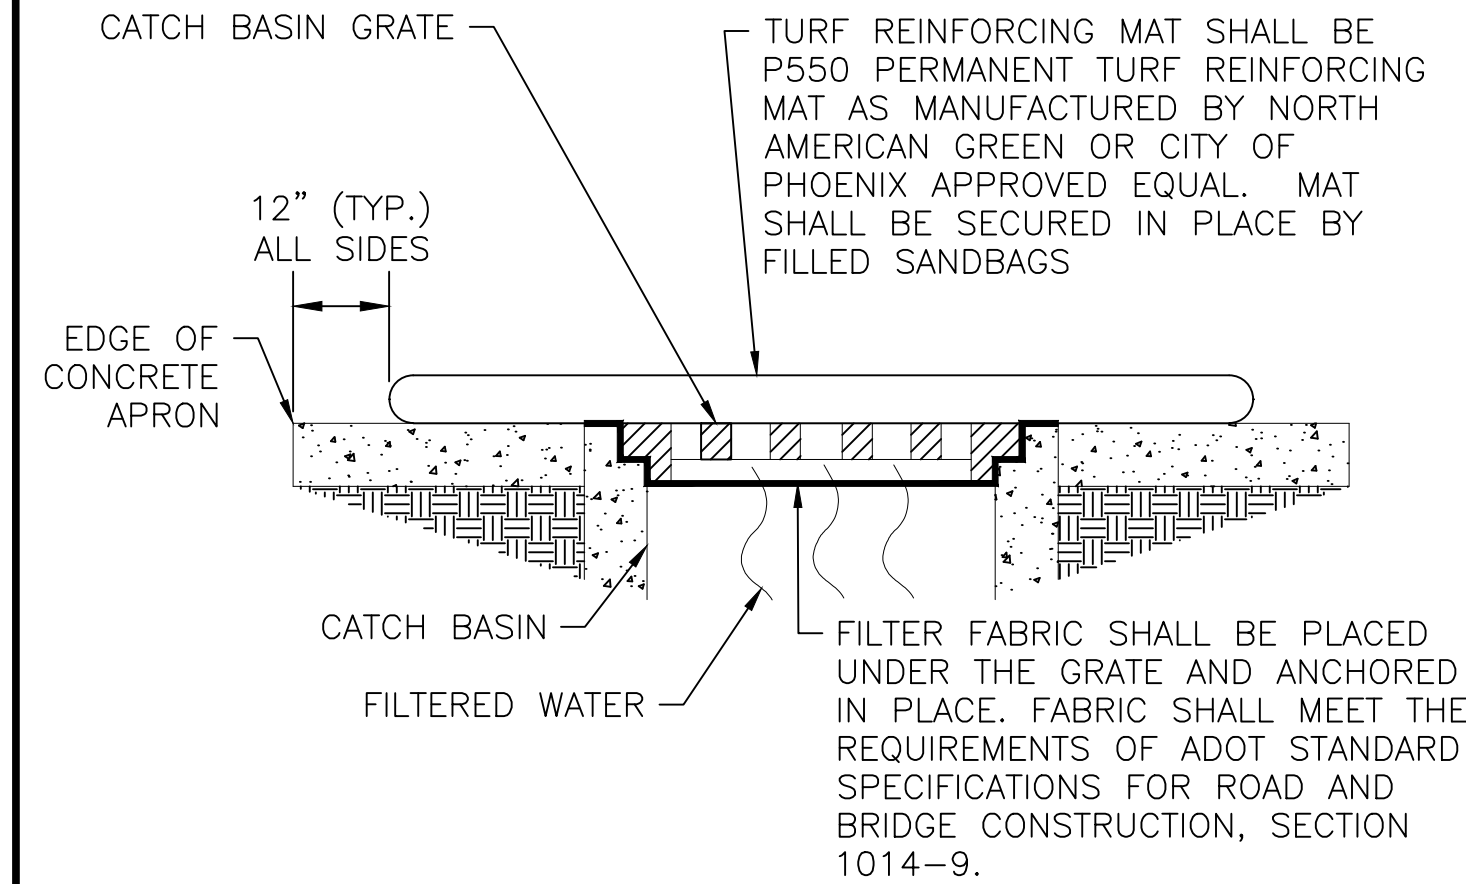

D1 STORM DRAIN INLET PROTECTION
NOT TO SCALE

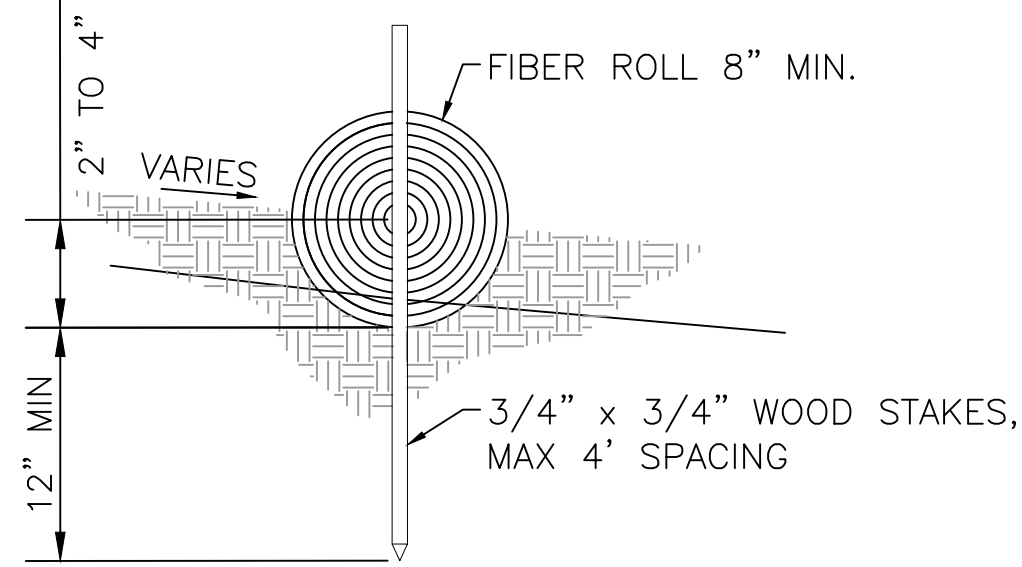


D2 TYPE 1 FIBER ROLL DETAIL
NOT TO SCALE

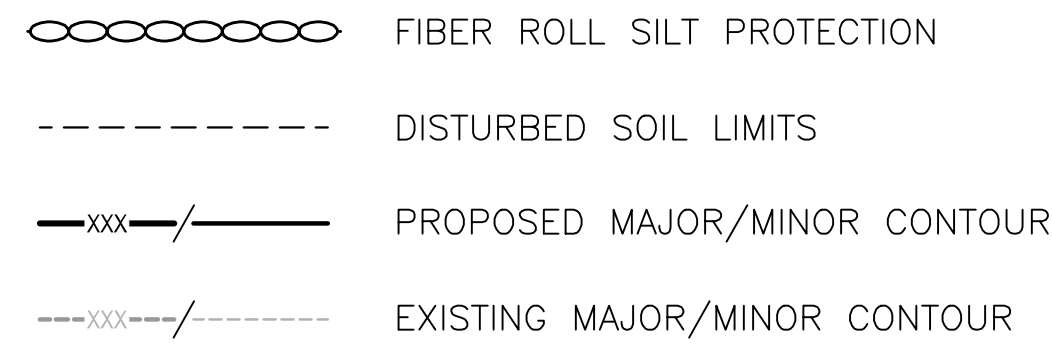

D3 LEGEND
NOT TO SCALE

- 1 CATCH BASIN INLET PROTECTION, SEE DETAIL D1, THIS SHEET.
(ALT 1) ITEM C-102.
- 2 FIBER ROLL SILT PROTECTION, SEE DETAIL D2, THIS SHEET.
(ALT 1) ITEM C-102.

D4 CONSTRUCTION NOTES
NOT TO SCALE

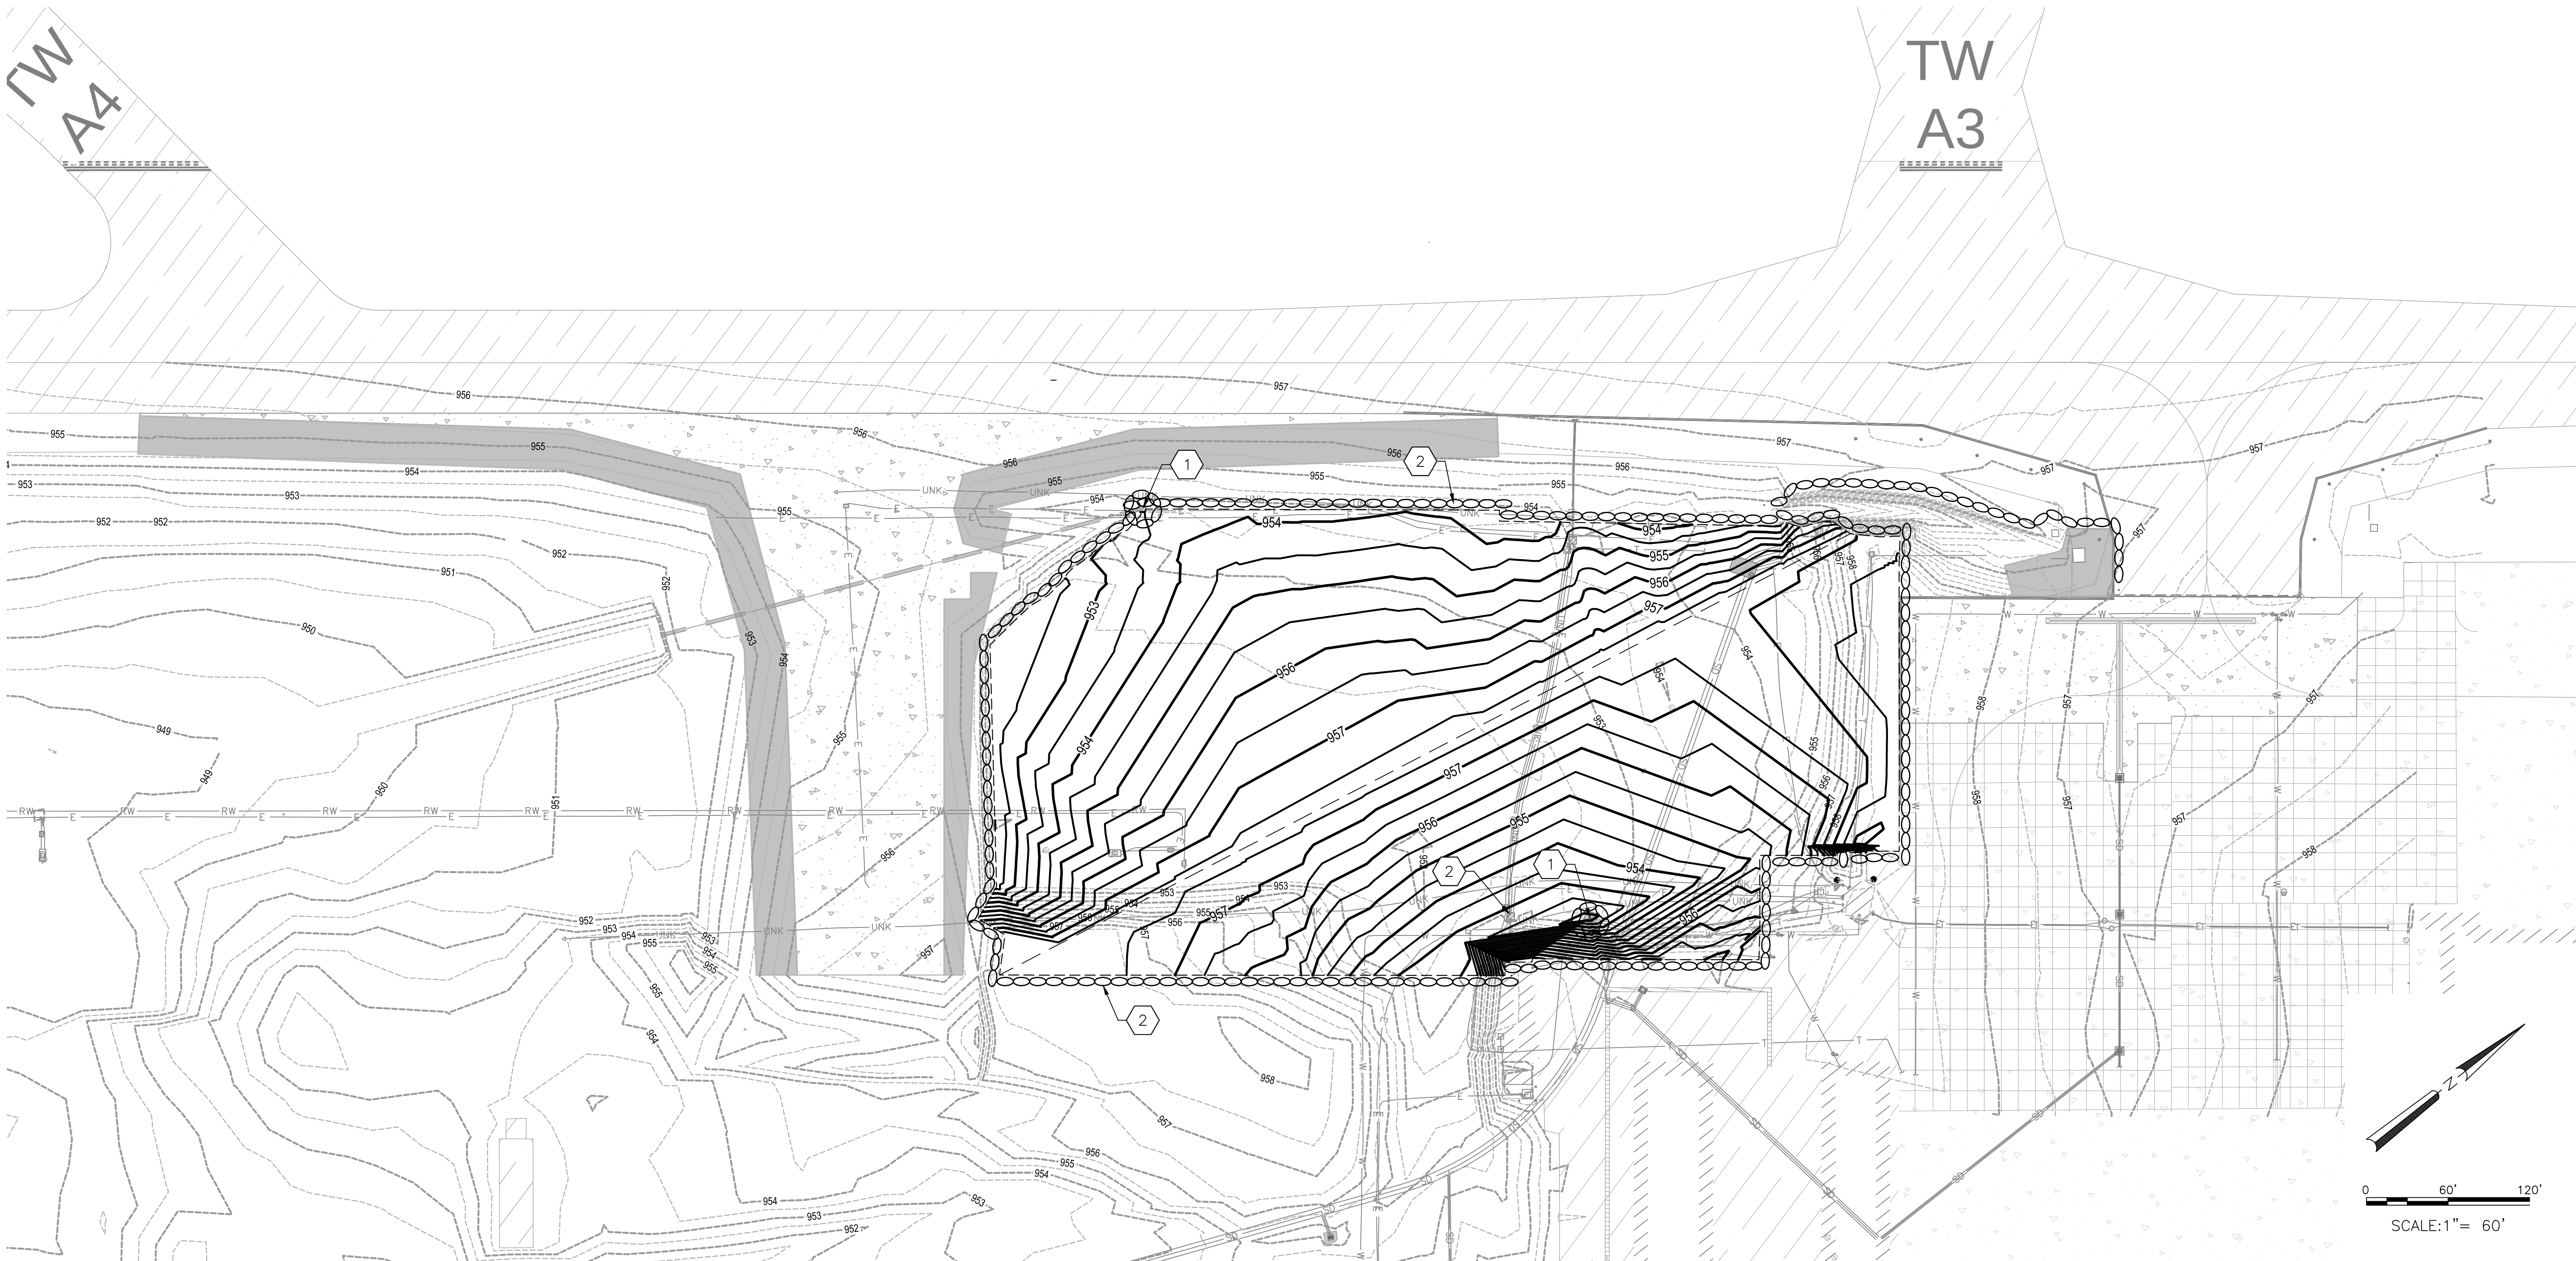

A1 GRADING AND DRAINAGE PLAN
SCALE: 1" = 60'

PER CITY OF PHOENIX CODE CHAPTER 2, SECTION 2-28, THESE PLANS ARE FOR OFFICIAL USE ONLY AND MAY NOT BE SHARED WITH OTHERS EXCEPT AS REQUIRED TO FULFILL THE OBLIGATIONS OF CONTRACTOR'S CONTRACT WITH THE CITY OF PHOENIX.

PER CITY OF PHOENIX CITY CODE CHAPTER 2, SECTION 2-28, THESE PLANS ARE FOR OFFICIAL USE ONLY AND MAY NOT BE SHARED WITH OTHERS EXCEPT AS REQUIRED TO FULFILL THE OBLIGATIONS OF YOUR CONTRACT WITH THE CITY OF PHOENIX.	NO.	REVISIONS / SUBMISSIONS	DATE


CITY OF PHOENIX AVIATION DEPARTMENT
PHOENIX GOODYEAR AIRPORT
NEW APRON AND TAXIWAY CONNECTOR

AV41000077 FAA/ADOT


Designed by: RB	Sheet Overview Title
Drawn by: RB	EROSION CONTROL PLAN
Checked by: LM	BID ALT 1
Date: February 2023	
Dwg scale: 1" = 60'	

Sheet Reference Number:
GC202


Sheet 9 of 61

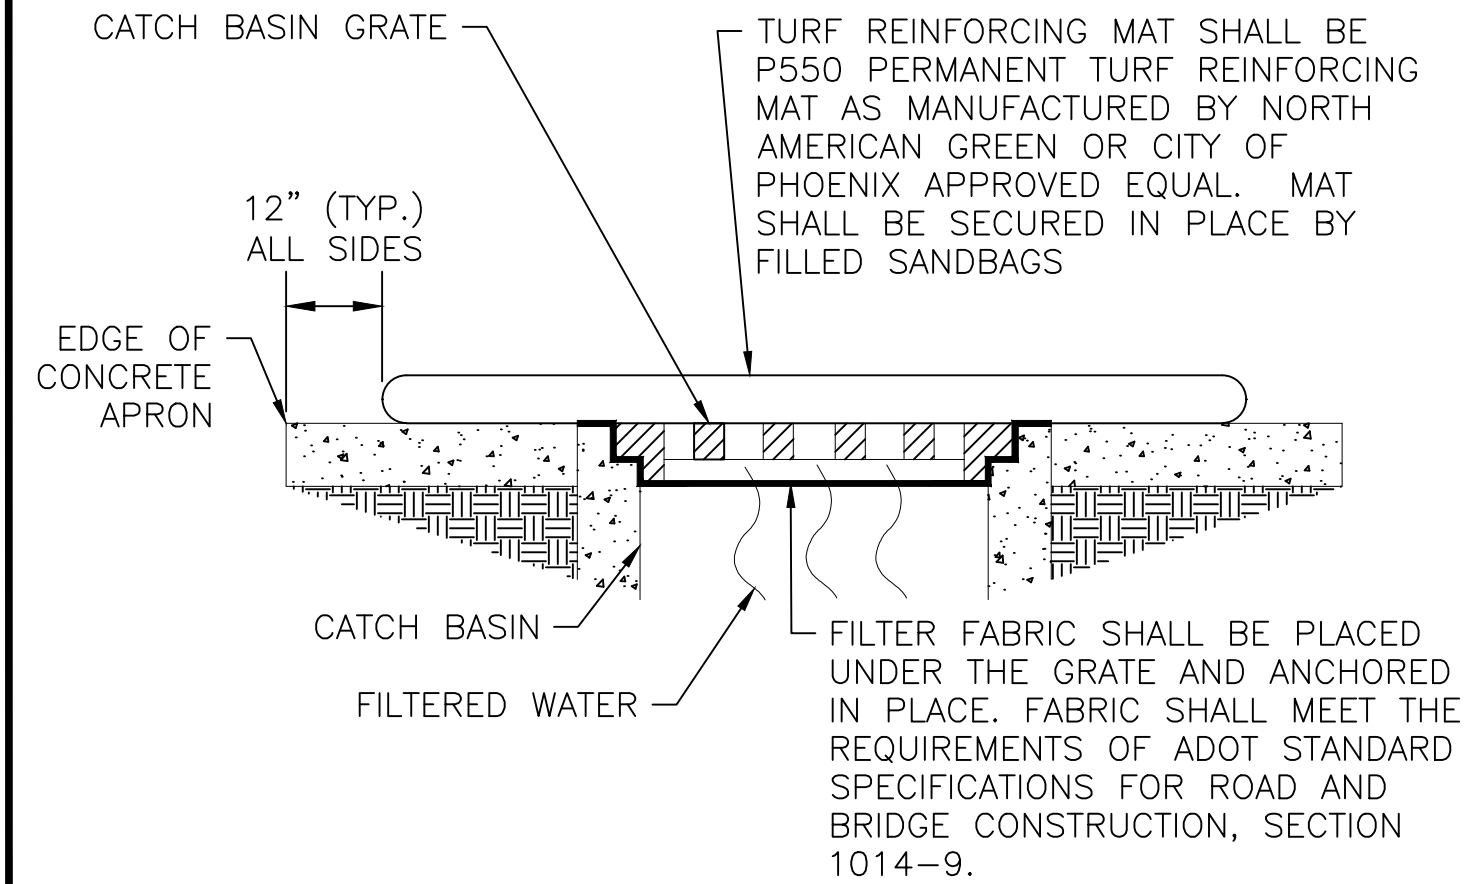

D1 STORM DRAIN INLET PROTECTION
NOT TO SCALE

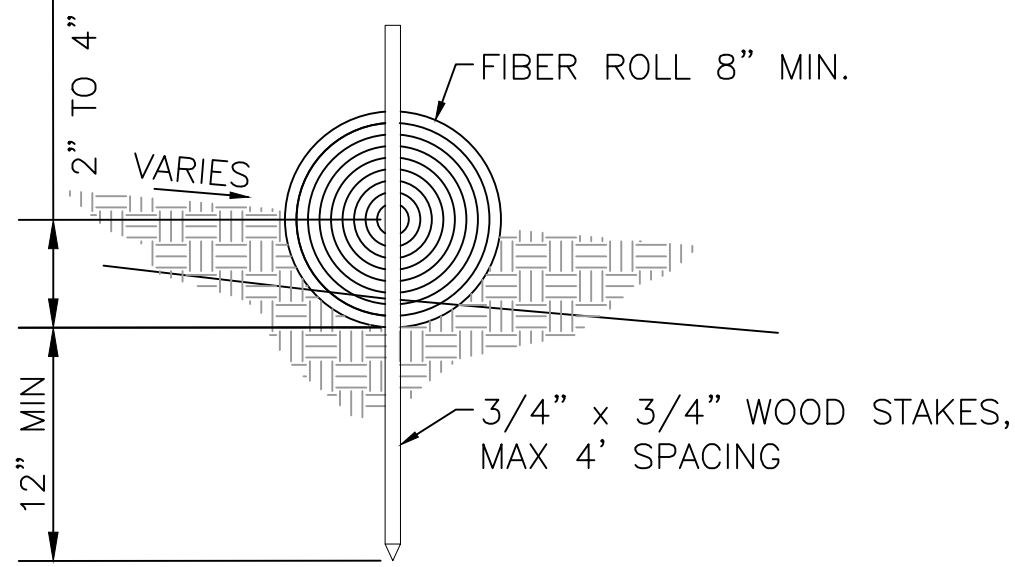


D2 TYPE 1 FIBER ROLL DETAIL
NOT TO SCALE

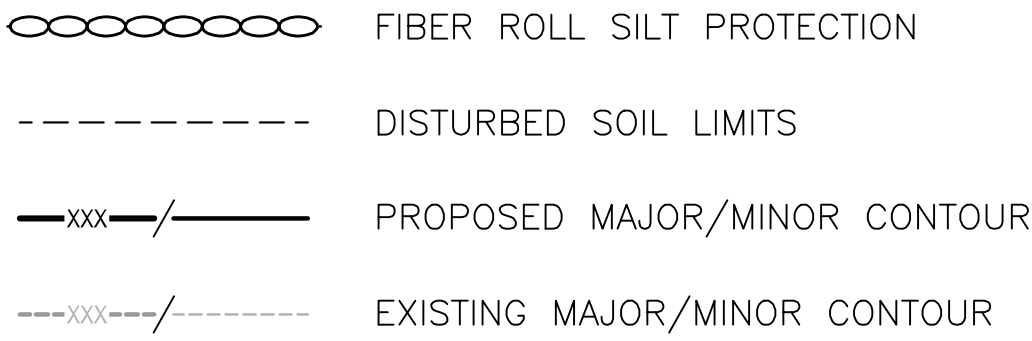

D3 LEGEND
NOT TO SCALE

- 1 CATCH BASIN INLET PROTECTION, SEE DETAIL D1, THIS SHEET.
(ALT 2) ITEM C-102.
- 2 FIBER ROLL SILT PROTECTION, SEE DETAIL D2, THIS SHEET.
(ALT 2) ITEM C-102.

D4 CONSTRUCTION NOTES
NOT TO SCALE

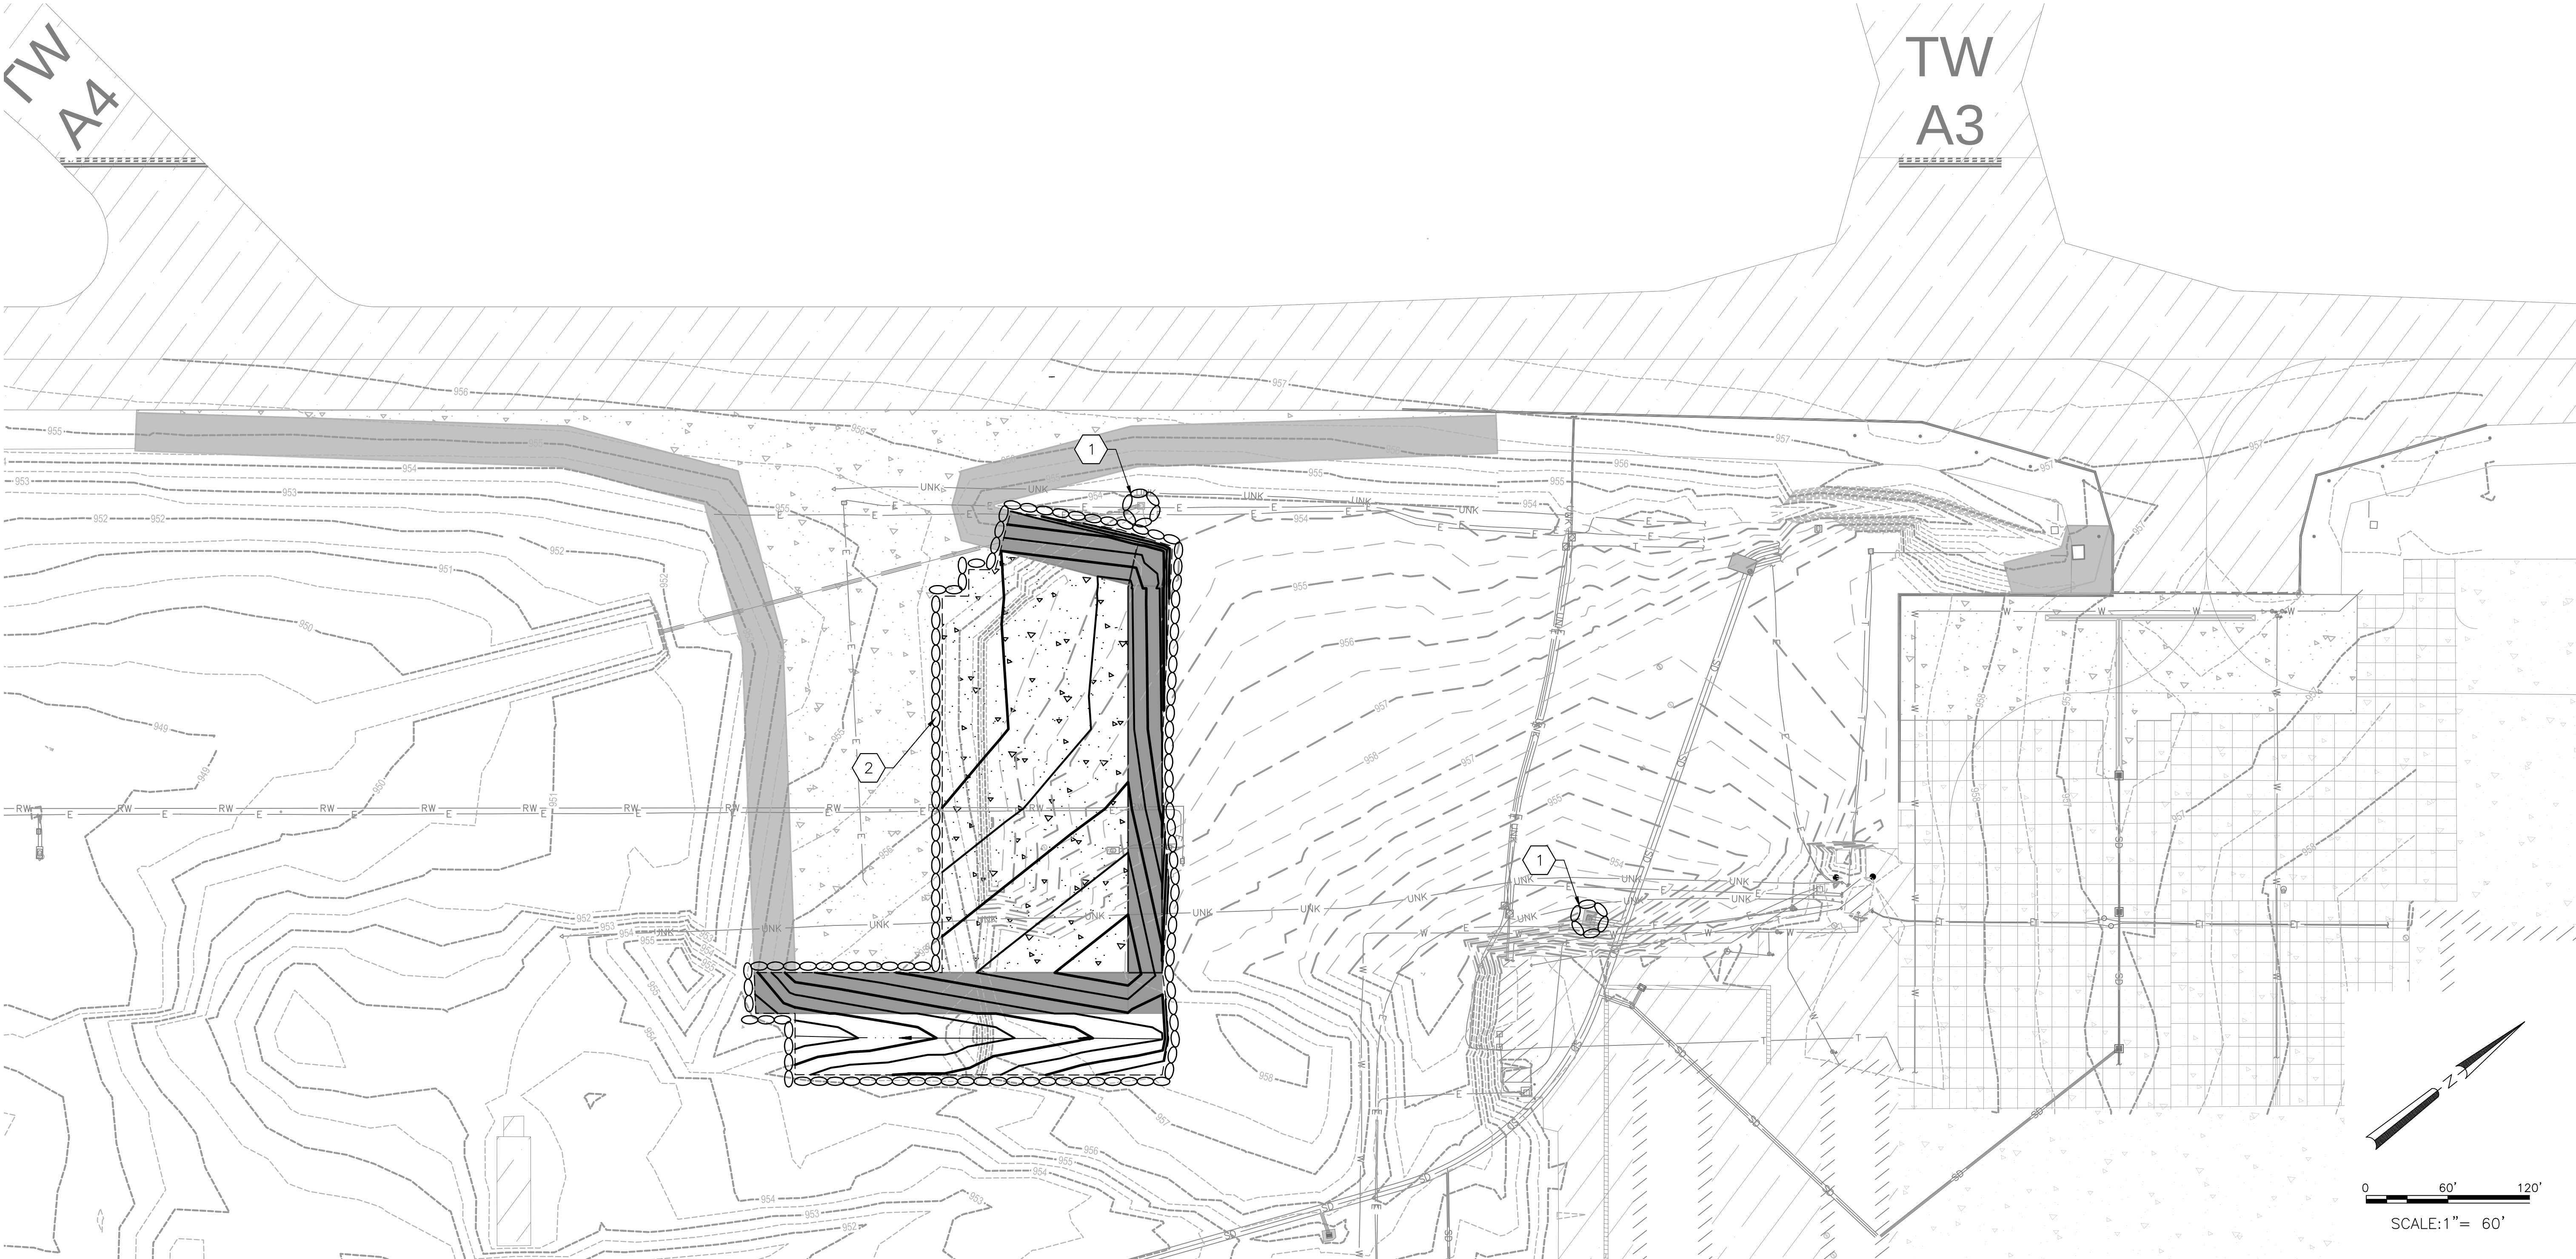

A1 GRADING AND DRAINAGE PLAN
SCALE: 1" = 60'

PER CITY OF PHOENIX CODE CHAPTER 2, SECTION 2-28, THESE PLANS ARE FOR OFFICIAL USE ONLY AND MAY NOT BE SHARED WITH OTHERS EXCEPT AS REQUIRED TO FULFILL THE OBLIGATIONS OF CONTRACTOR'S CONTRACT WITH THE CITY OF PHOENIX.

DESIGNED BY: RB	PHX DVT CYR CITY OF PHOENIX AVIATION DEPARTMENT PHOENIX GOODYEAR AIRPORT NEW APRON AND TAXIWAY CONNECTOR AV41000077 FAA/ADOT	NO.	REVISIONS / SUBMISSIONS	DATE
DRAWN BY: RB				
CHECKED BY: LM				
DATE: FEBRUARY 2023				
DWG. SCALE:				
CIP NO.(S): AV41000077 FAA/ADOT				


Sheet Overview Title

EROSION CONTROL PLAN
BID ALT 2


Sheet Reference Number:

GC203


Sheet 10 of 61

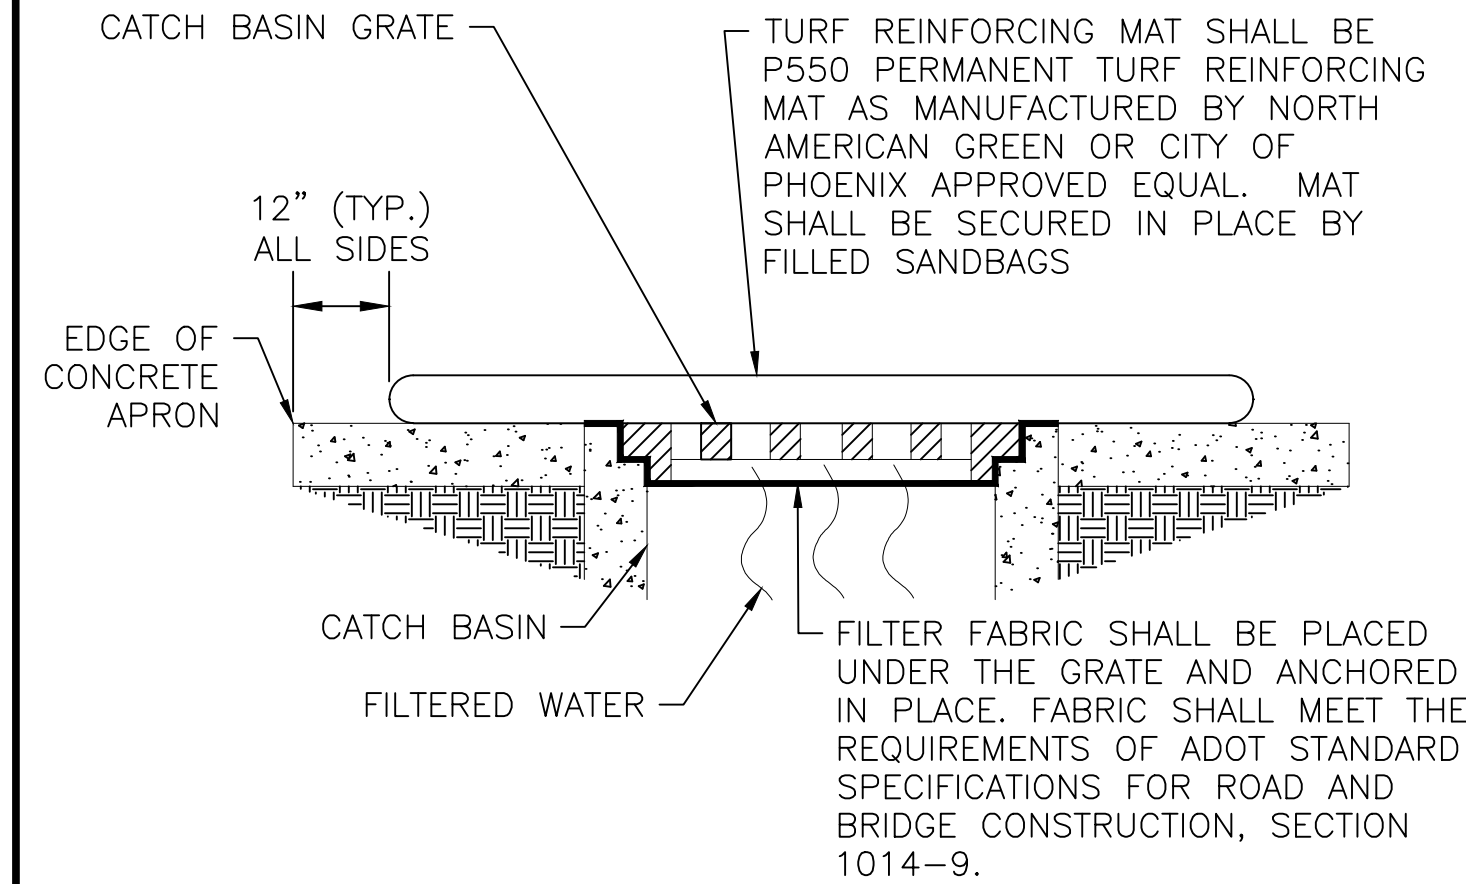

D1 STORM DRAIN INLET PROTECTION
NOT TO SCALE

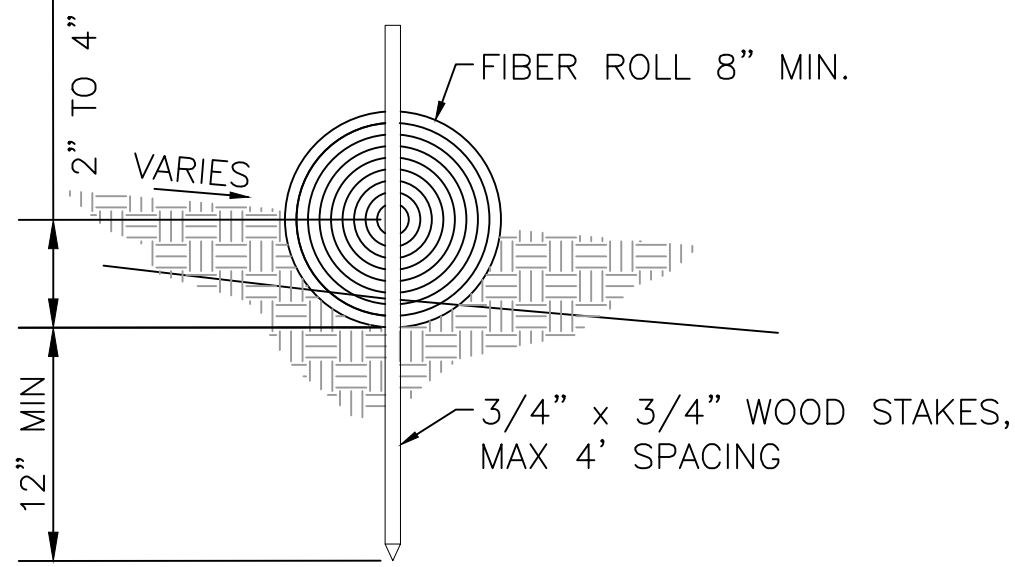


D2 TYPE 1 FIBER ROLL DETAIL
NOT TO SCALE

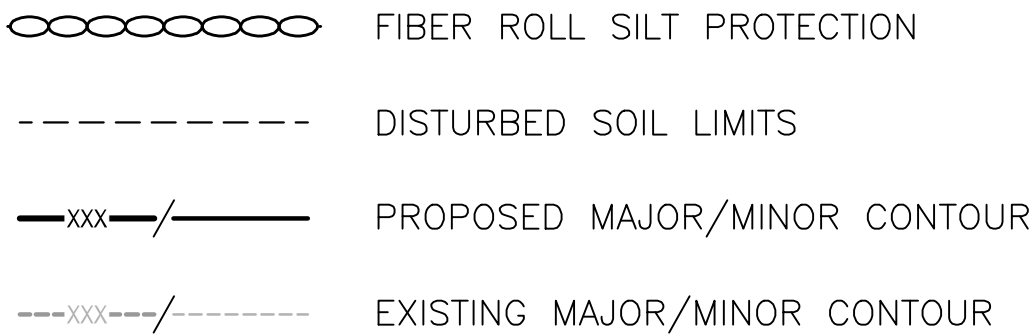

D3 LEGEND
NOT TO SCALE


- 1 CATCH BASIN INLET PROTECTION, SEE DETAIL D1, THIS SHEET.
(ALT 3) ITEM C-102.
- 2 FIBER ROLL SILT PROTECTION, SEE DETAIL D2, THIS SHEET.
(ALT 3) ITEM C-102.

D4 CONSTRUCTION NOTES
NOT TO SCALE

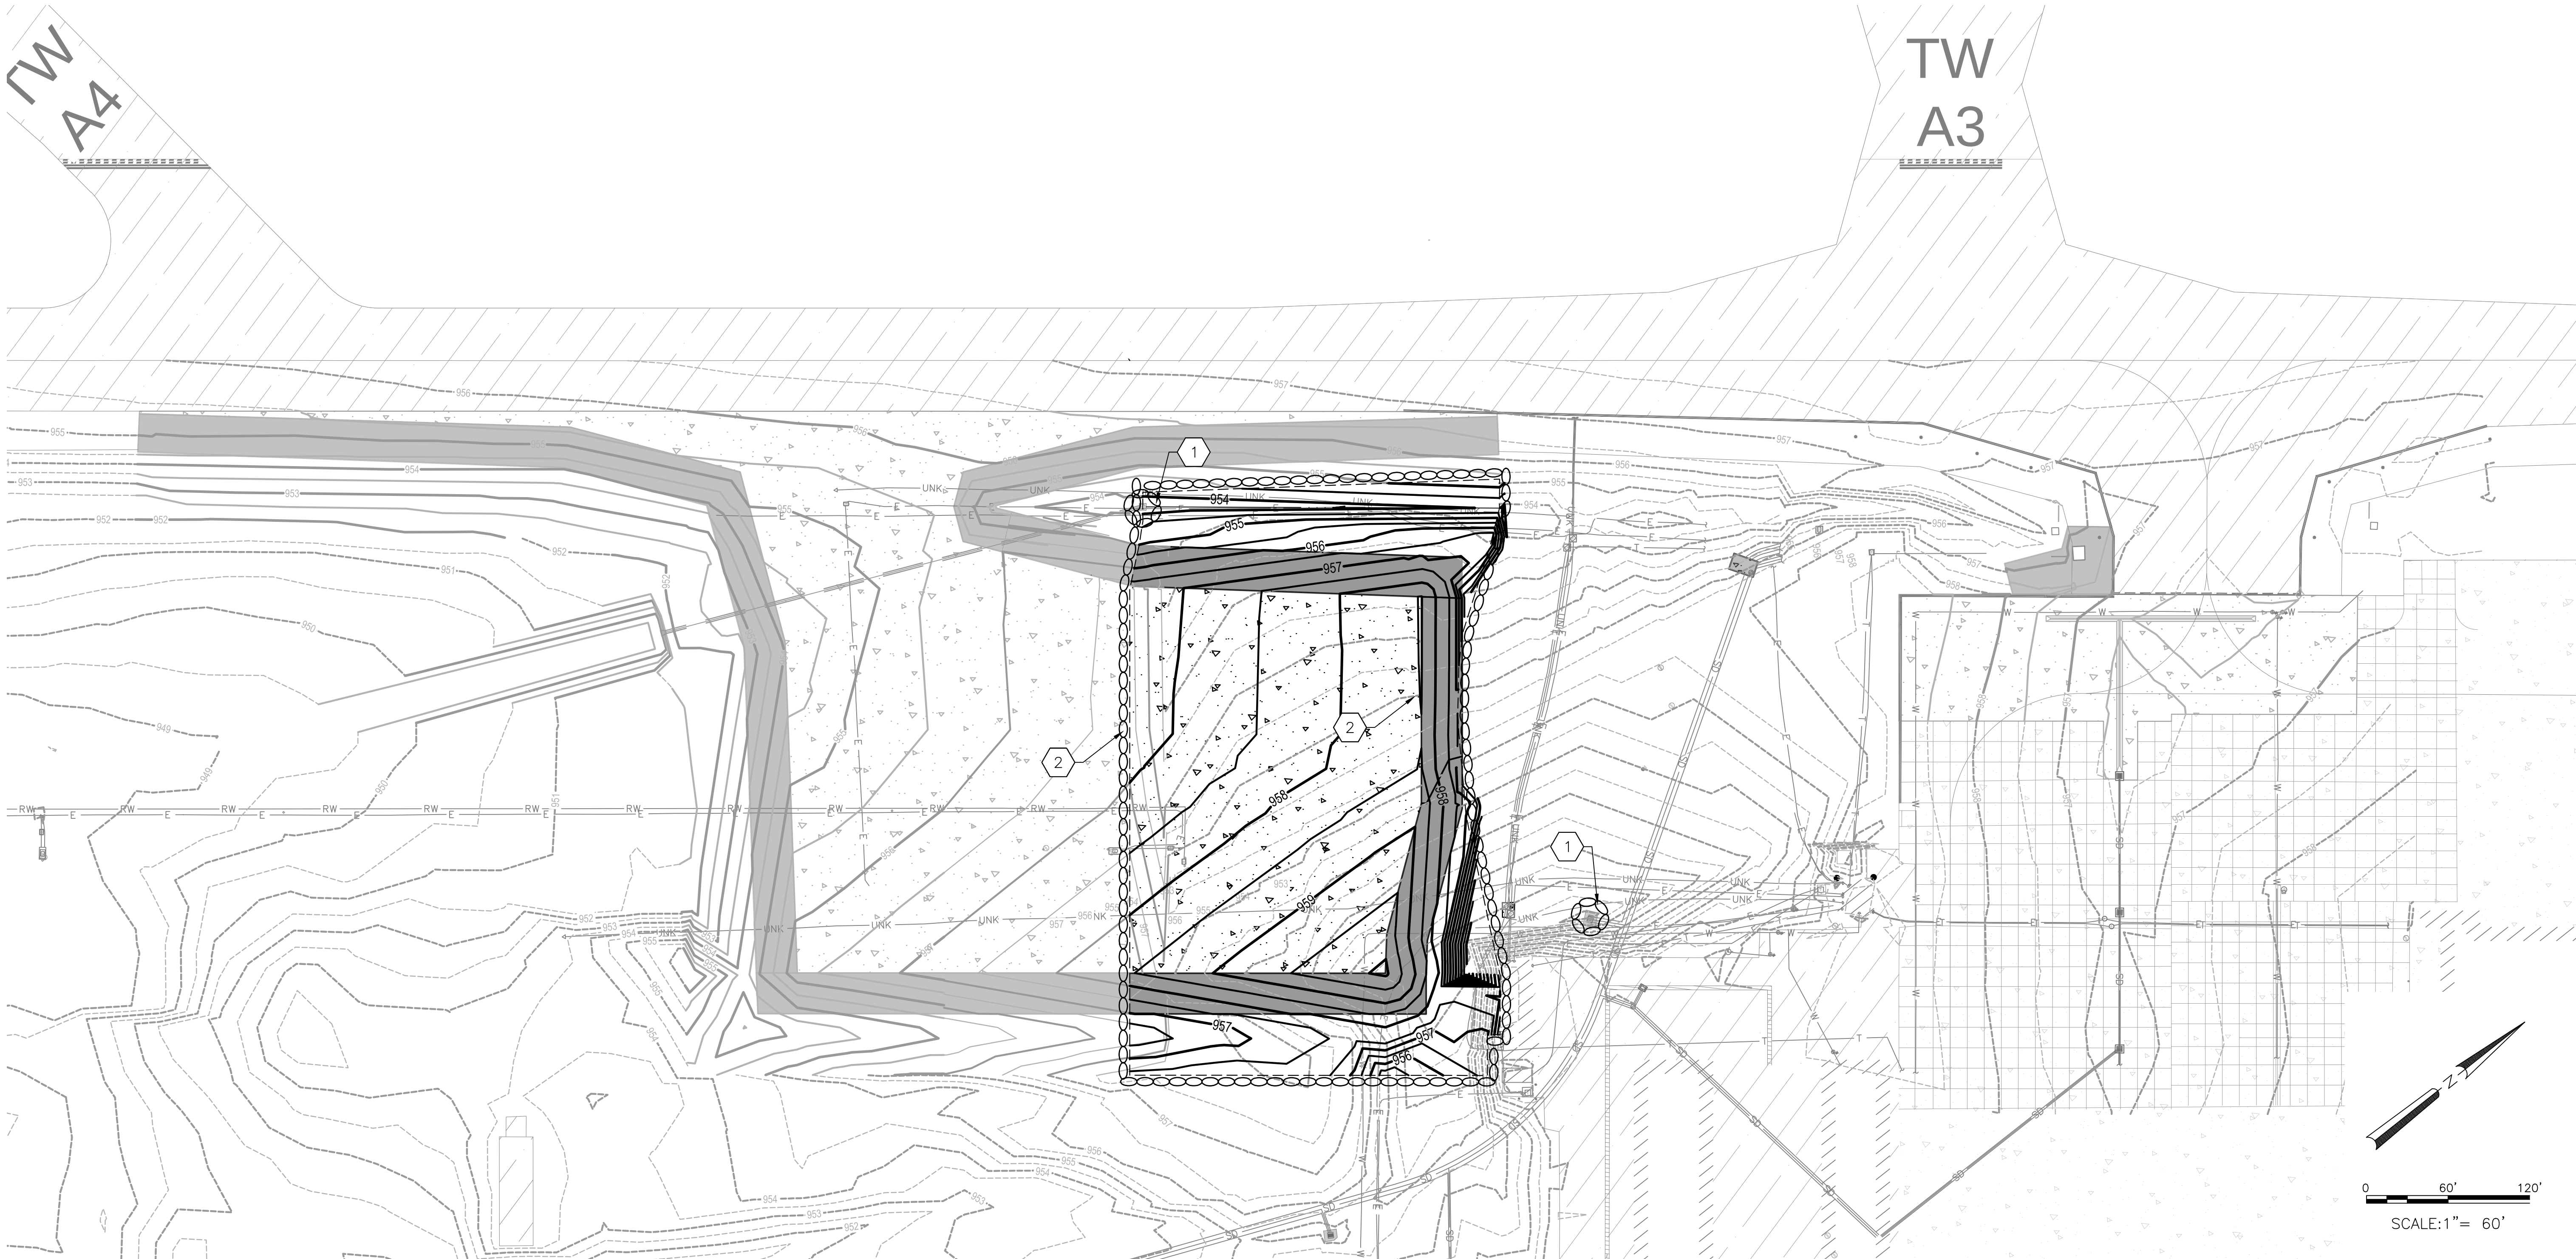

A1 GRADING AND DRAINAGE PLAN
SCALE: 1" = 60'

PER CITY OF PHOENIX CODE CHAPTER 2, SECTION 2-28, THESE PLANS ARE FOR OFFICIAL USE ONLY AND MAY NOT BE SHARED WITH OTHERS EXCEPT AS REQUIRED TO FULFILL THE OBLIGATIONS OF CONTRACTOR'S CONTRACT WITH THE CITY OF PHOENIX.

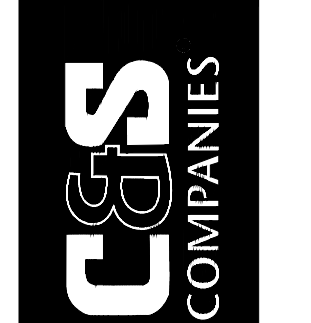

NO.	REVISIONS / SUBMISSIONS	DATE



PHOENIX GOODYEAR AIRPORT
NEW APRON AND TAXIWAY CONNECTOR


Designed by: RB	CIP NO.(S): AV41000077 FAA/ADOT
Drawn by: RB	
Checked by: LM	
Date: February 2023	
Dwg scale:	

Sheet Overview Title


EROSION CONTROL PLAN
BID ALT 3

Sheet Reference Number:
GC204


Sheet 11 of 61

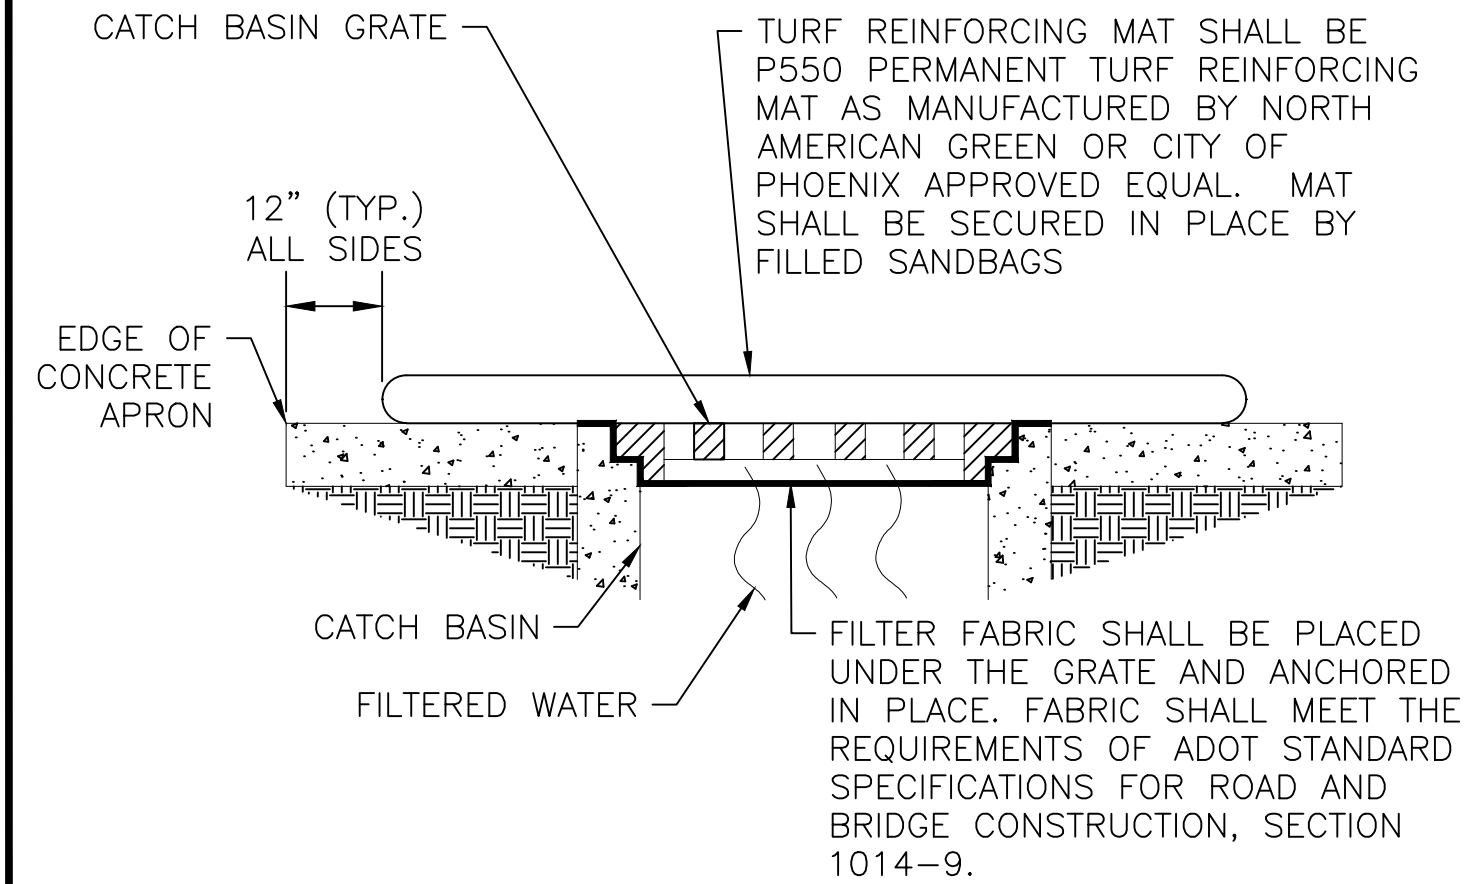

D1 STORM DRAIN INLET PROTECTION
NOT TO SCALE

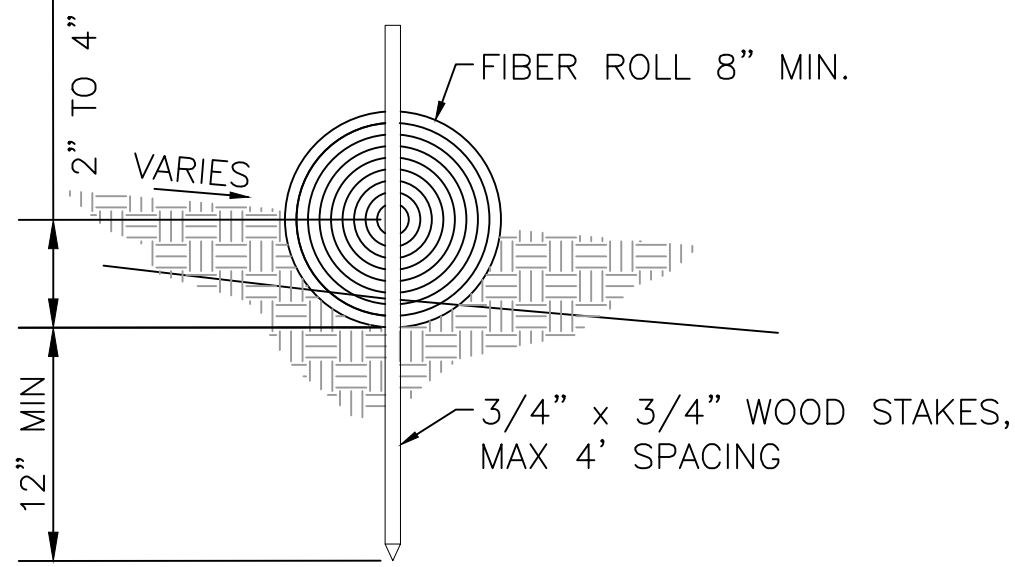


D2 TYPE 1 FIBER ROLL DETAIL
NOT TO SCALE

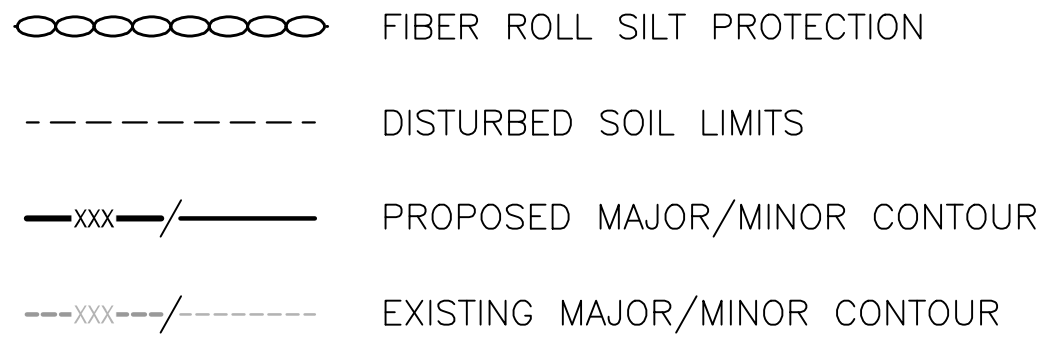

D3 LEGEND
NOT TO SCALE


- 1 CATCH BASIN INLET PROTECTION, SEE DETAIL D1, THIS SHEET.
(ALT 4) ITEM C-102.
- 2 FIBER ROLL SILT PROTECTION, SEE DETAIL D2, THIS SHEET.
(ALT 4) ITEM C-102.

D4 CONSTRUCTION NOTES
NOT TO SCALE

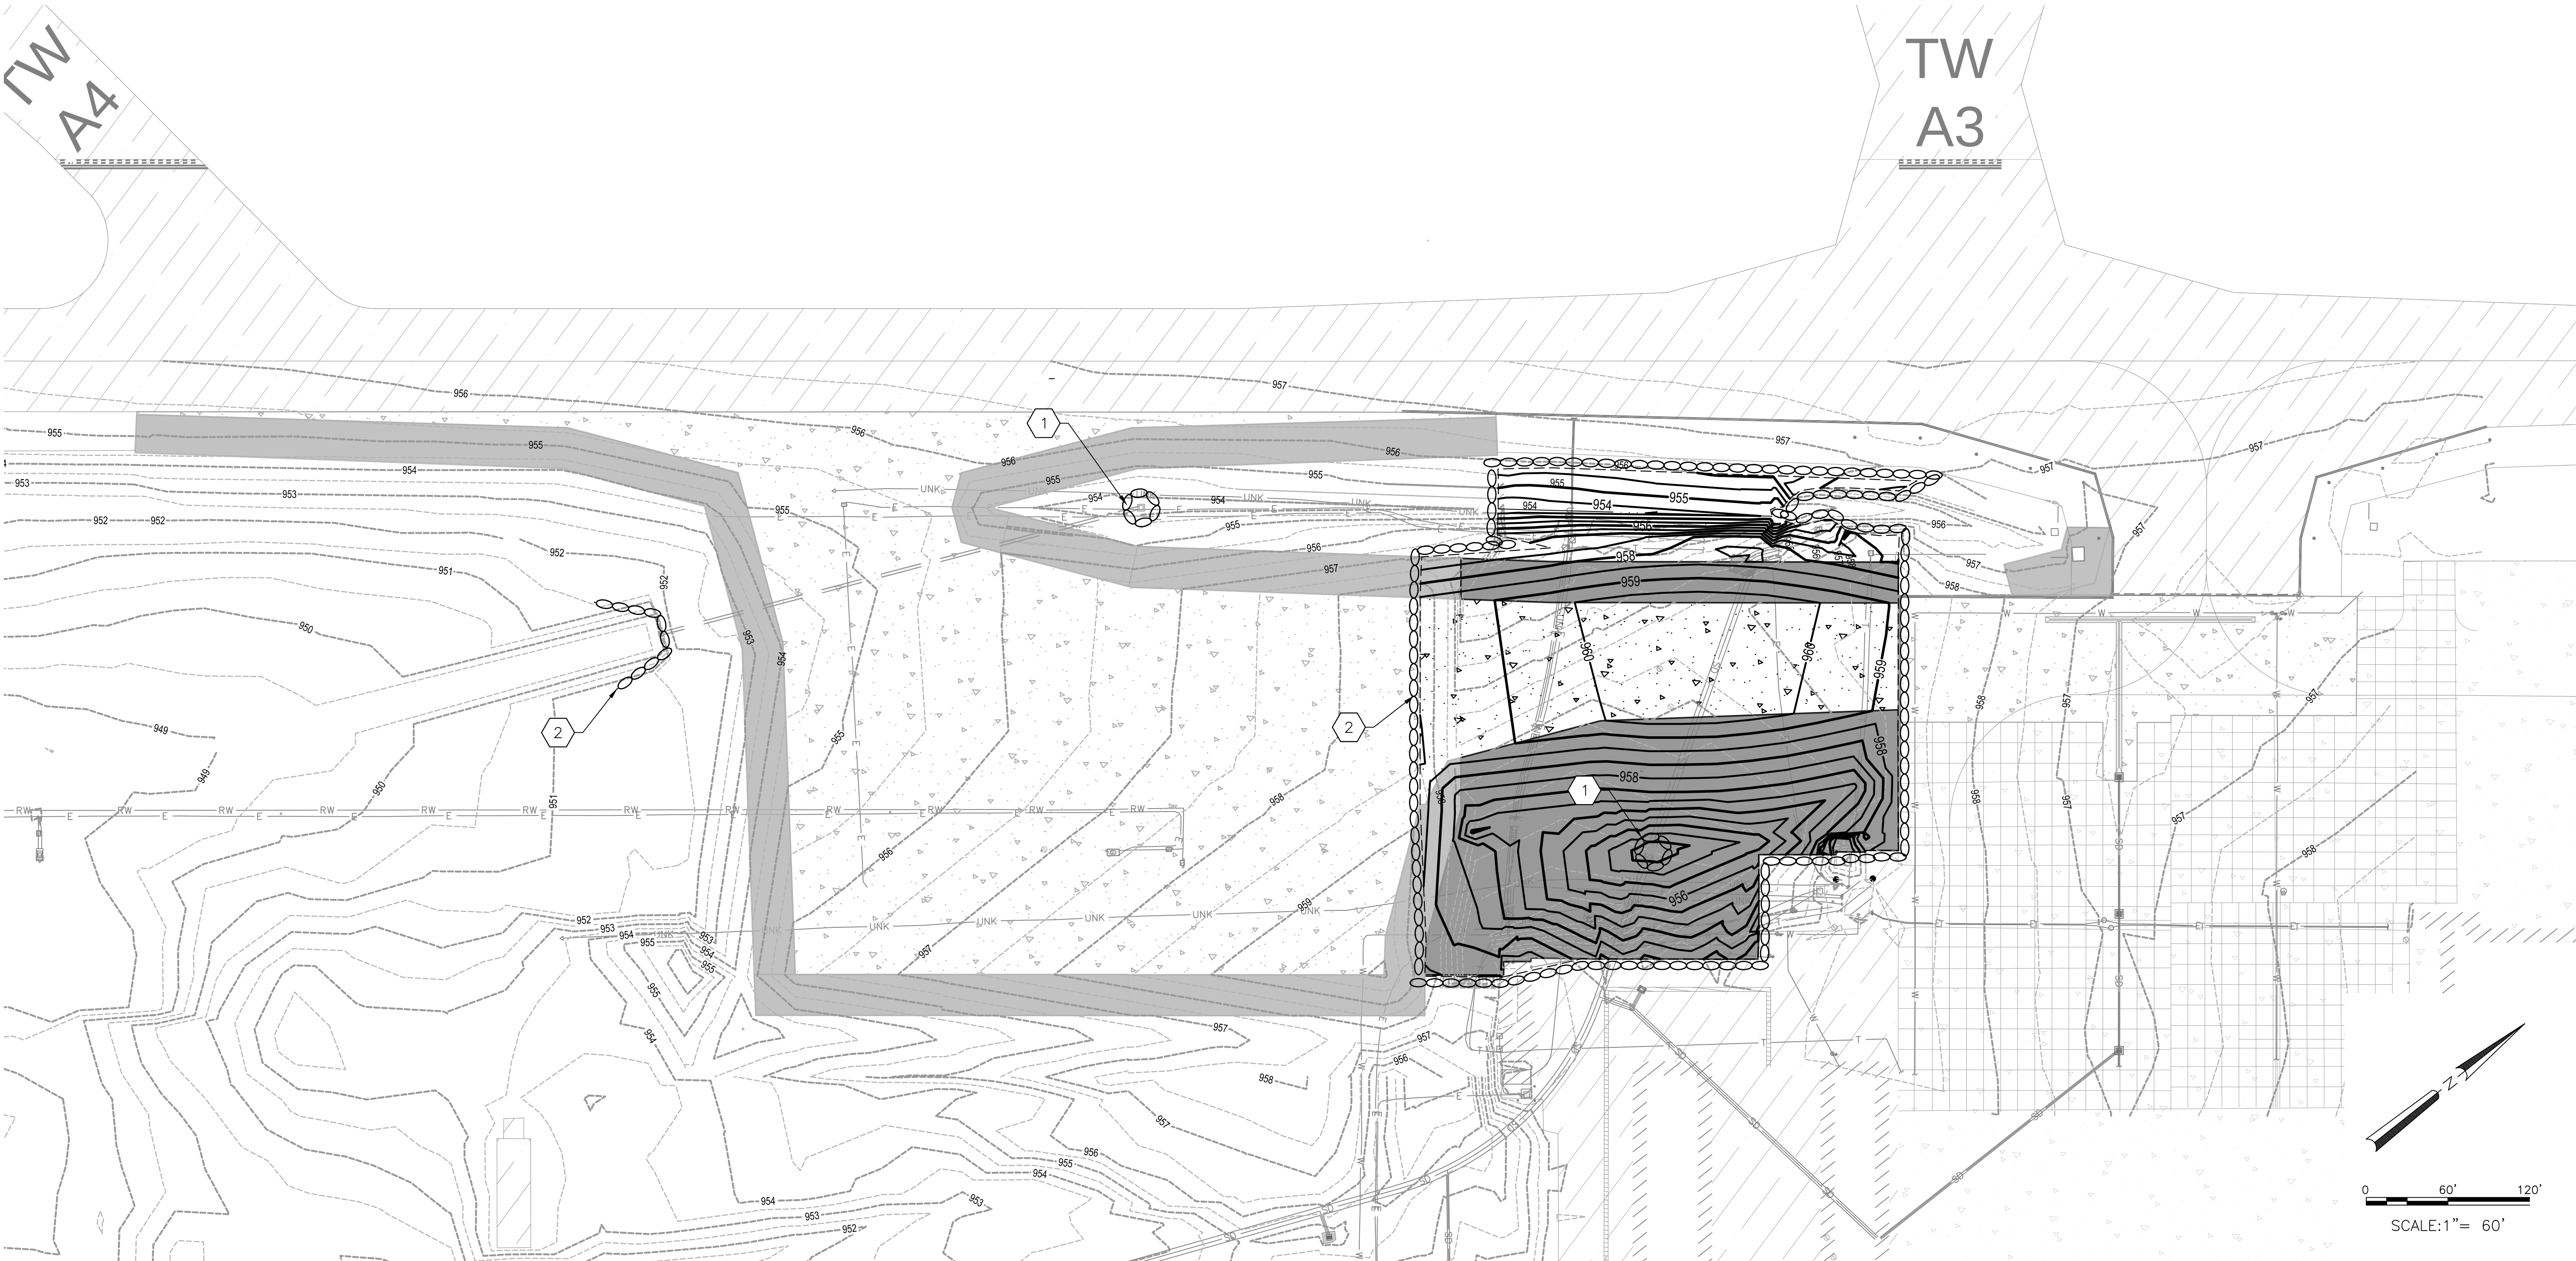

A1 GRADING AND DRAINAGE PLAN
SCALE: 1" = 60'

PER CITY OF PHOENIX CODE CHAPTER 2, SECTION 2-28, THESE PLANS ARE FOR OFFICIAL USE ONLY AND MAY NOT BE SHARED WITH OTHERS EXCEPT AS REQUIRED TO FULFILL THE OBLIGATIONS OF CONTRACTOR'S CONTRACT WITH THE CITY OF PHOENIX.

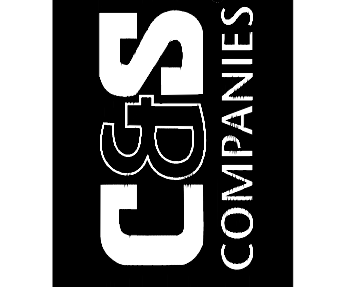


NO.	REVISIONS / SUBMISSIONS	DATE

PHX DVT CYR
CITY OF PHOENIX AVIATION DEPARTMENT
PHOENIX GOODYEAR AIRPORT
NEW APRON AND TAXIWAY CONNECTOR
AV41000077 FAA/ADOT

Designed by: RB
Drawn by: RB
Checked by: LM
Date: February 2023
Dwg scale: 1" = 60'

Sheet Overview Title
**EROSION CONTROL PLAN
BID ALT 4**

Sheet Reference Number:
GC205

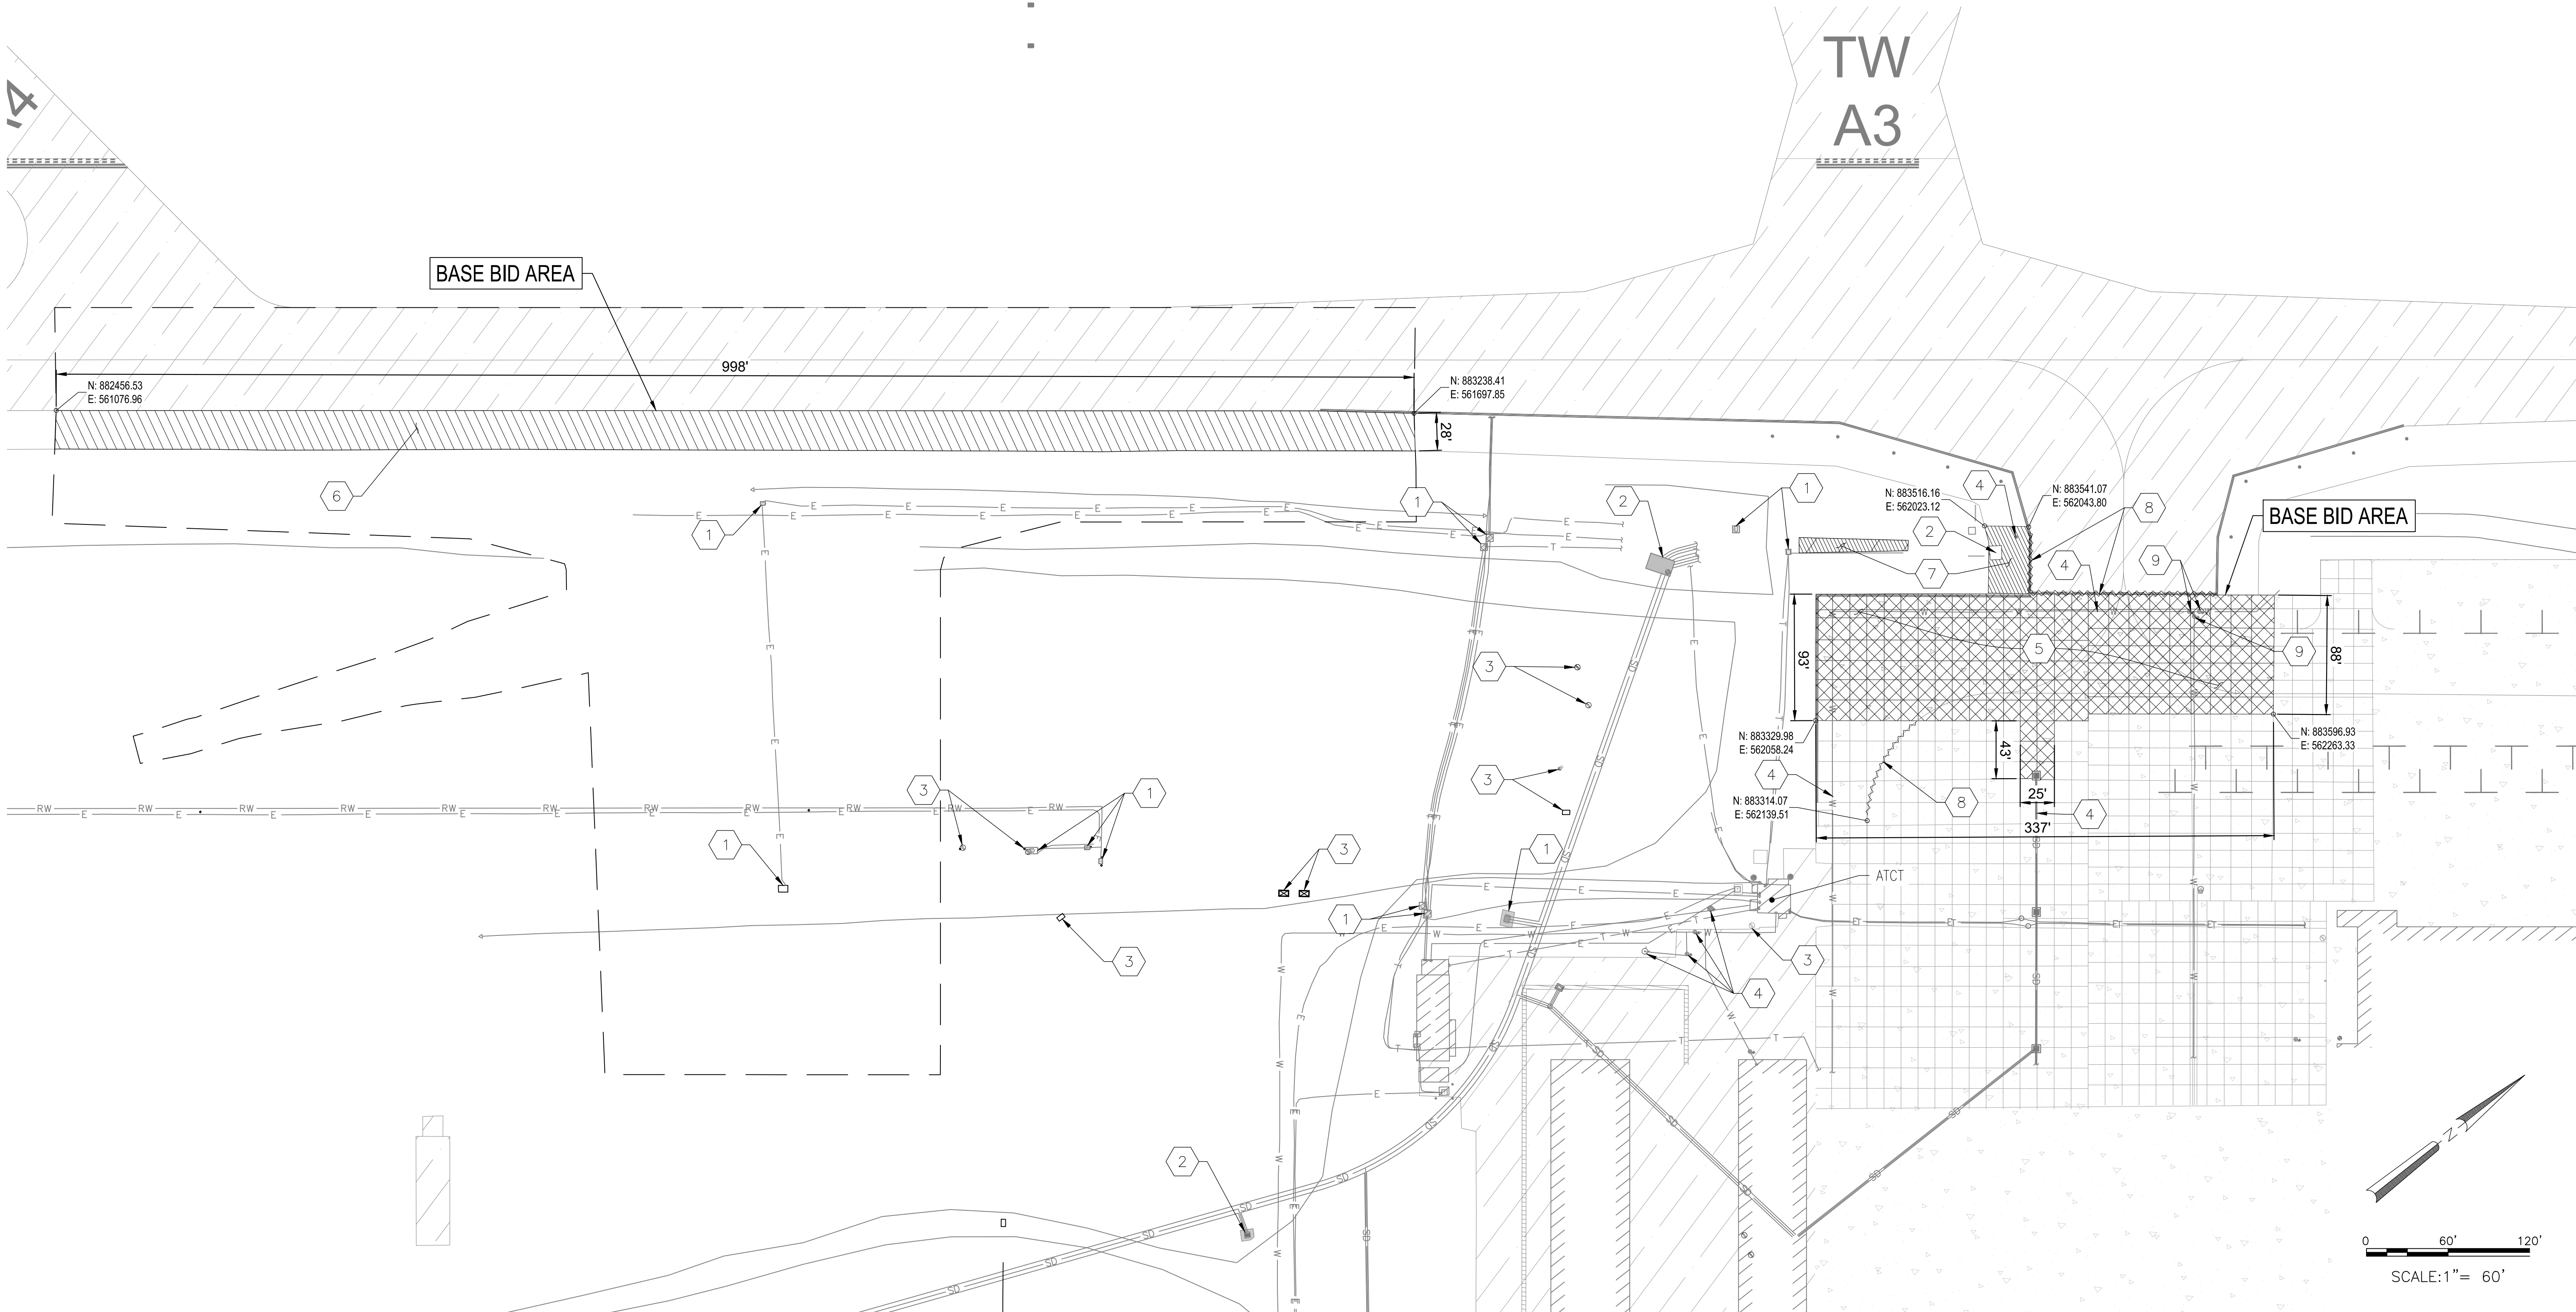

- EXISTING ASPHALTIC CONCRETE PAVEMENT
- EXISTING CONCRETE PAVEMENT
- MILL AND REMOVE ASPHALTIC CONCRETE PAVEMENT
- REMOVE EXISTING CONCRETE PAVEMENT STRUCTURAL SECTION
- EXISTING PAVEMENT MARKING REMOVAL

- FOR DEMOLITION OF ELECTRICAL ITEMS SEE AIRFIELD ELECTRICAL DEMOLITION PLAN, SHEET ED101.
- PROTECT EXISTING STRUCTURE IN PLACE.
- MONITORING WELL SYSTEM EQUIPMENT, PROTECT IN PLACE (LOCATION APPROXIMATE, CONTRACTOR TO FIELD VERIFY).
- PROTECT EXISTING UTILITIES IN PLACE.
- CONCRETE PAVEMENT REMOVAL, (BASE BID). ITEM P-101.
- COLD MILLING, FULL DEPTH APPROXIMATELY 4", (BASE BID). ITEM P-101.
- EXISTING PAVEMENT MARKING REMOVAL, (BASE BID). ITEM P-620.
- ADJUST EXISTING WATER VALVE TO GRADE PER DETAILS A3 AND A4, SHEET CP502. (BASE BID). ITEM TSP-3.

D3
NOT TO SCALE

LEGEND


D4
NOT TO SCALE

CONSTRUCTION NOTES

A1
DEMOLITION PLAN

SCALE: 1" = 60'

PER CITY OF PHOENIX CODE CHAPTER 2, SECTION 2-28. THESE PLANS ARE FOR OFFICIAL USE ONLY AND MAY NOT BE SHARED WITH OTHERS EXCEPT AS REQUIRED TO FULFILL THE OBLIGATIONS OF CONTRACTOR'S CONTRACT WITH THE CITY OF PHOENIX.

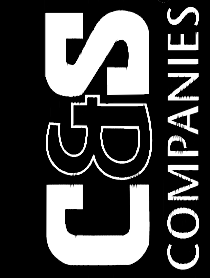

PER CITY OF PHOENIX CITY CODE CHAPTER 2, SECTION 2-28. THESE PLANS ARE FOR OFFICIAL USE ONLY AND MAY NOT BE SHARED WITH OTHERS EXCEPT AS REQUIRED TO FULFILL THE OBLIGATIONS OF YOUR CONTRACT WITH THE CITY OF PHOENIX.

PHX DVT CYR
CITY OF PHOENIX AVIATION DEPARTMENT
PHOENIX GOODYEAR AIRPORT
NEW APRON AND TAXIWAY CONNECTOR


AV41000077 FAA/ADOT

Designed by: LM
Drawn by: RB
Checked by: LM
Date: February 2023
Dwg. scale: 1"=60'

DEMOLITION PLAN
BASE BID

CD101

Sheet 13 of 61

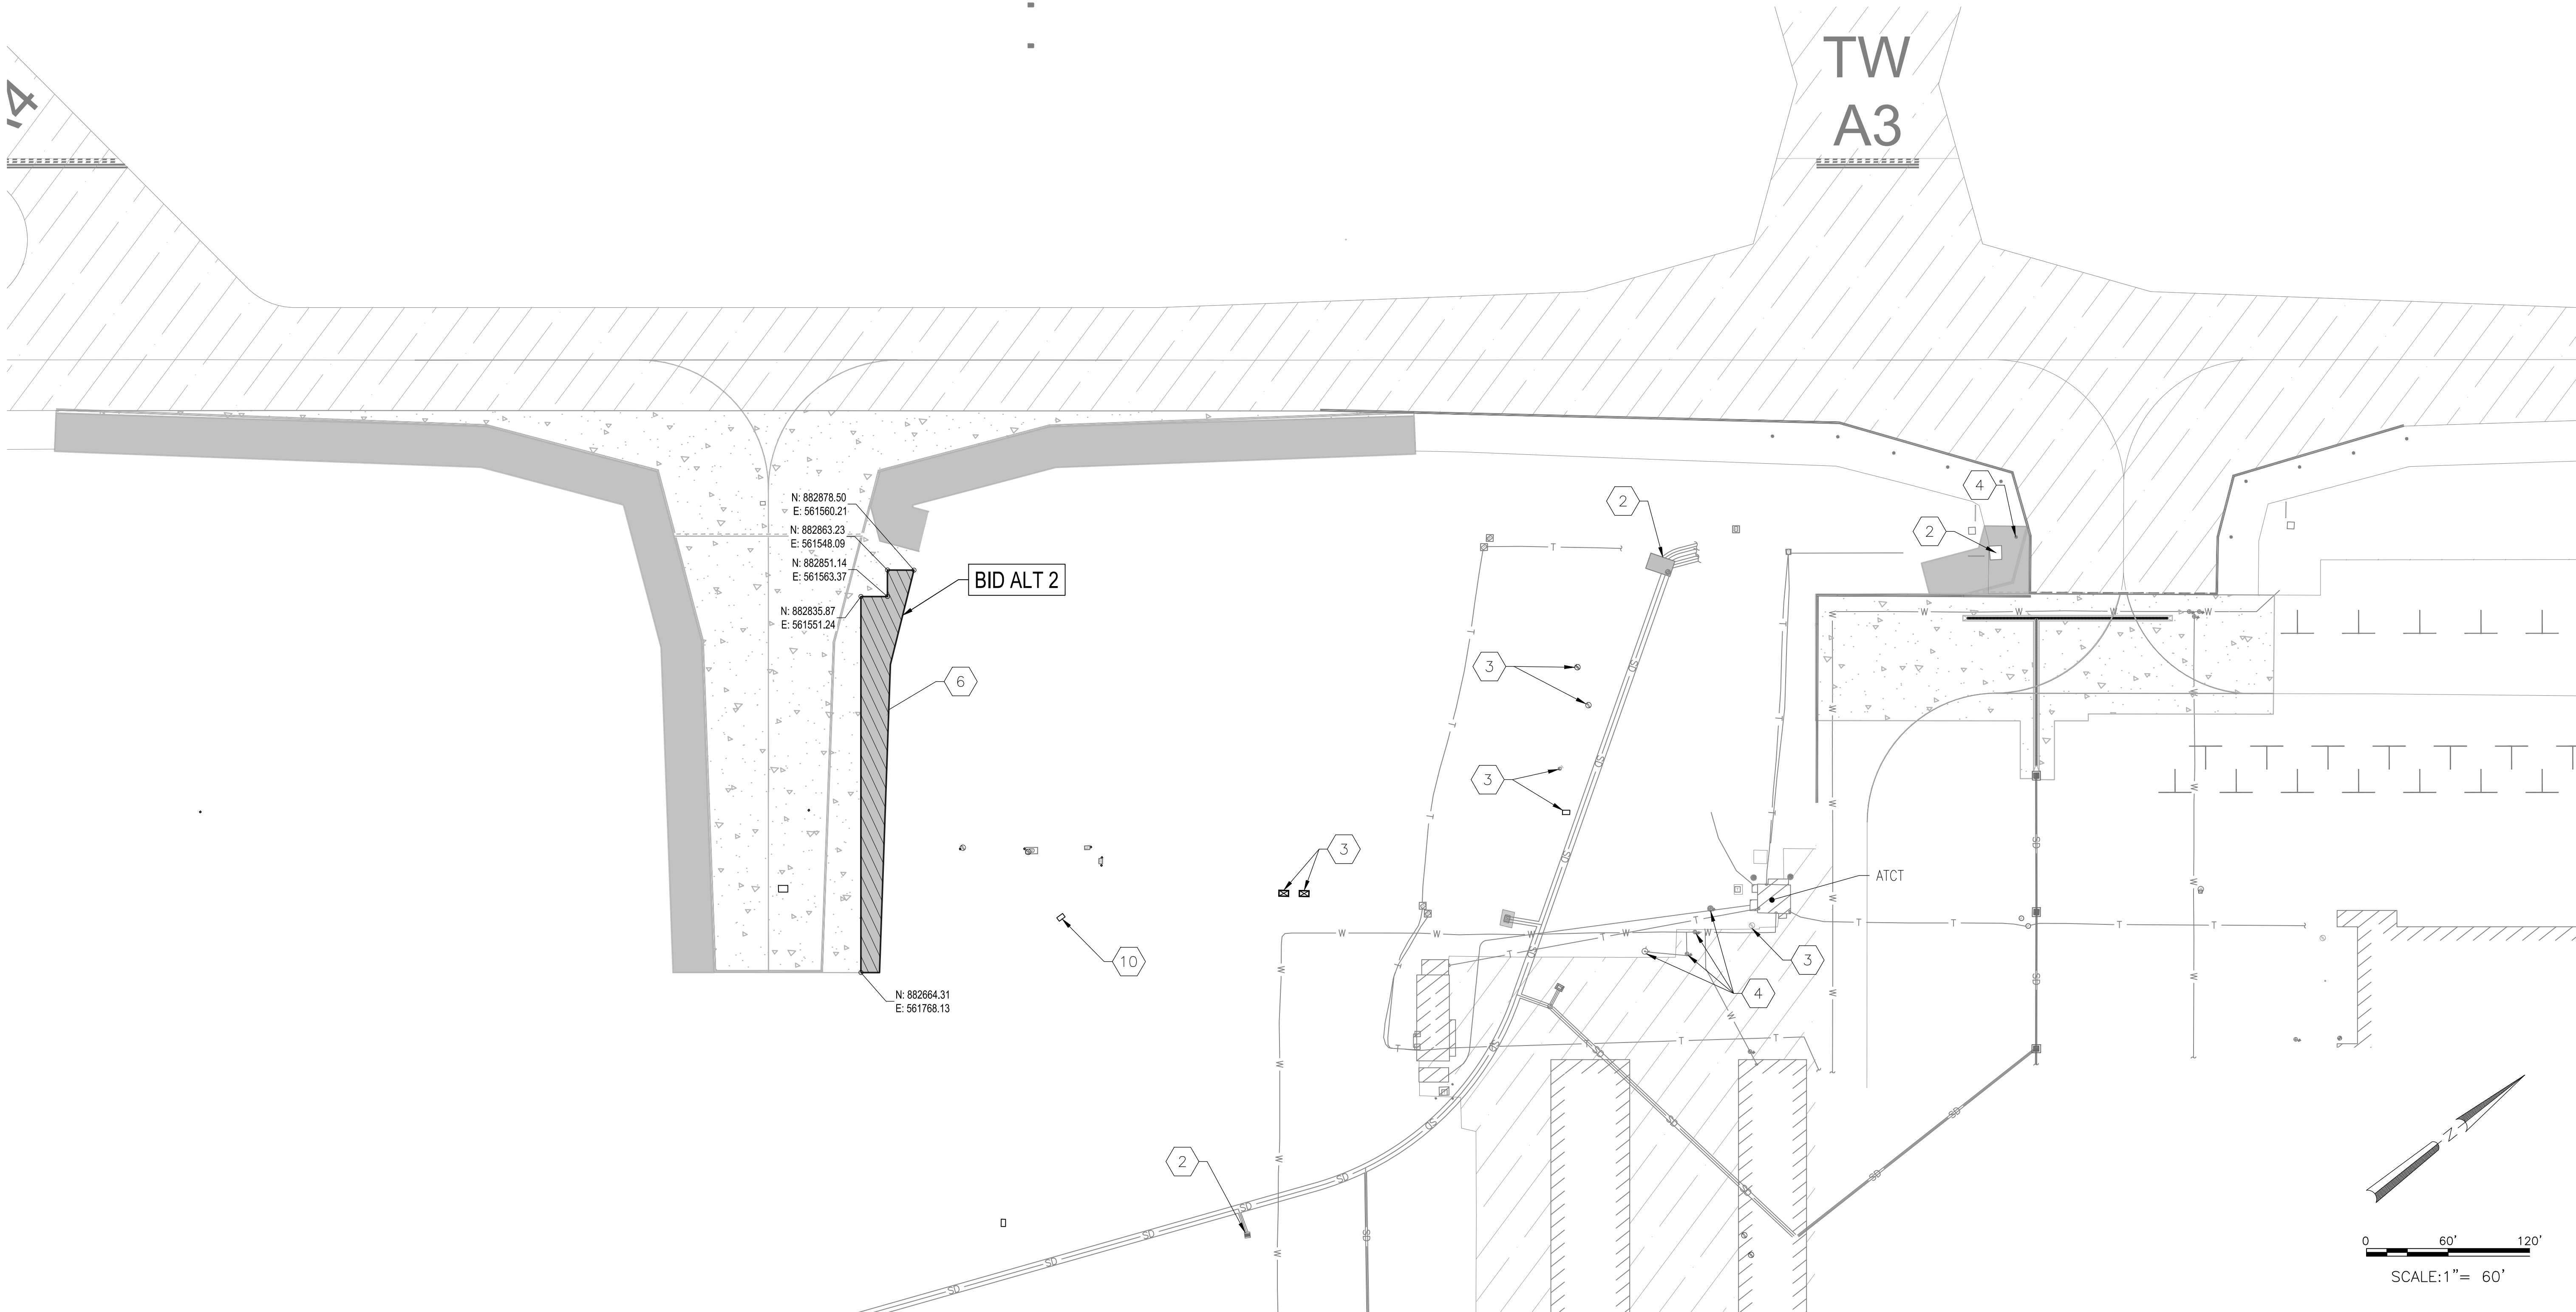

- EXISTING ASPHALTIC CONCRETE PAVEMENT
- EXISTING CONCRETE PAVEMENT
- MILL AND REMOVE ASPHALTIC CONCRETE PAVEMENT

- PROTECT EXISTING STRUCTURE IN PLACE.
- MONITORING WELL SYSTEM EQUIPMENT, PROTECT IN PLACE. (LOCATION APPROXIMATE, CONTRACTOR TO FIELD VERIFY).
- PROTECT EXISTING UTILITIES IN PLACE.
- COLD MILLING, FULL DEPTH APPROXIMATELY 4", (BID ALT 2). ITEM P-101.
- MONITORING WELL SYSTEM EQUIPMENT, INSTALL VAULT RISER DETAIL PER DETAIL A2, SHEET CP501. (LOCATION APPROXIMATE, CONTRACTOR TO FIELD VERIFY).

D3 LEGEND
NOT TO SCALE

D4 CONSTRUCTION NOTES
NOT TO SCALE

A1 DEMOLITION PLAN
SCALE: 1" = 60'

PER CITY OF PHOENIX CODE CHAPTER 2, SECTION 2-28. THESE PLANS ARE FOR OFFICIAL USE ONLY AND MAY NOT BE SHARED WITH OTHERS EXCEPT AS REQUIRED TO FULFILL THE OBLIGATIONS OF CONTRACTOR'S CONTRACT WITH THE CITY OF PHOENIX.

PER CITY OF PHOENIX CITY CODE CHAPTER 2, SECTION 2-28. THESE PLANS ARE FOR OFFICIAL USE ONLY AND MAY NOT BE SHARED WITH OTHERS EXCEPT AS REQUIRED TO FULFILL THE OBLIGATIONS OF YOUR CONTRACT WITH THE CITY OF PHOENIX.

NO.	REVISIONS / SUBMISSIONS	DATE

PHX DVT CYR
CITY OF PHOENIX AVIATION DEPARTMENT
PHOENIX GOODYEAR AIRPORT
NEW APRON AND TAXIWAY CONNECTOR
AV41000077 FAA/ADOT


Designed by: LM
Drawn by: RB
Checked by: LM
Date: February 2023
Dwg. scale: 1"=60'

Sheet Overview Title

DEMOLITION PLAN
BID ALT 2


Sheet Reference Number:
CD-102

Sheet 14 of 61

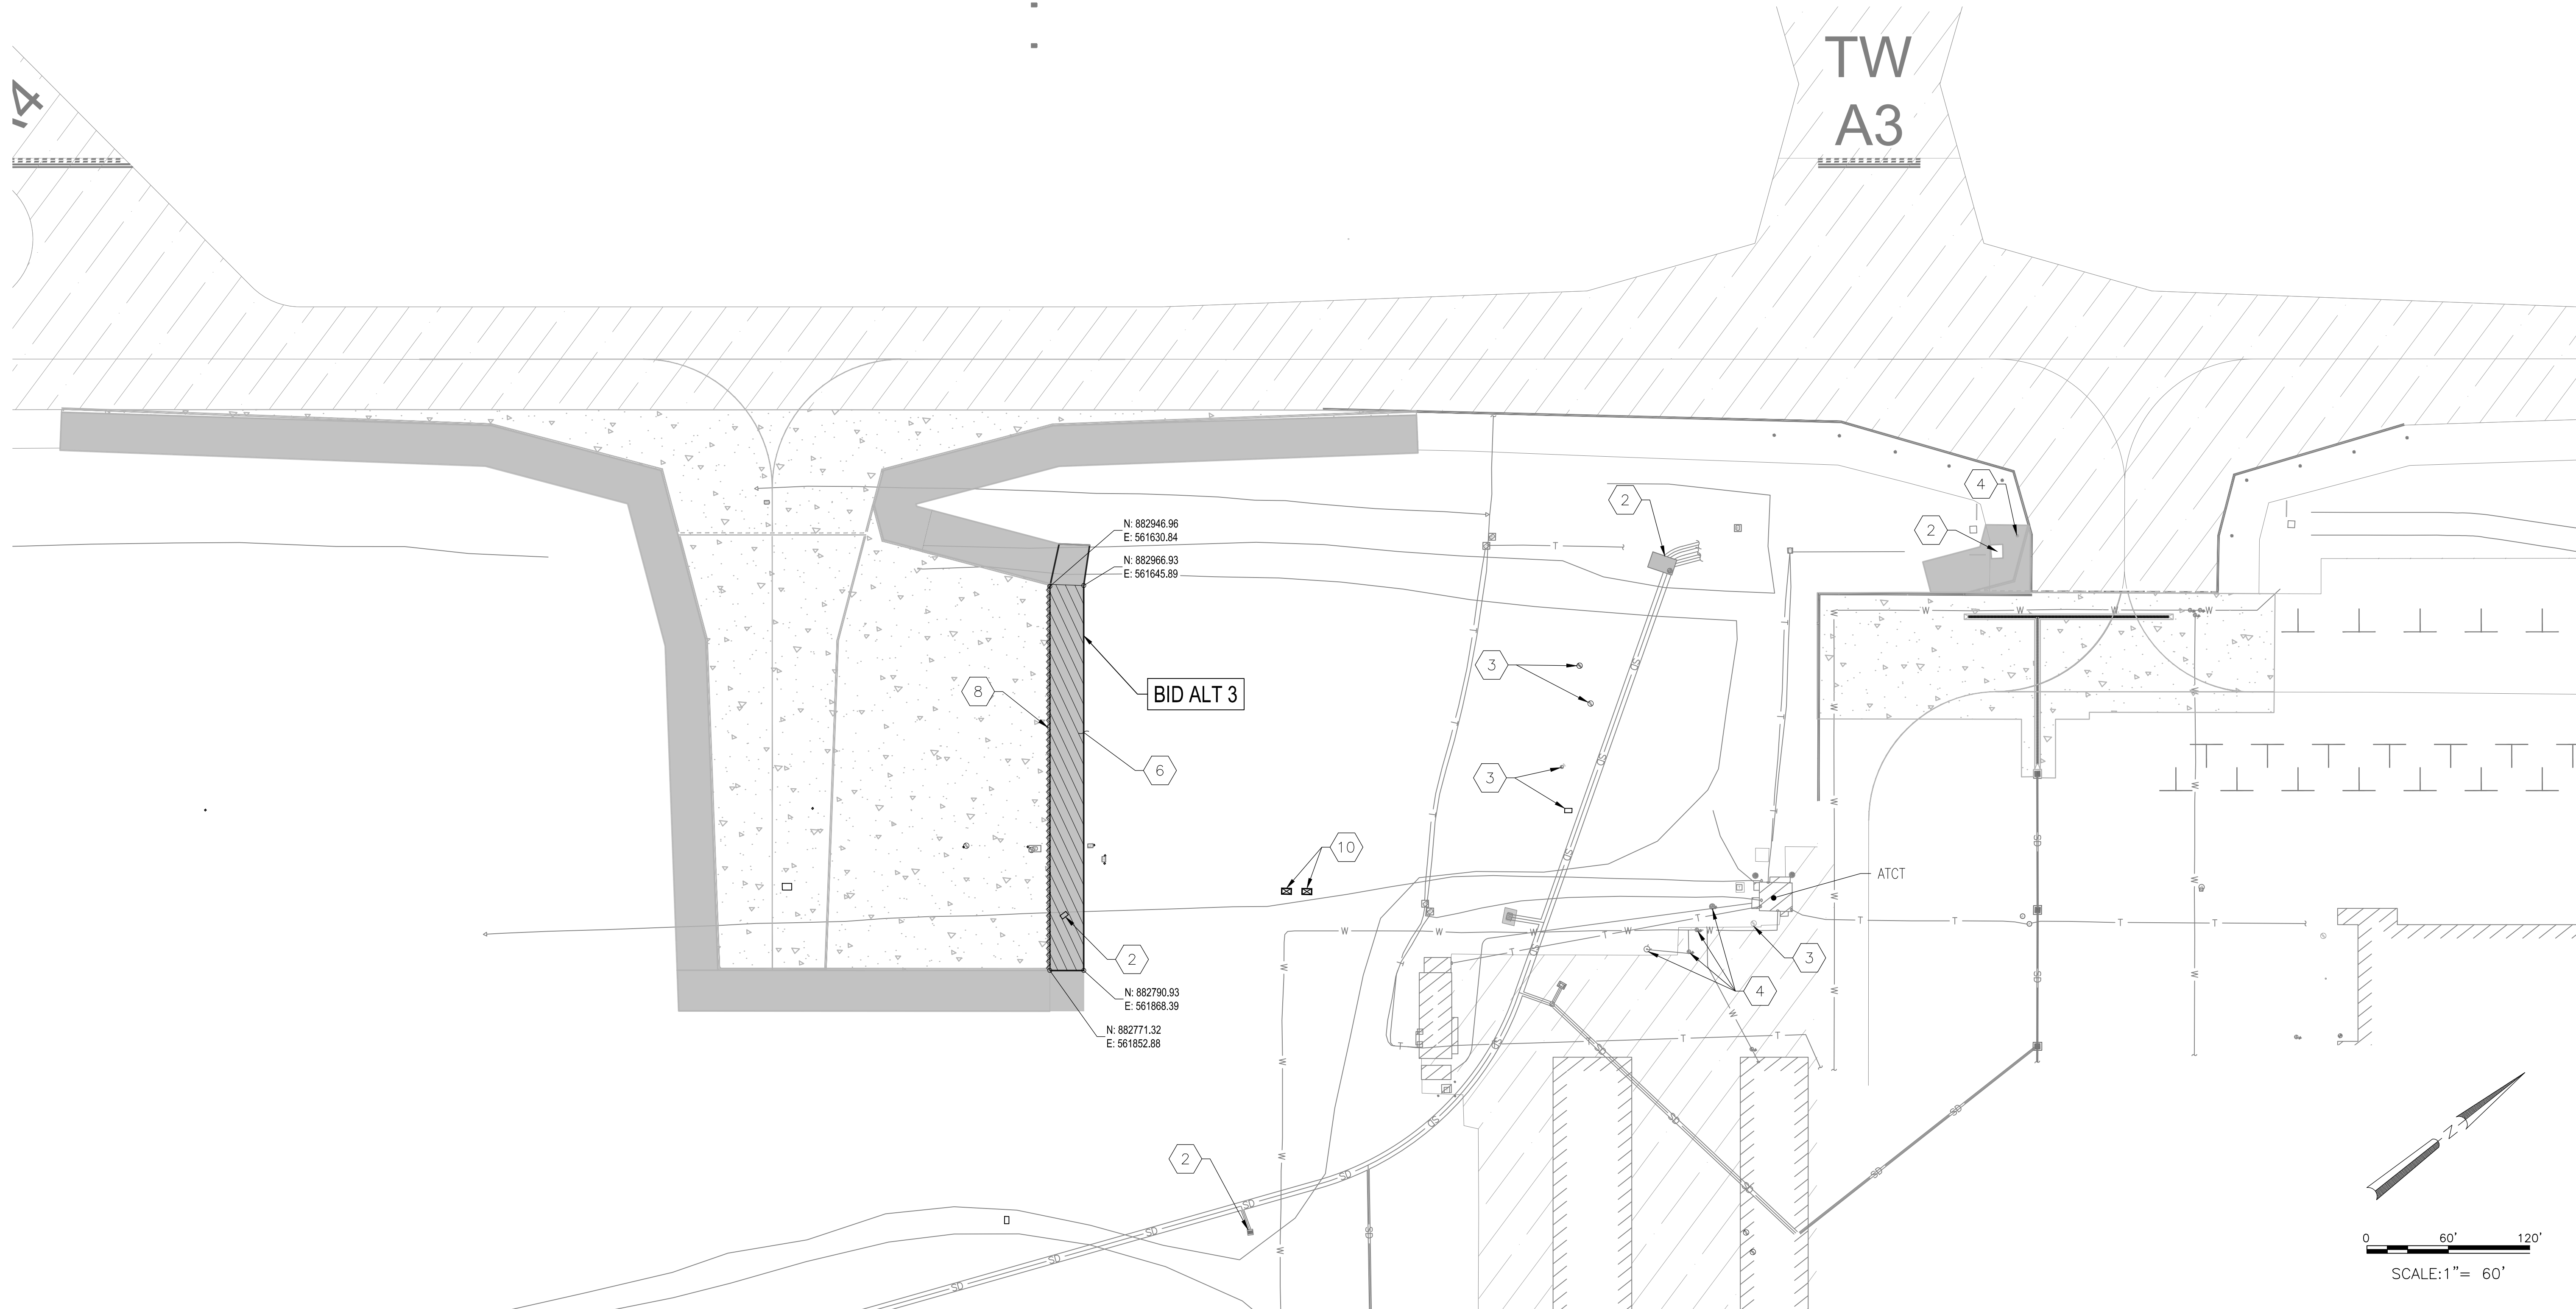


EXISTING ASPHALTIC CONCRETE PAVEMENT EXISTING CONCRETE PAVEMENT MILL AND REMOVE ASPHALTIC CONCRETE PAVEMENT EXISTING PAVEMENT MARKING REMOVAL	2 PROTECT EXISTING STRUCTURE IN PLACE. 3 MONITORING WELL SYSTEM EQUIPMENT, PROTECT IN PLACE (LOCATION APPROXIMATE, CONTRACTOR TO FIELD VERIFY). 4 PROTECT EXISTING UTILITIES IN PLACE. 6 COLD MILLING, FULL DEPTH APPROXIMATELY 4", (BID ALT 3). ITEM P-101. 8 EXISTING PAVEMENT MARKING REMOVAL, (BID ALT 3). ITEM P-620. 10 MONITORING WELL SYSTEM EQUIPMENT, INSTALL VAULT RISER PER DETAIL A2, SHEET CP501. (LOCATION APPROXIMATE, CONTRACTOR TO FIELD VERIFY).
D3 LEGEND NOT TO SCALE	D4 CONSTRUCTION NOTES NOT TO SCALE

PER CITY OF PHOENIX CODE CHAPTER 2, SECTION 2-28. THESE PLANS ARE FOR OFFICIAL USE ONLY AND MAY NOT BE SHARED WITH OTHERS EXCEPT AS REQUIRED TO FULFILL THE OBLIGATIONS OF CONTRACTOR'S CONTRACT WITH THE CITY OF PHOENIX.

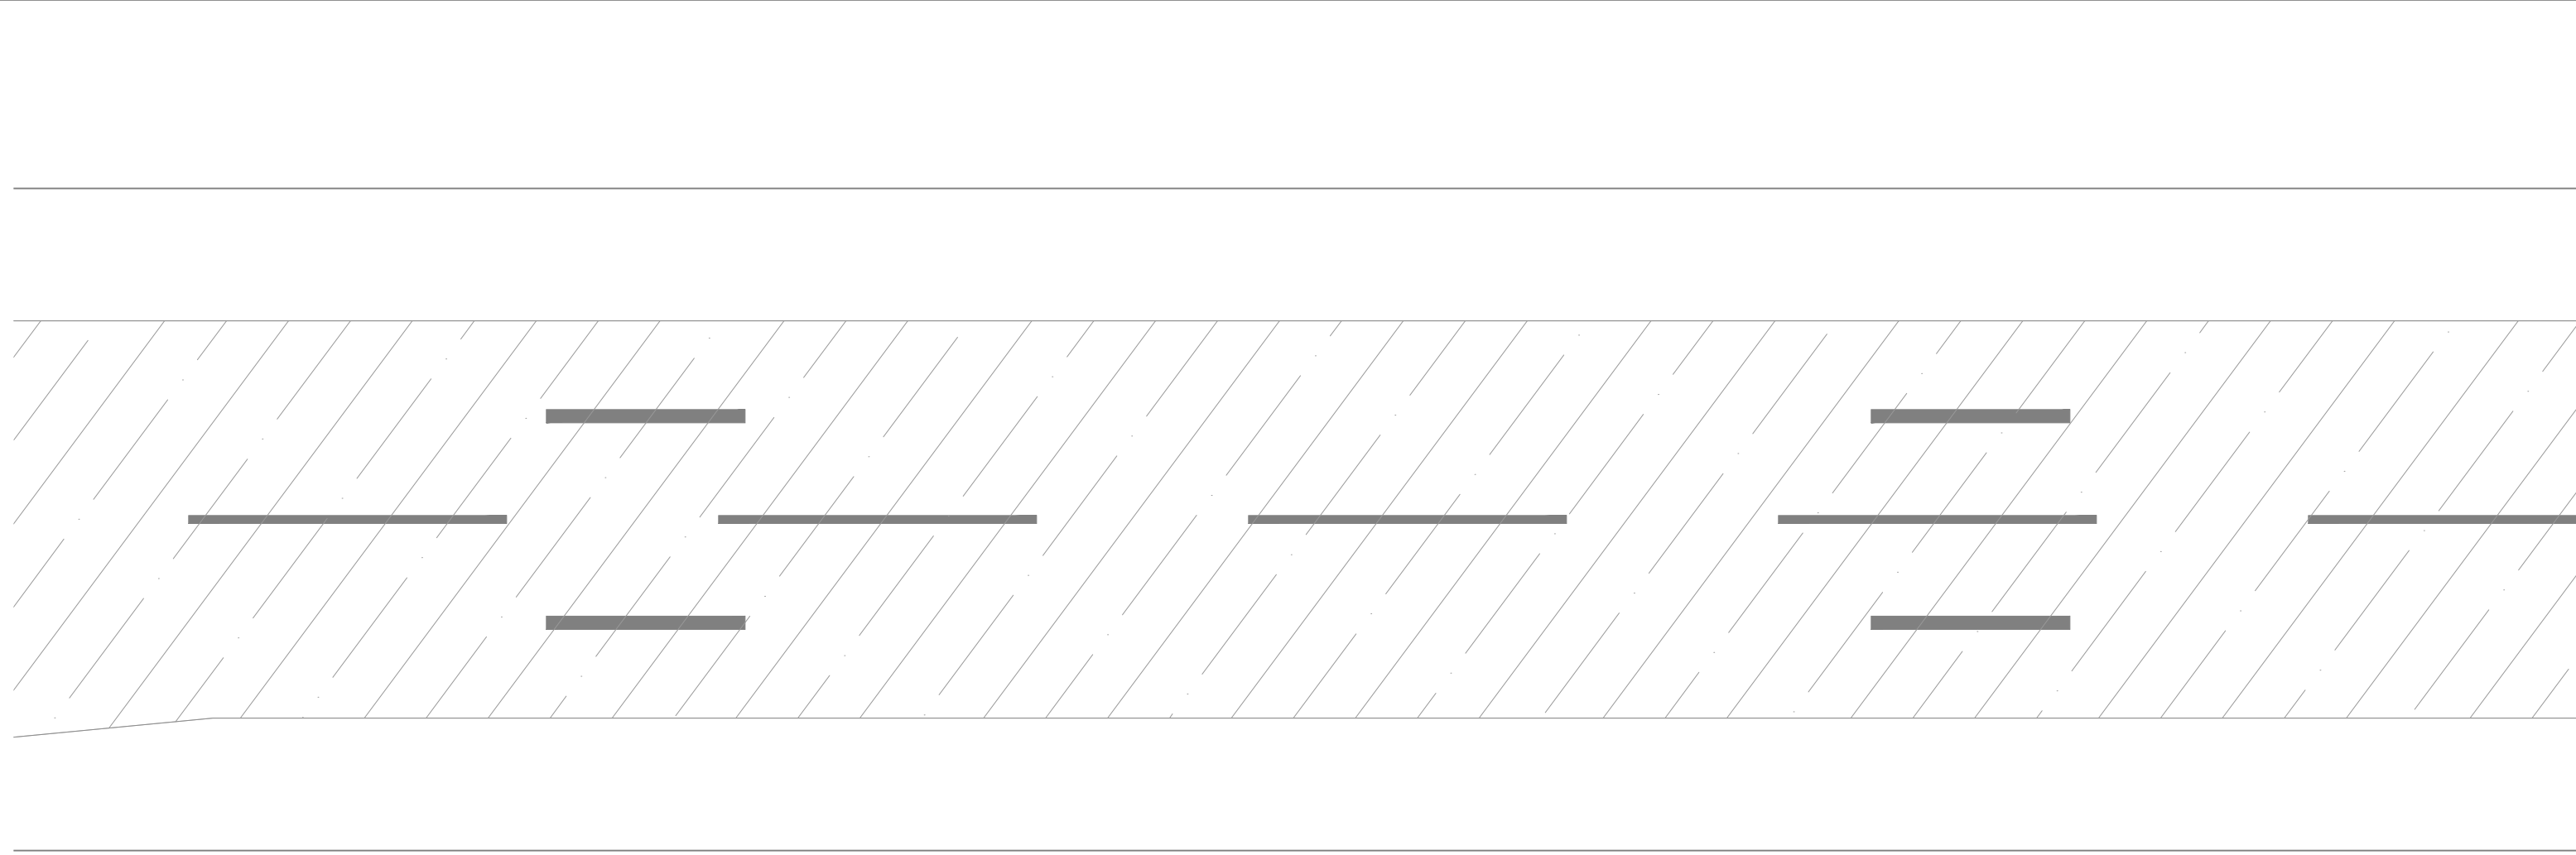

D3	LEGEND	NOT TO SCALE	D4	CONSTRUCTION NOTES	NOT TO SCALE

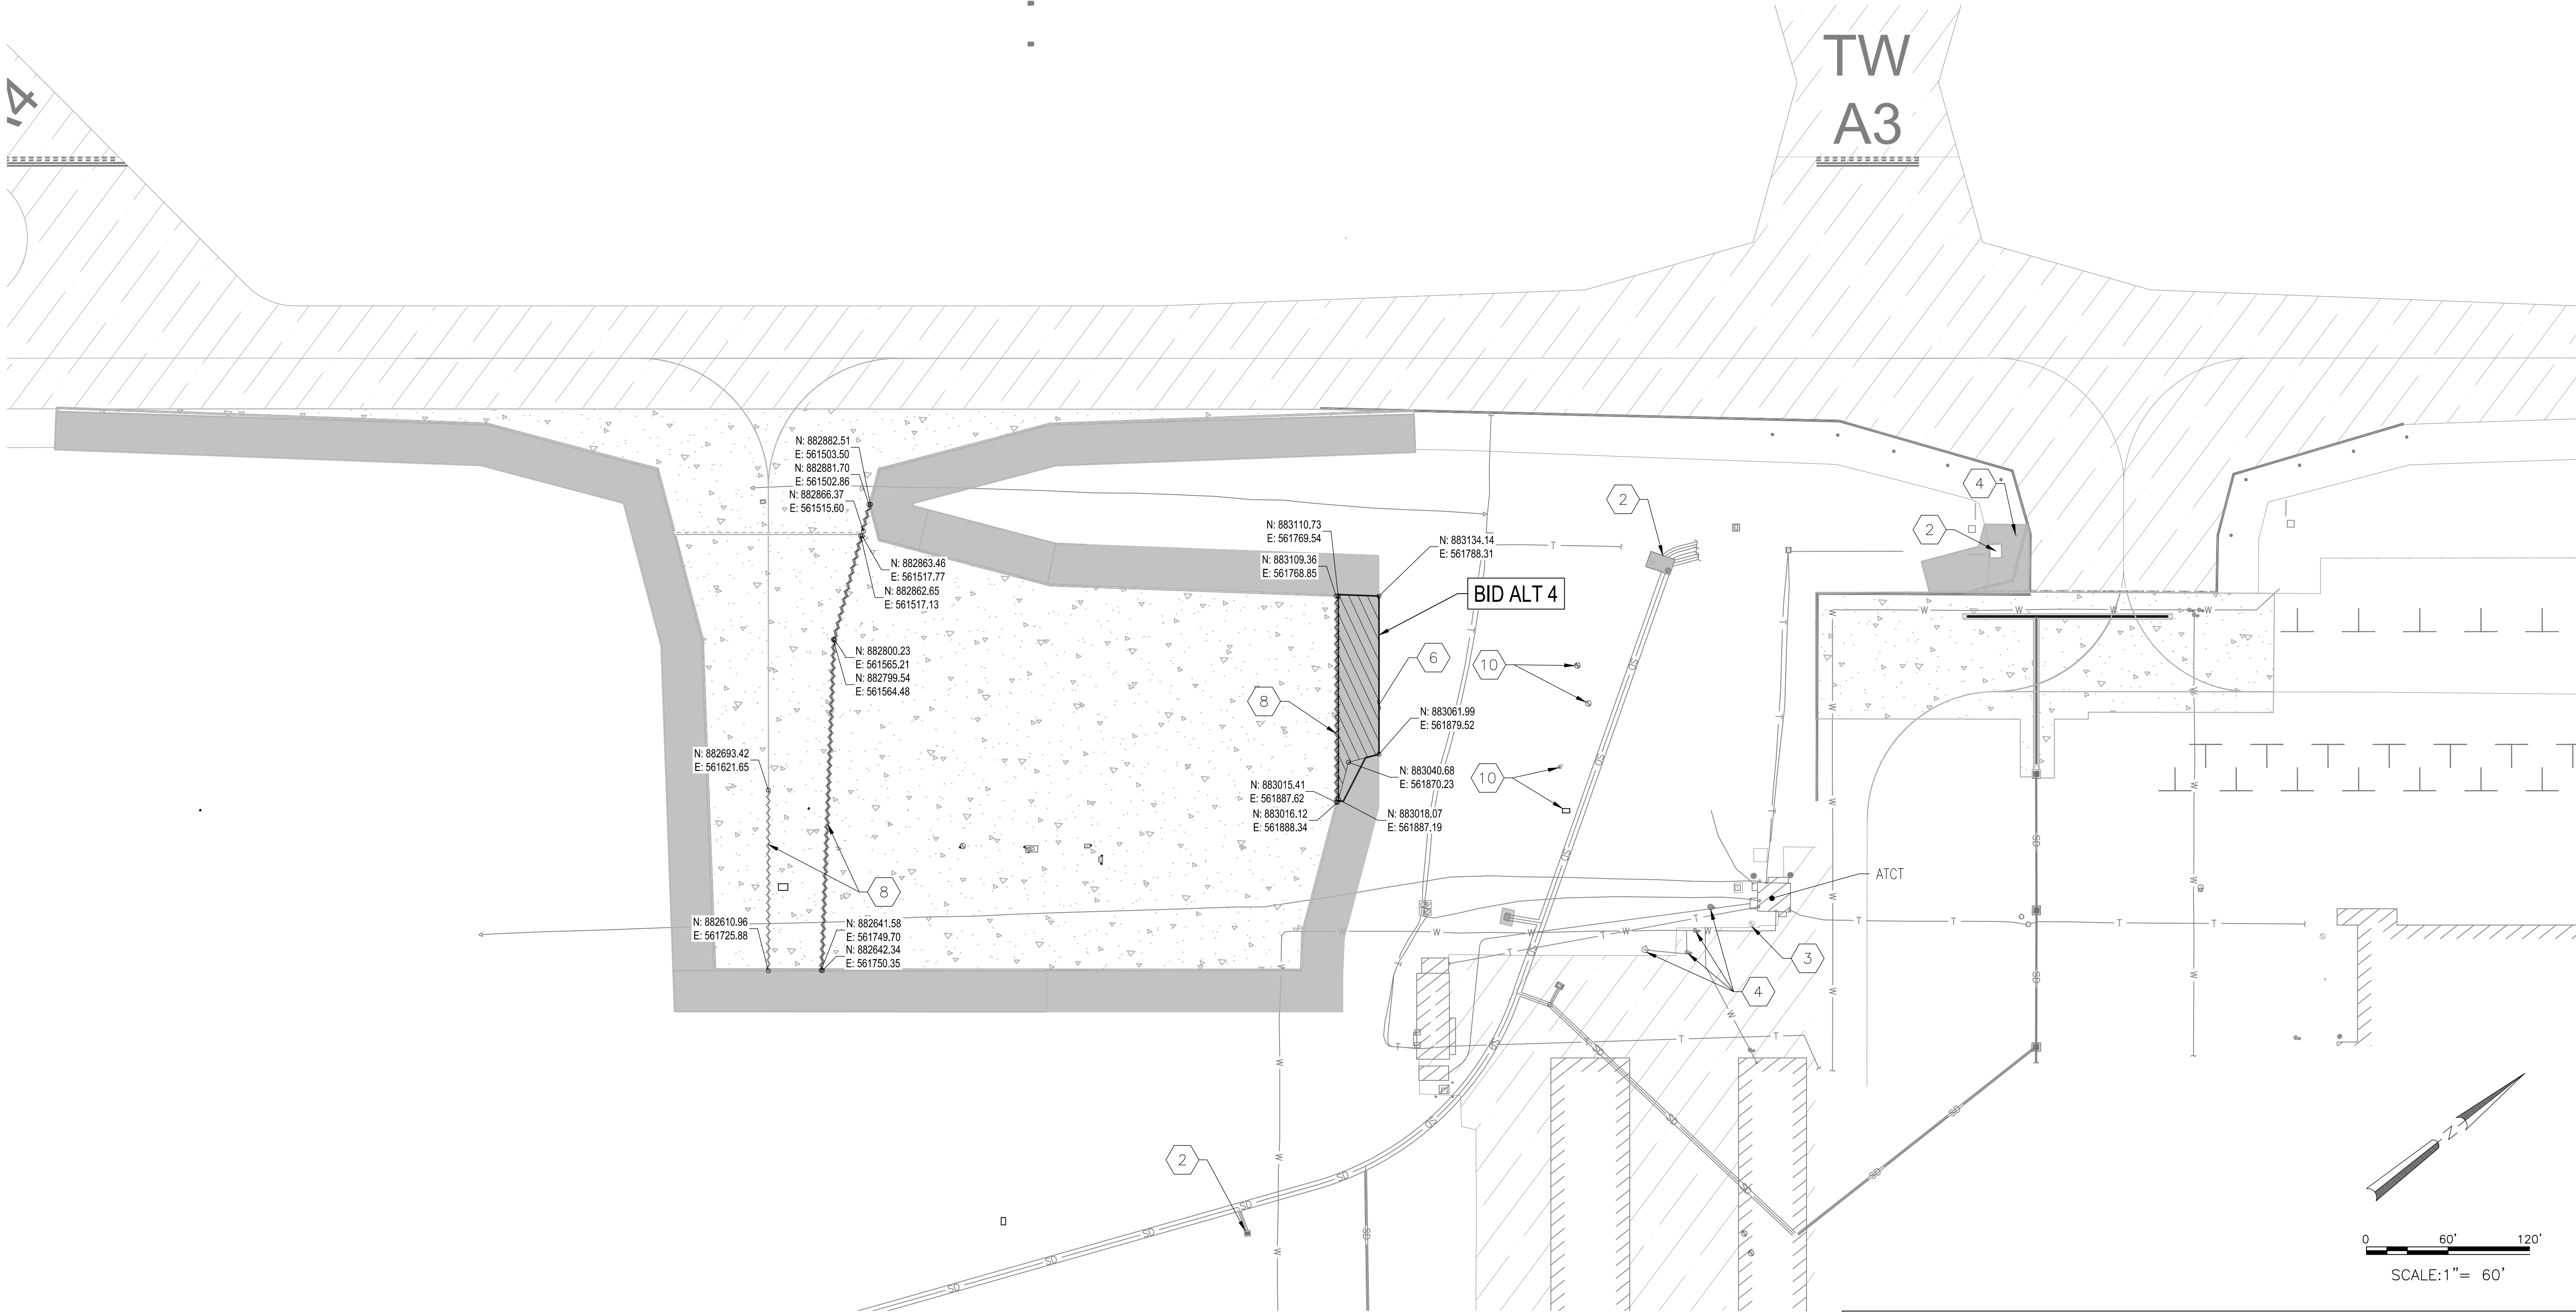

PER CITY OF PHOENIX CODE CHAPTER 2, SECTION 2-28, THESE PLANS ARE FOR OFFICIAL USE ONLY AND MAY NOT BE SHARED WITH OTHERS EXCEPT AS REQUIRED TO FULFILL THE OBLIGATIONS OF CONTRACTOR'S CONTRACT WITH THE CITY OF PHOENIX.

PER CITY OF PHOENIX CITY CODE CHAPTER 2, SECTION 2-28, THESE PLANS ARE FOR OFFICIAL USE ONLY AND MAY NOT BE SHARED WITH OTHERS EXCEPT AS REQUIRED BY THE CONTRACTOR'S CONTRACT WITH THE CITY OF PHOENIX.	NO.	REVISIONS /	SUBMISSIONS	DATE

PHX DVT CYR
CITY OF PHOENIX AVIATION DEPARTMENT
PHOENIX GOODYEAR AIRPORT
NEW APRON AND TAXIWAY CONNECTOR
AV41000077 FAA/ADOT

Designed by: LM	Drawn by: RB
Checked by: LM	Date: February 2023
Dwg. scale:	


DEMOLITION PLAN
BID ALT 4

Sheet Reference Number:

CD-104

C&S COMPANIES
Professional Engineer
LANCE R. MCINTOSH
33442
Exp. 3-31-23



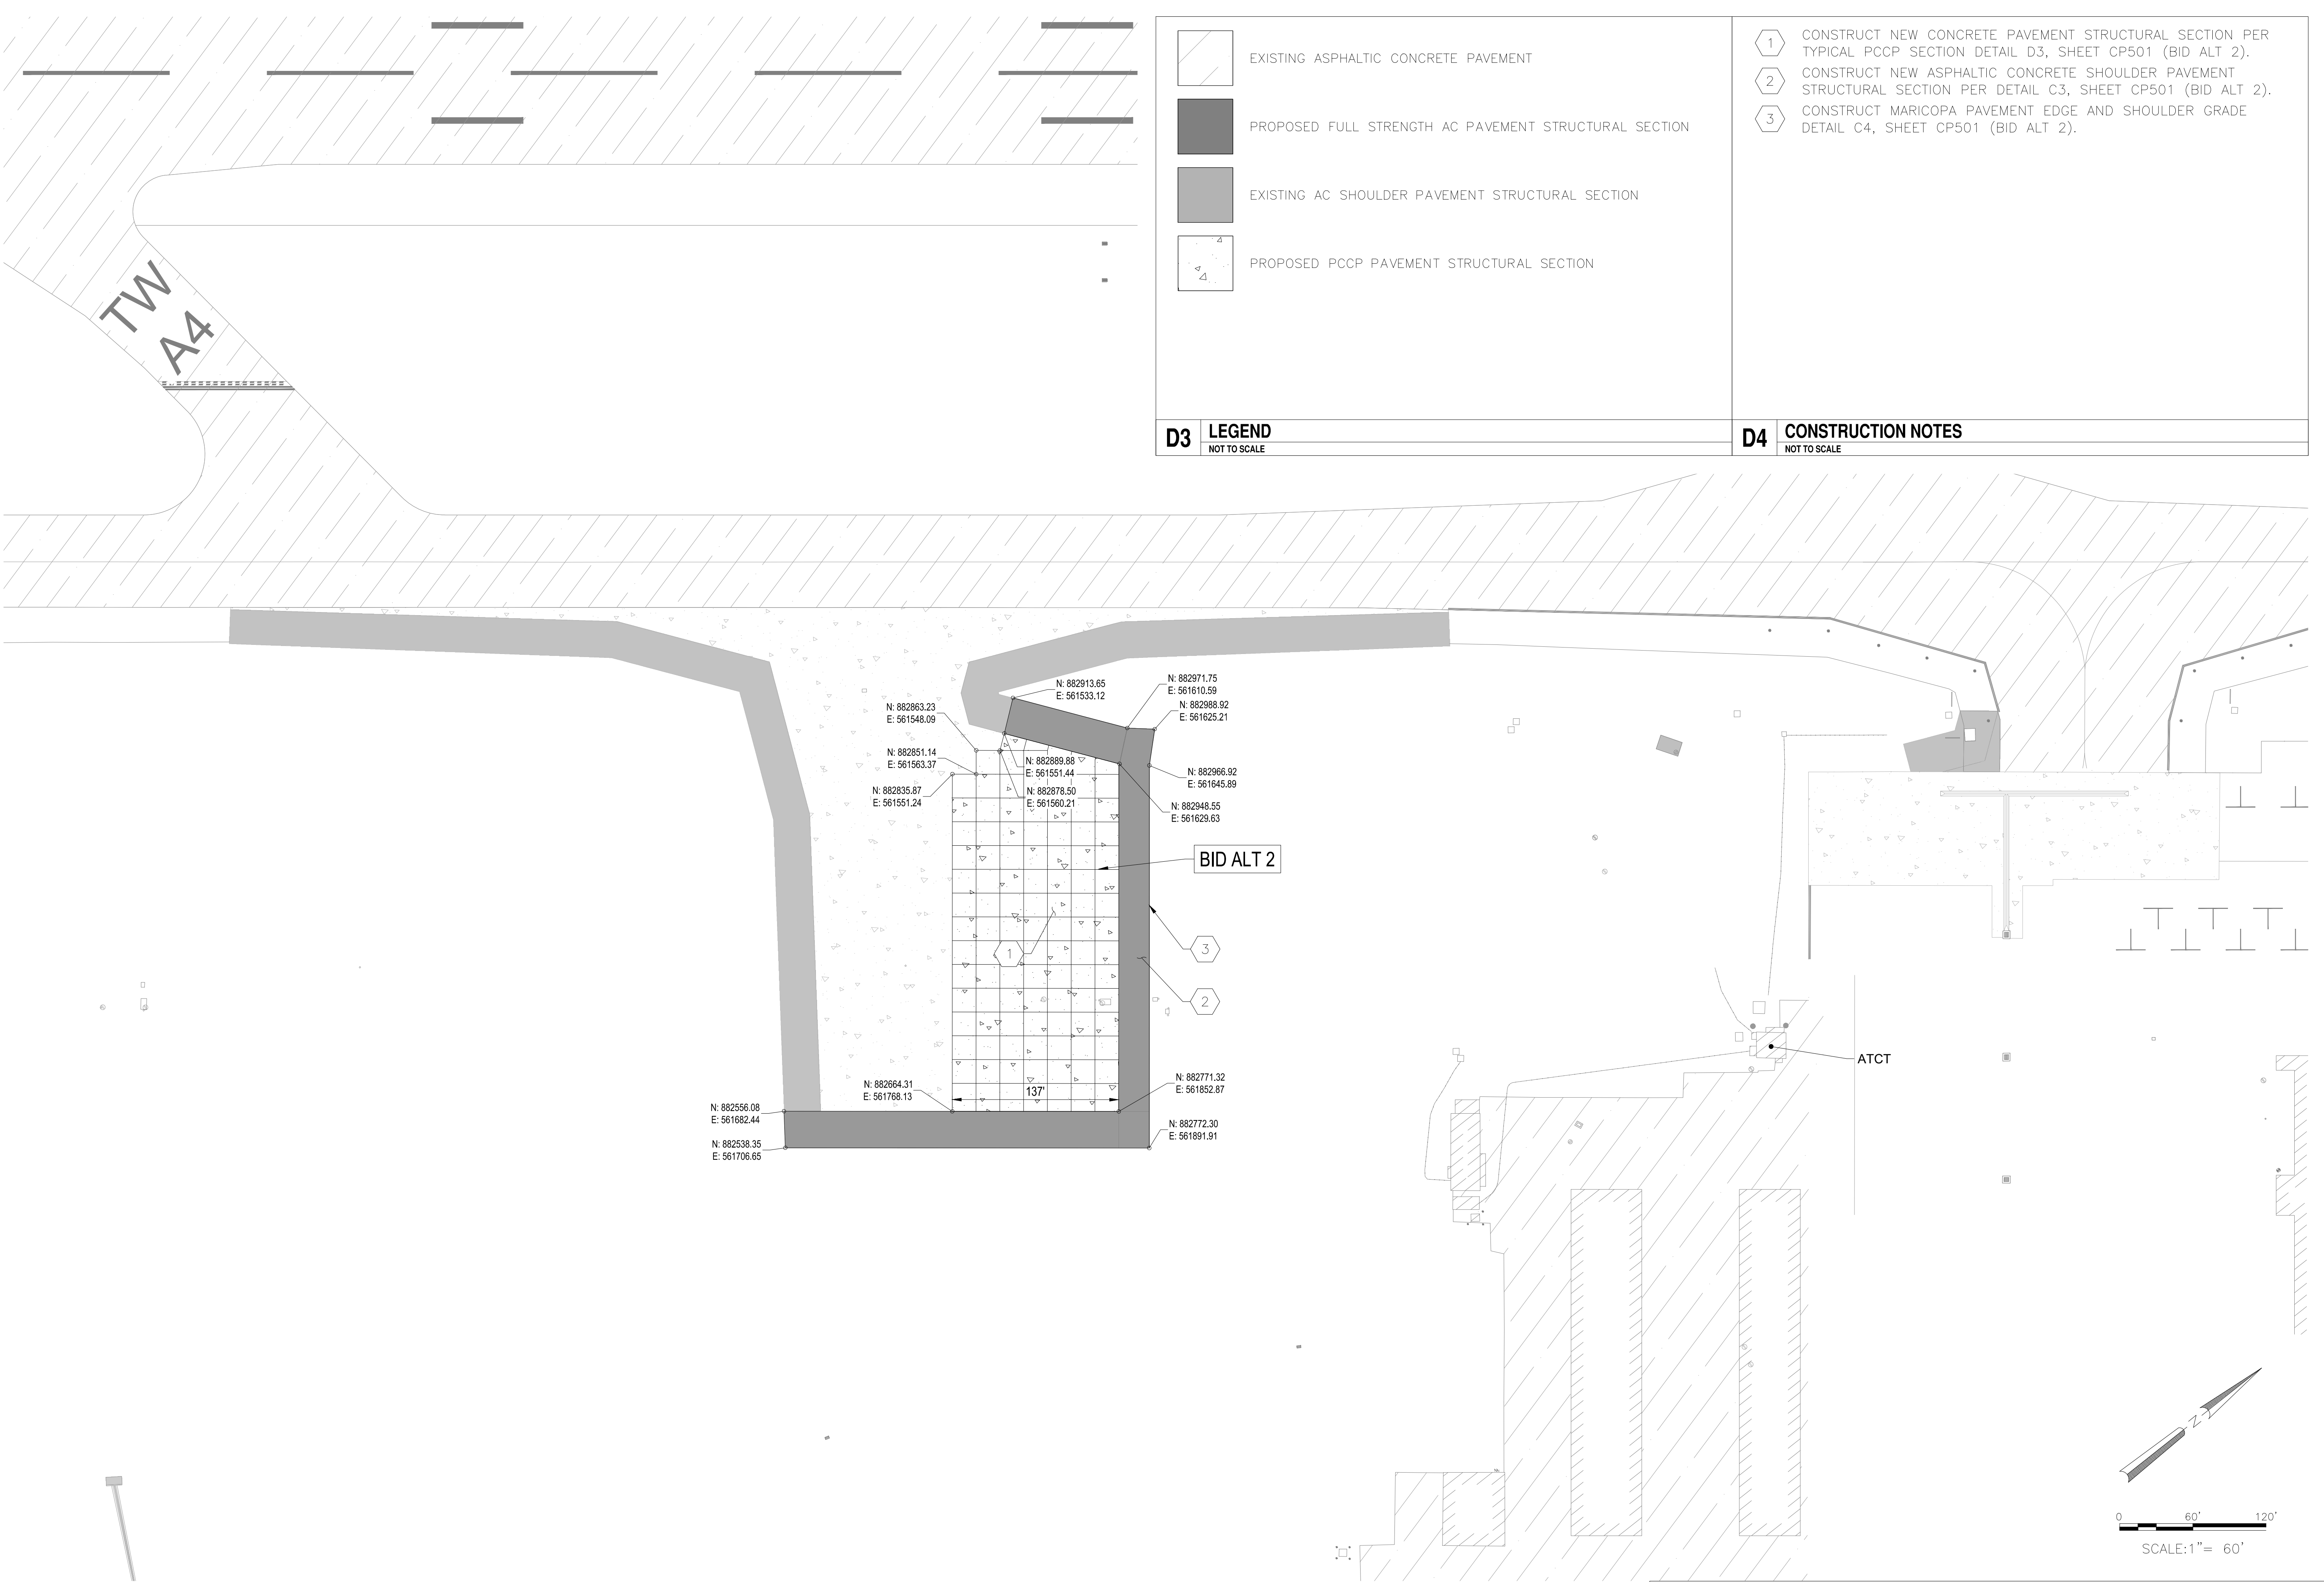

- EXISTING ASPHALTIC CONCRETE PAVEMENT
- PROPOSED FULL STRENGTH AC PAVEMENT STRUCTURAL SECTION
- EXISTING AC SHOULDER PAVEMENT STRUCTURAL SECTION
- PROPOSED PCCP PAVEMENT STRUCTURAL SECTION

- 1 CONSTRUCT NEW CONCRETE PAVEMENT STRUCTURAL SECTION PER TYPICAL PCCP SECTION DETAIL D3, SHEET CP501 (BID ALT 2).
- 2 CONSTRUCT NEW ASPHALTIC CONCRETE SHOULDER PAVEMENT STRUCTURAL SECTION PER DETAIL C3, SHEET CP501 (BID ALT 2).
- 3 CONSTRUCT MARICOPA PAVEMENT EDGE AND SHOULDER GRADE DETAIL C4, SHEET CP501 (BID ALT 2).

D3 LEGEND
NOT TO SCALE

D4 CONSTRUCTION NOTES
NOT TO SCALE

PER CITY OF PHOENIX CODE CHAPTER 2, SECTION 2-28. THESE PLANS ARE FOR OFFICIAL USE ONLY AND MAY NOT BE SHARED WITH OTHERS EXCEPT AS REQUIRED TO FULFILL THE OBLIGATIONS OF CONTRACTOR'S CONTRACT WITH THE CITY OF PHOENIX.

PER CITY OF PHOENIX CITY CODE CHAPTER 2, SECTION 2-28. THESE PLANS ARE FOR OFFICIAL USE ONLY AND MAY NOT BE SHARED WITH OTHERS EXCEPT AS REQUIRED BY THE CITY OF PHOENIX CONTRACT WITH THE CITY OF PHOENIX.	NO.	REVISIONS /	SUBMISSIONS	DATE


CITY OF PHOENIX AVIATION DEPARTMENT

PHOENIX GOODYEAR AIRPORT
NEW APRON AND TAXIWAY CONNECTOR

AV41000077 FAA/ADOT

Designed by: NM	GEOMETRY PLAN BID ALT 2
Drawn by: RB	
Checked by: LM	
Date: February 2023	
Dwg. scale: 1"=60'	Sheet Reference Number:
CIP NO.(S): AV41000077 FAA/ADOT	CG-102
Sheet 18 of 61	



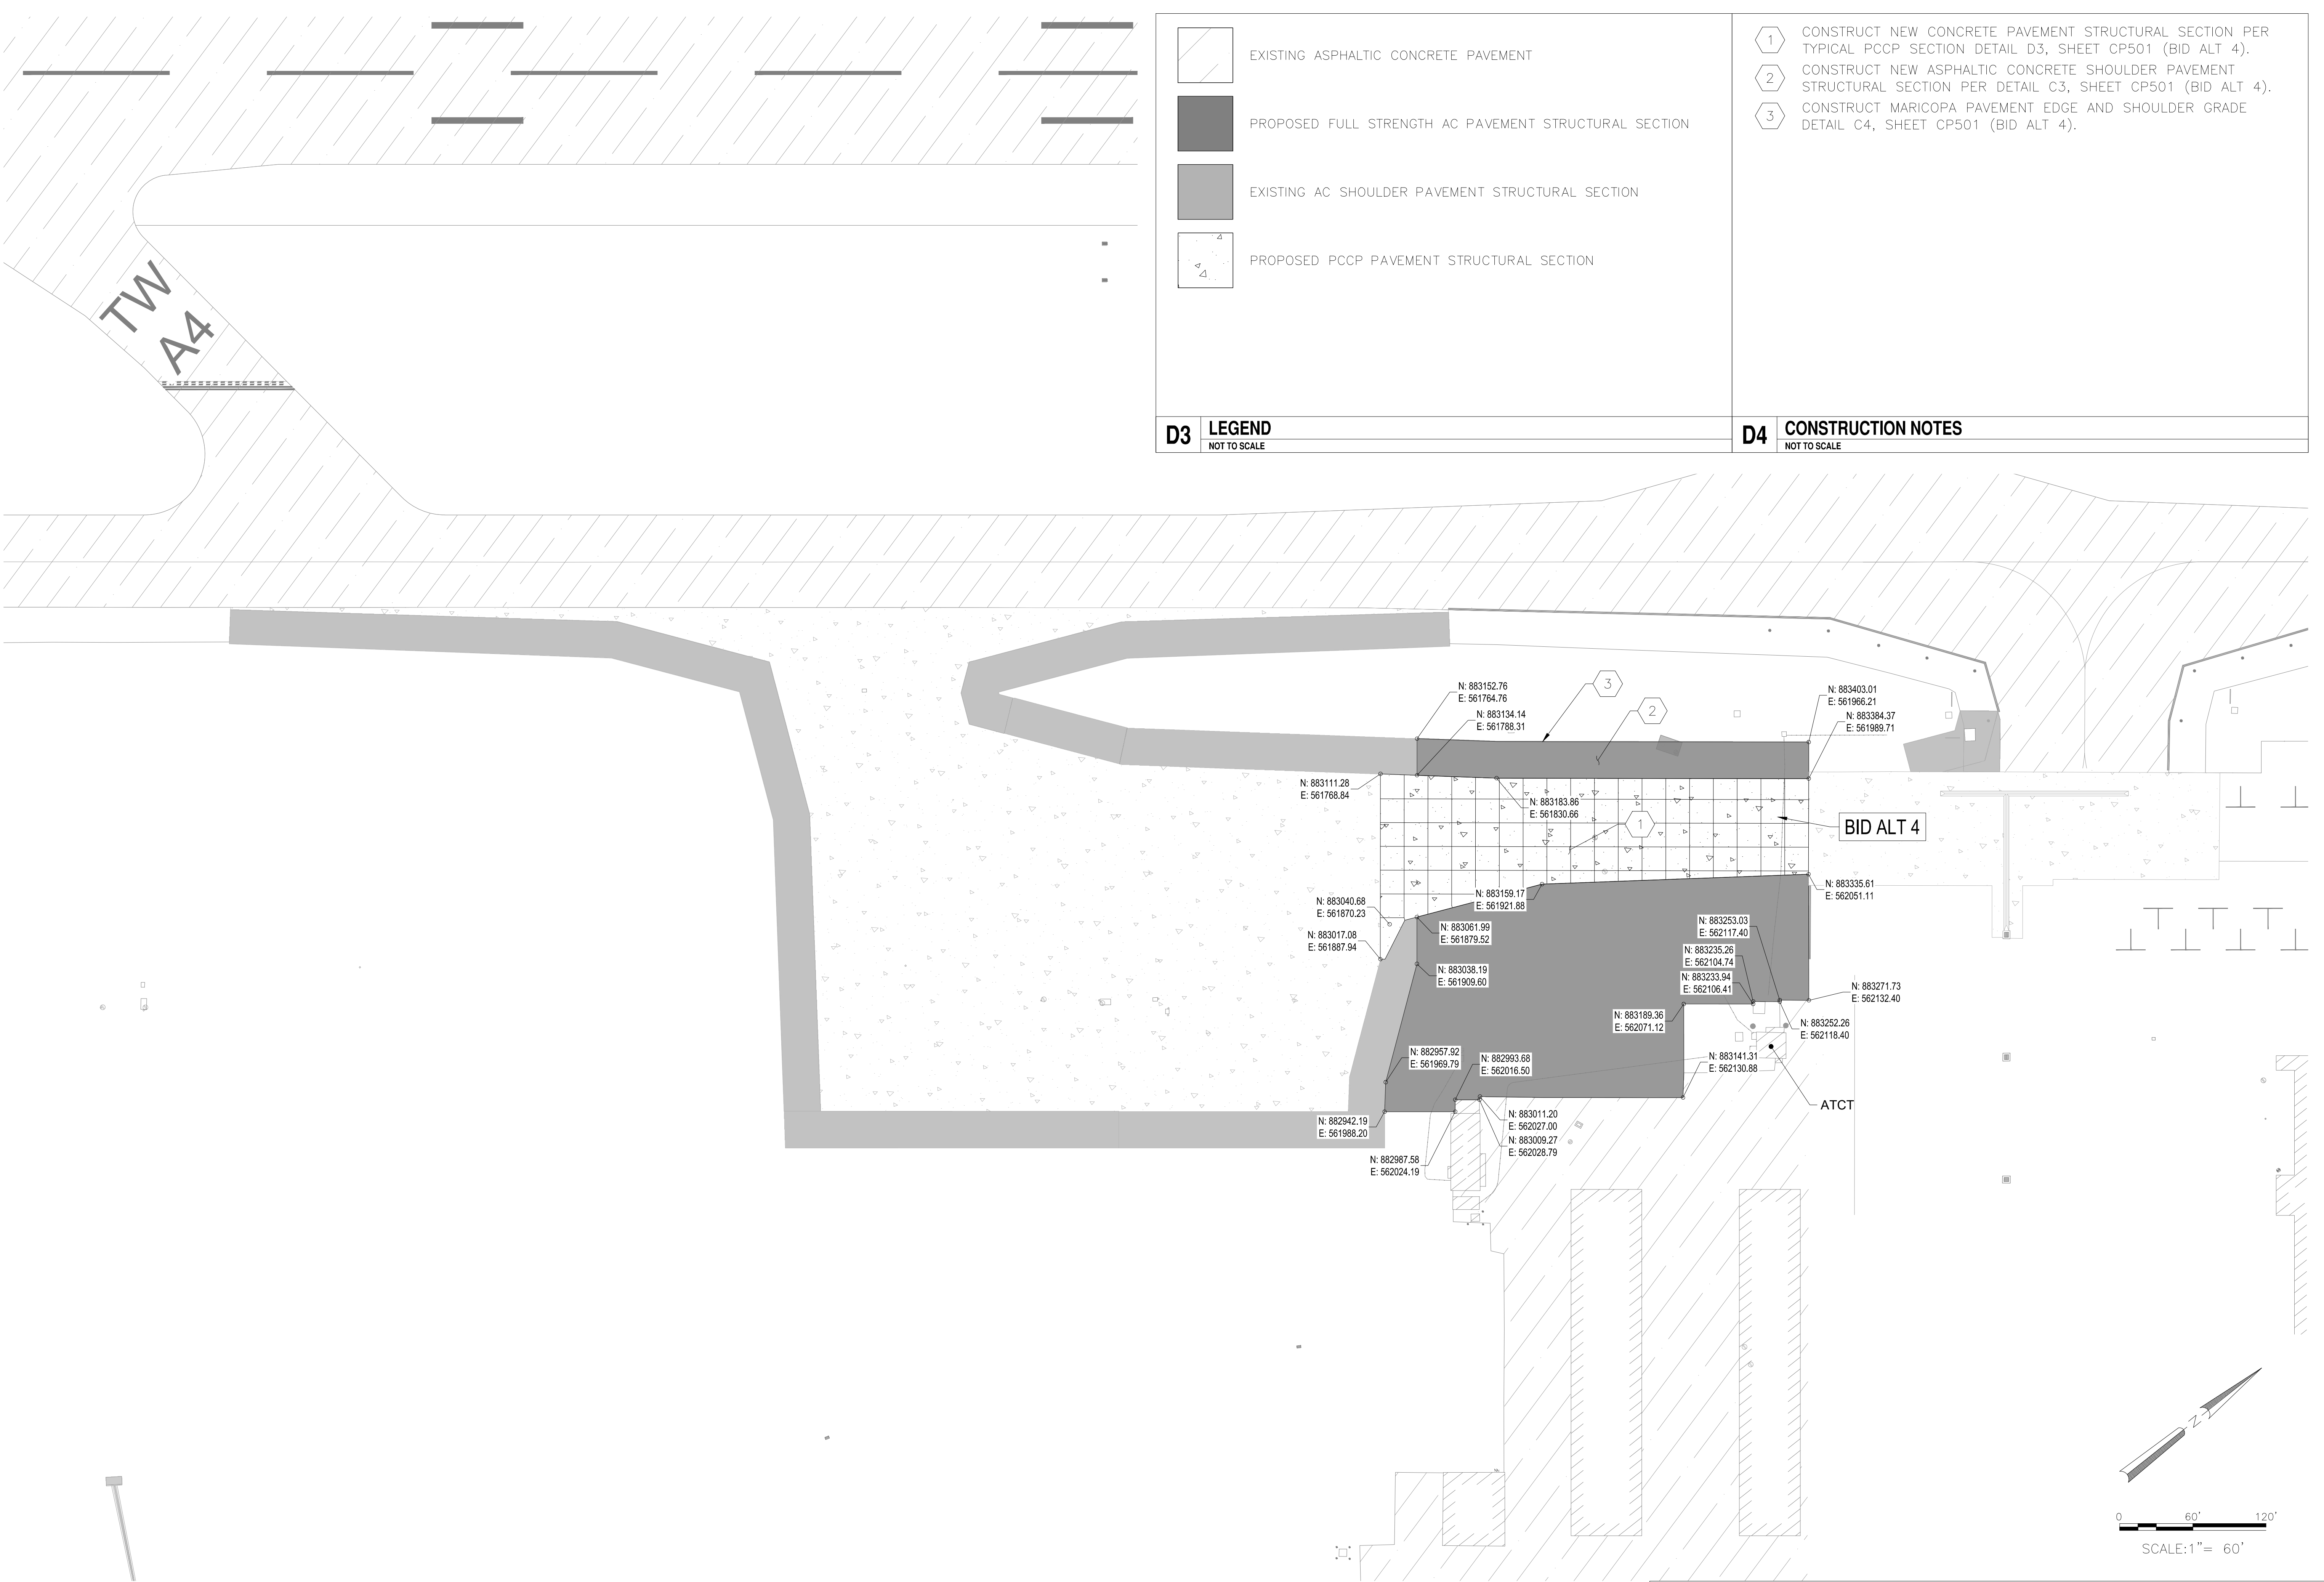

- D3** **LEGEND**
NOT TO SCALE
- D4** **CONSTRUCTION NOTES**
NOT TO SCALE
- 1 CONSTRUCT NEW CONCRETE PAVEMENT STRUCTURAL SECTION PER TYPICAL PCCP SECTION DETAIL D3, SHEET CP501 (BID ALT 4).
- 2 CONSTRUCT NEW ASPHALTIC CONCRETE SHOULDER PAVEMENT STRUCTURAL SECTION PER DETAIL C3, SHEET CP501 (BID ALT 4).
- 3 CONSTRUCT MARICOPA PAVEMENT EDGE AND SHOULDER GRADE DETAIL C4, SHEET CP501 (BID ALT 4).

A1 **GEOMETRY PLAN**
SCALE: 1" = 60'

PER CITY OF PHOENIX CODE CHAPTER 2, SECTION 2-28. THESE PLANS ARE FOR OFFICIAL USE ONLY AND MAY NOT BE SHARED WITH OTHERS EXCEPT AS REQUIRED TO FULFILL THE OBLIGATIONS OF CONTRACTOR'S CONTRACT WITH THE CITY OF PHOENIX.

NO.	REVISIONS / SUBMISSIONS	DATE

PER CITY OF PHOENIX CITY CODE CHAPTER 2, SECTION 2-28. THESE PLANS ARE FOR OFFICIAL USE ONLY AND MAY NOT BE SHARED WITH OTHERS EXCEPT AS REQUIRED TO FULFILL THE OBLIGATIONS OF YOUR CONTRACT WITH THE CITY OF PHOENIX.

PHX DOT CYR
CITY OF PHOENIX AVIATION DEPARTMENT
PHOENIX GOODYEAR AIRPORT
NEW APRON AND TAXIWAY CONNECTOR

Designed by: NM
Drawn by: RB
Checked by: LM
Date: February 2023
Dwg. scale: 1" = 60'


Sheet Overview Title
GEOMETRY PLAN
BID ALT 4

Sheet Reference Number:
CG104
Sheet 20 of 61

CCS
COMPANIES

Registered Professional Engineer
33442
LANCE R. McINTOSH
Exp. 3-31-23

AV41000077 FAA/ADOT

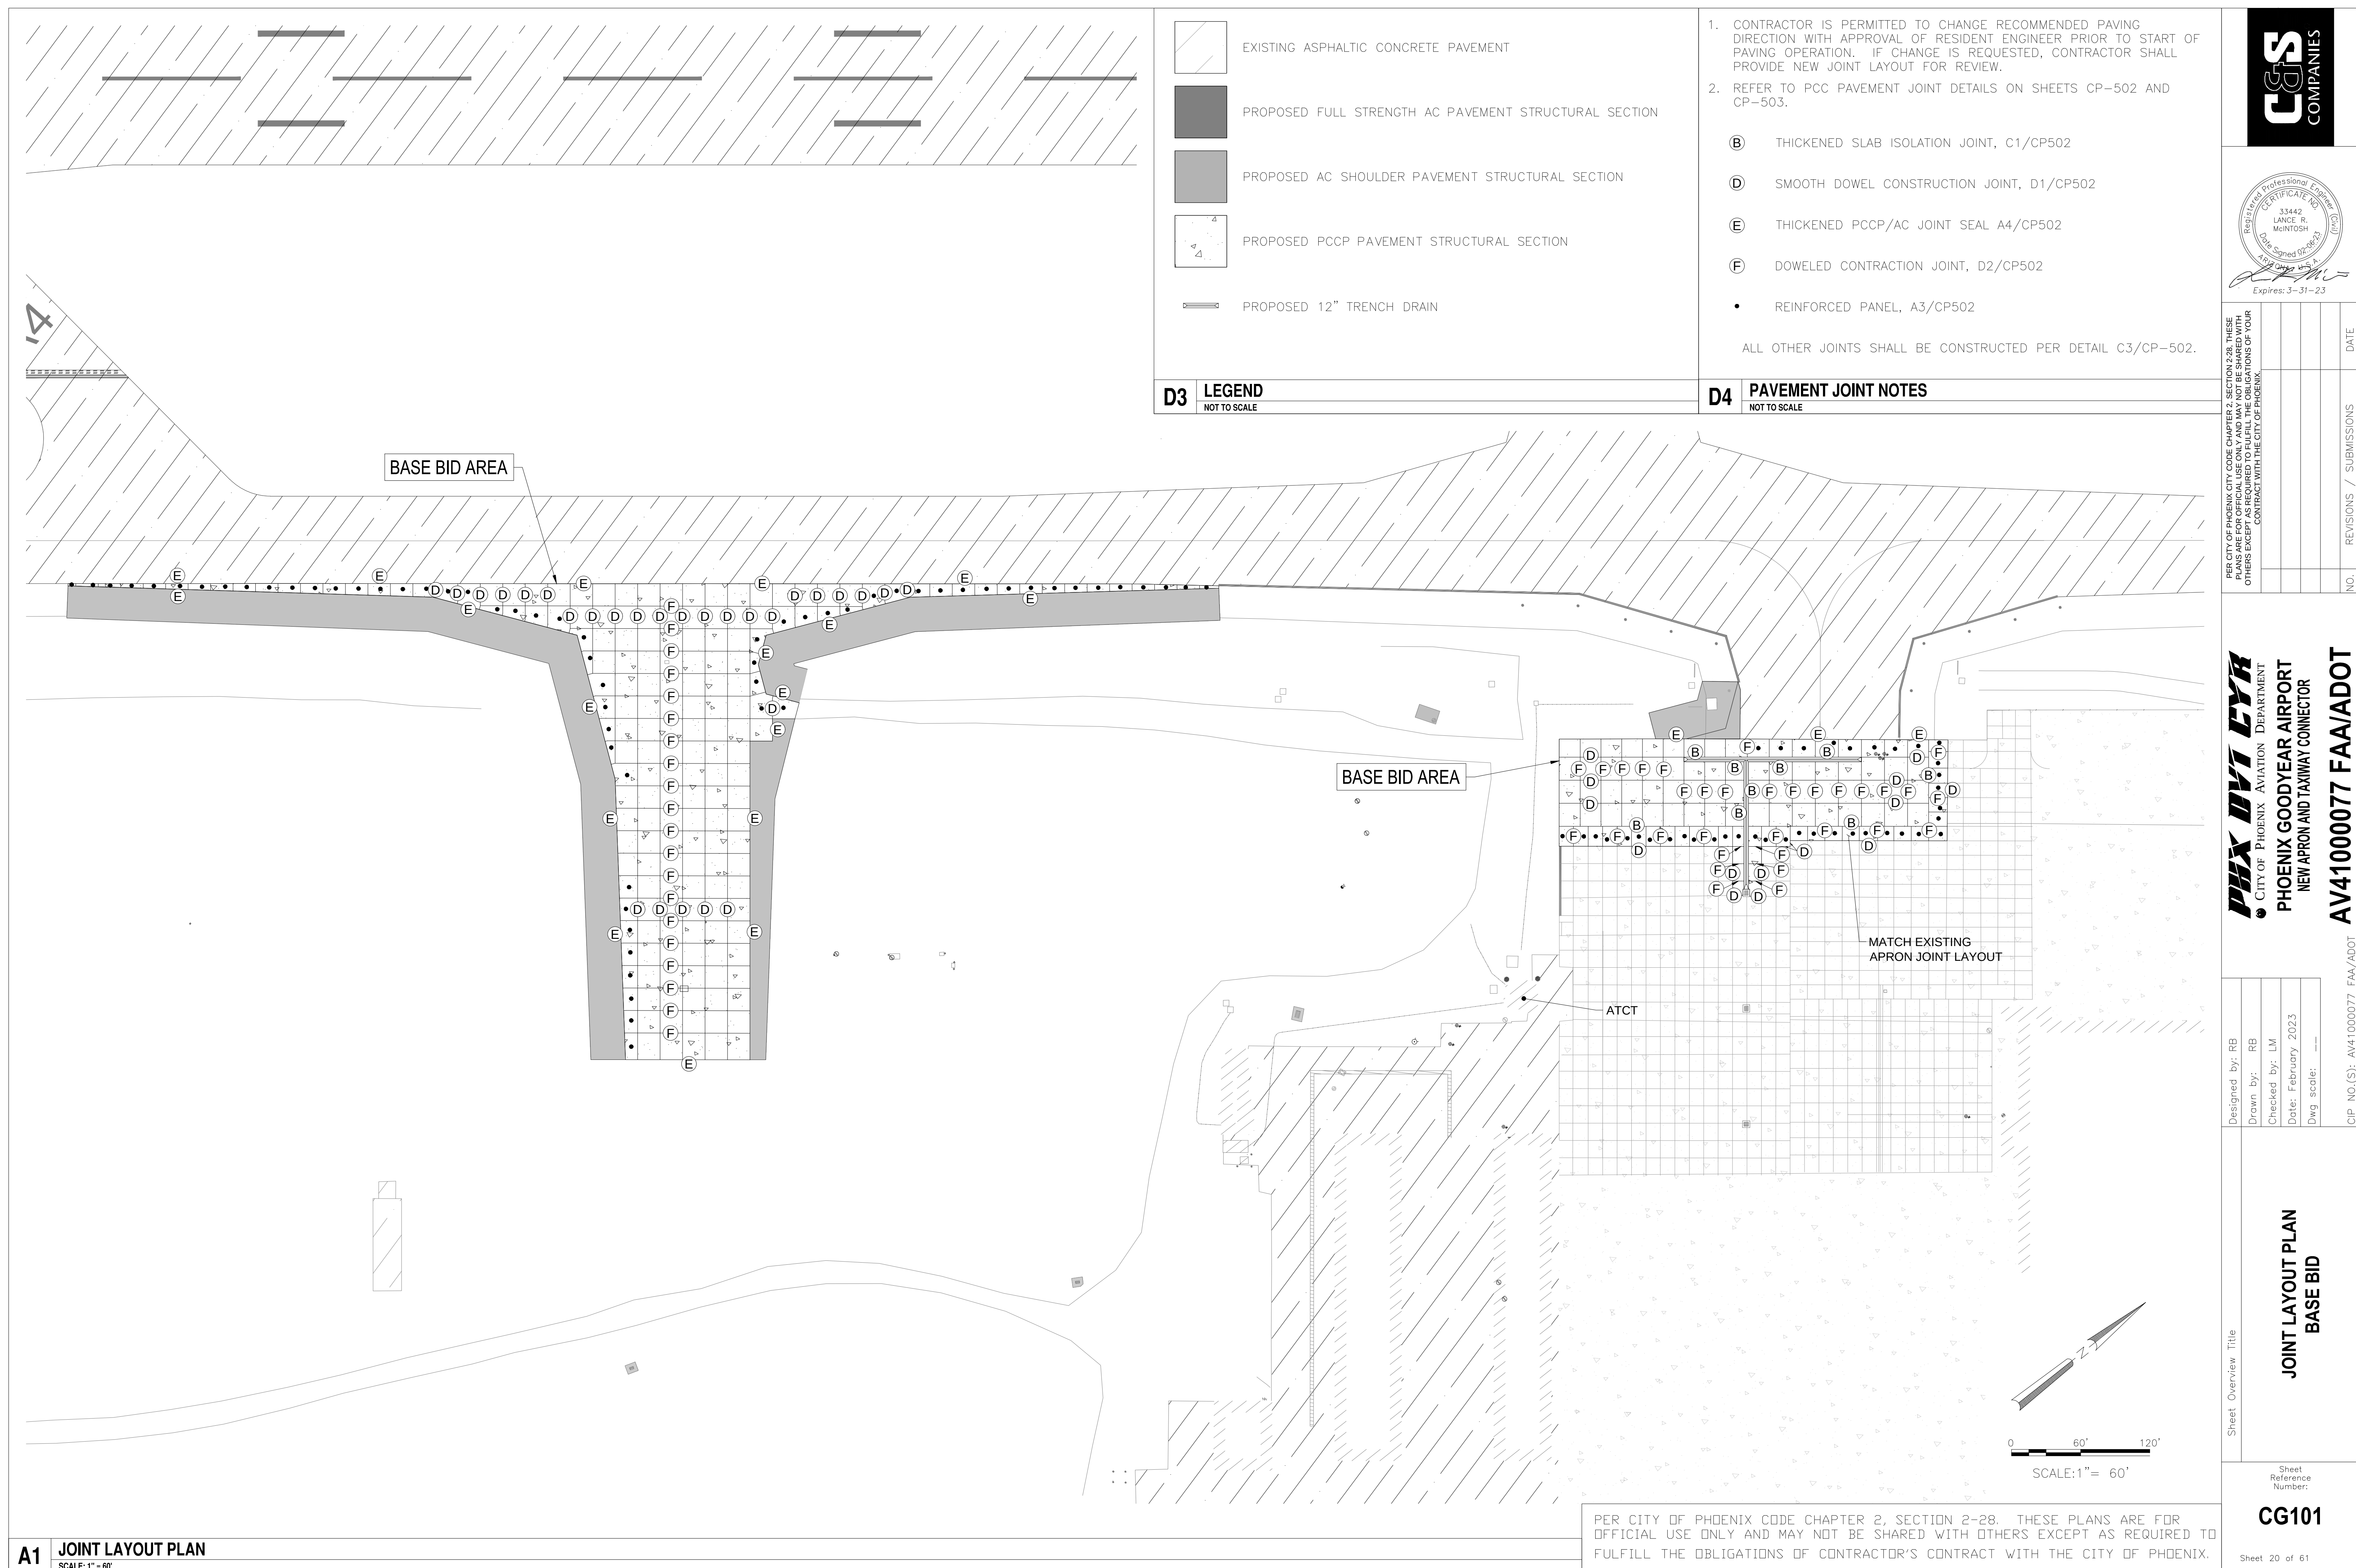

PER CITY OF PHOENIX CITY CODE CHAPTER 2, SECTION 2-28, THESE PLANS ARE FOR OFFICIAL USE ONLY AND MAY NOT BE SHARED WITH OTHERS EXCEPT AS REQUIRED TO FULFILL THE OBLIGATIONS OF YOUR CONTRACT WITH THE CITY OF PHOENIX.

PAX DVT CYR
CITY OF PHOENIX AVIATION DEPARTMENT

**PHOENIX GOODYEAR AIRPORT
NEW APRON AND TAXIWAY CONNECTOR**

AV41000077 FAA/ADOT

CIP NO.(S): AV41000077 FAA/ADOT

Designed by: RB

Drawn by: KB

Checked by: LM
Date: February 2023


Dwg scale:

Sheet Overview title

**JOINT LAYOUT PLAN
BASE BID**

Sheet
Reference
Number:

CG101

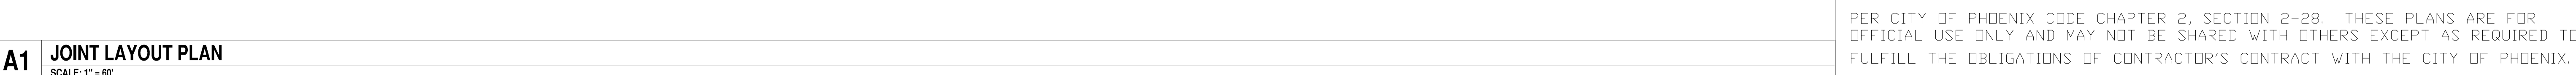

1. CONTRACTOR IS PERMITTED TO CHANGE RECOMMENDED PAVING DIRECTION WITH APPROVAL OF RESIDENT ENGINEER PRIOR TO START OF PAVING OPERATION. IF CHANGE IS REQUESTED, CONTRACTOR SHALL PROVIDE NEW JOINT LAYOUT FOR REVIEW.
2. REFER TO PCC PAVEMENT JOINT DETAILS ON SHEETS CP-502 AND CP-503.
 - ① SMOOTH DOWEL CONSTRUCTION JOINT, D1/CP502
 - ② THICKENED PCCP/AC JOINT SEAL A4/CP502
 - ③ DOWELED CONTRACTION JOINT, D2/CP502
 - REINFORCED PANEL, A3/CP502

ALL OTHER JOINTS SHALL BE CONSTRUCTED PER DETAIL C3/CP-502.

D3 LEGEND

D4 PAVEMENT JOINT NOTES

PER CITY OF PHOENIX CITY CODE CHAPTER 2, SECTION 2-28, THESE PLANS ARE FOR OFFICIAL USE ONLY AND MAY NOT BE SHARED WITH OTHERS EXCEPT AS REQUIRED TO FULFILL THE OBLIGATIONS OF YOUR CONTRACT WITH THE CITY OF PHOENIX

THE NEW YORK TIMES

Designed by: RB
Drawn by: RB
Checked by: LM
Date: February 2023
Dwg scale: 1:1000

view	Title
	JOINT LAYOUT PLAN BID ALT 2


Sheet
Reference
Number:

CG102

Sheet 22 of 61



CIP NO (S): AV41000077 FAA/ADOT

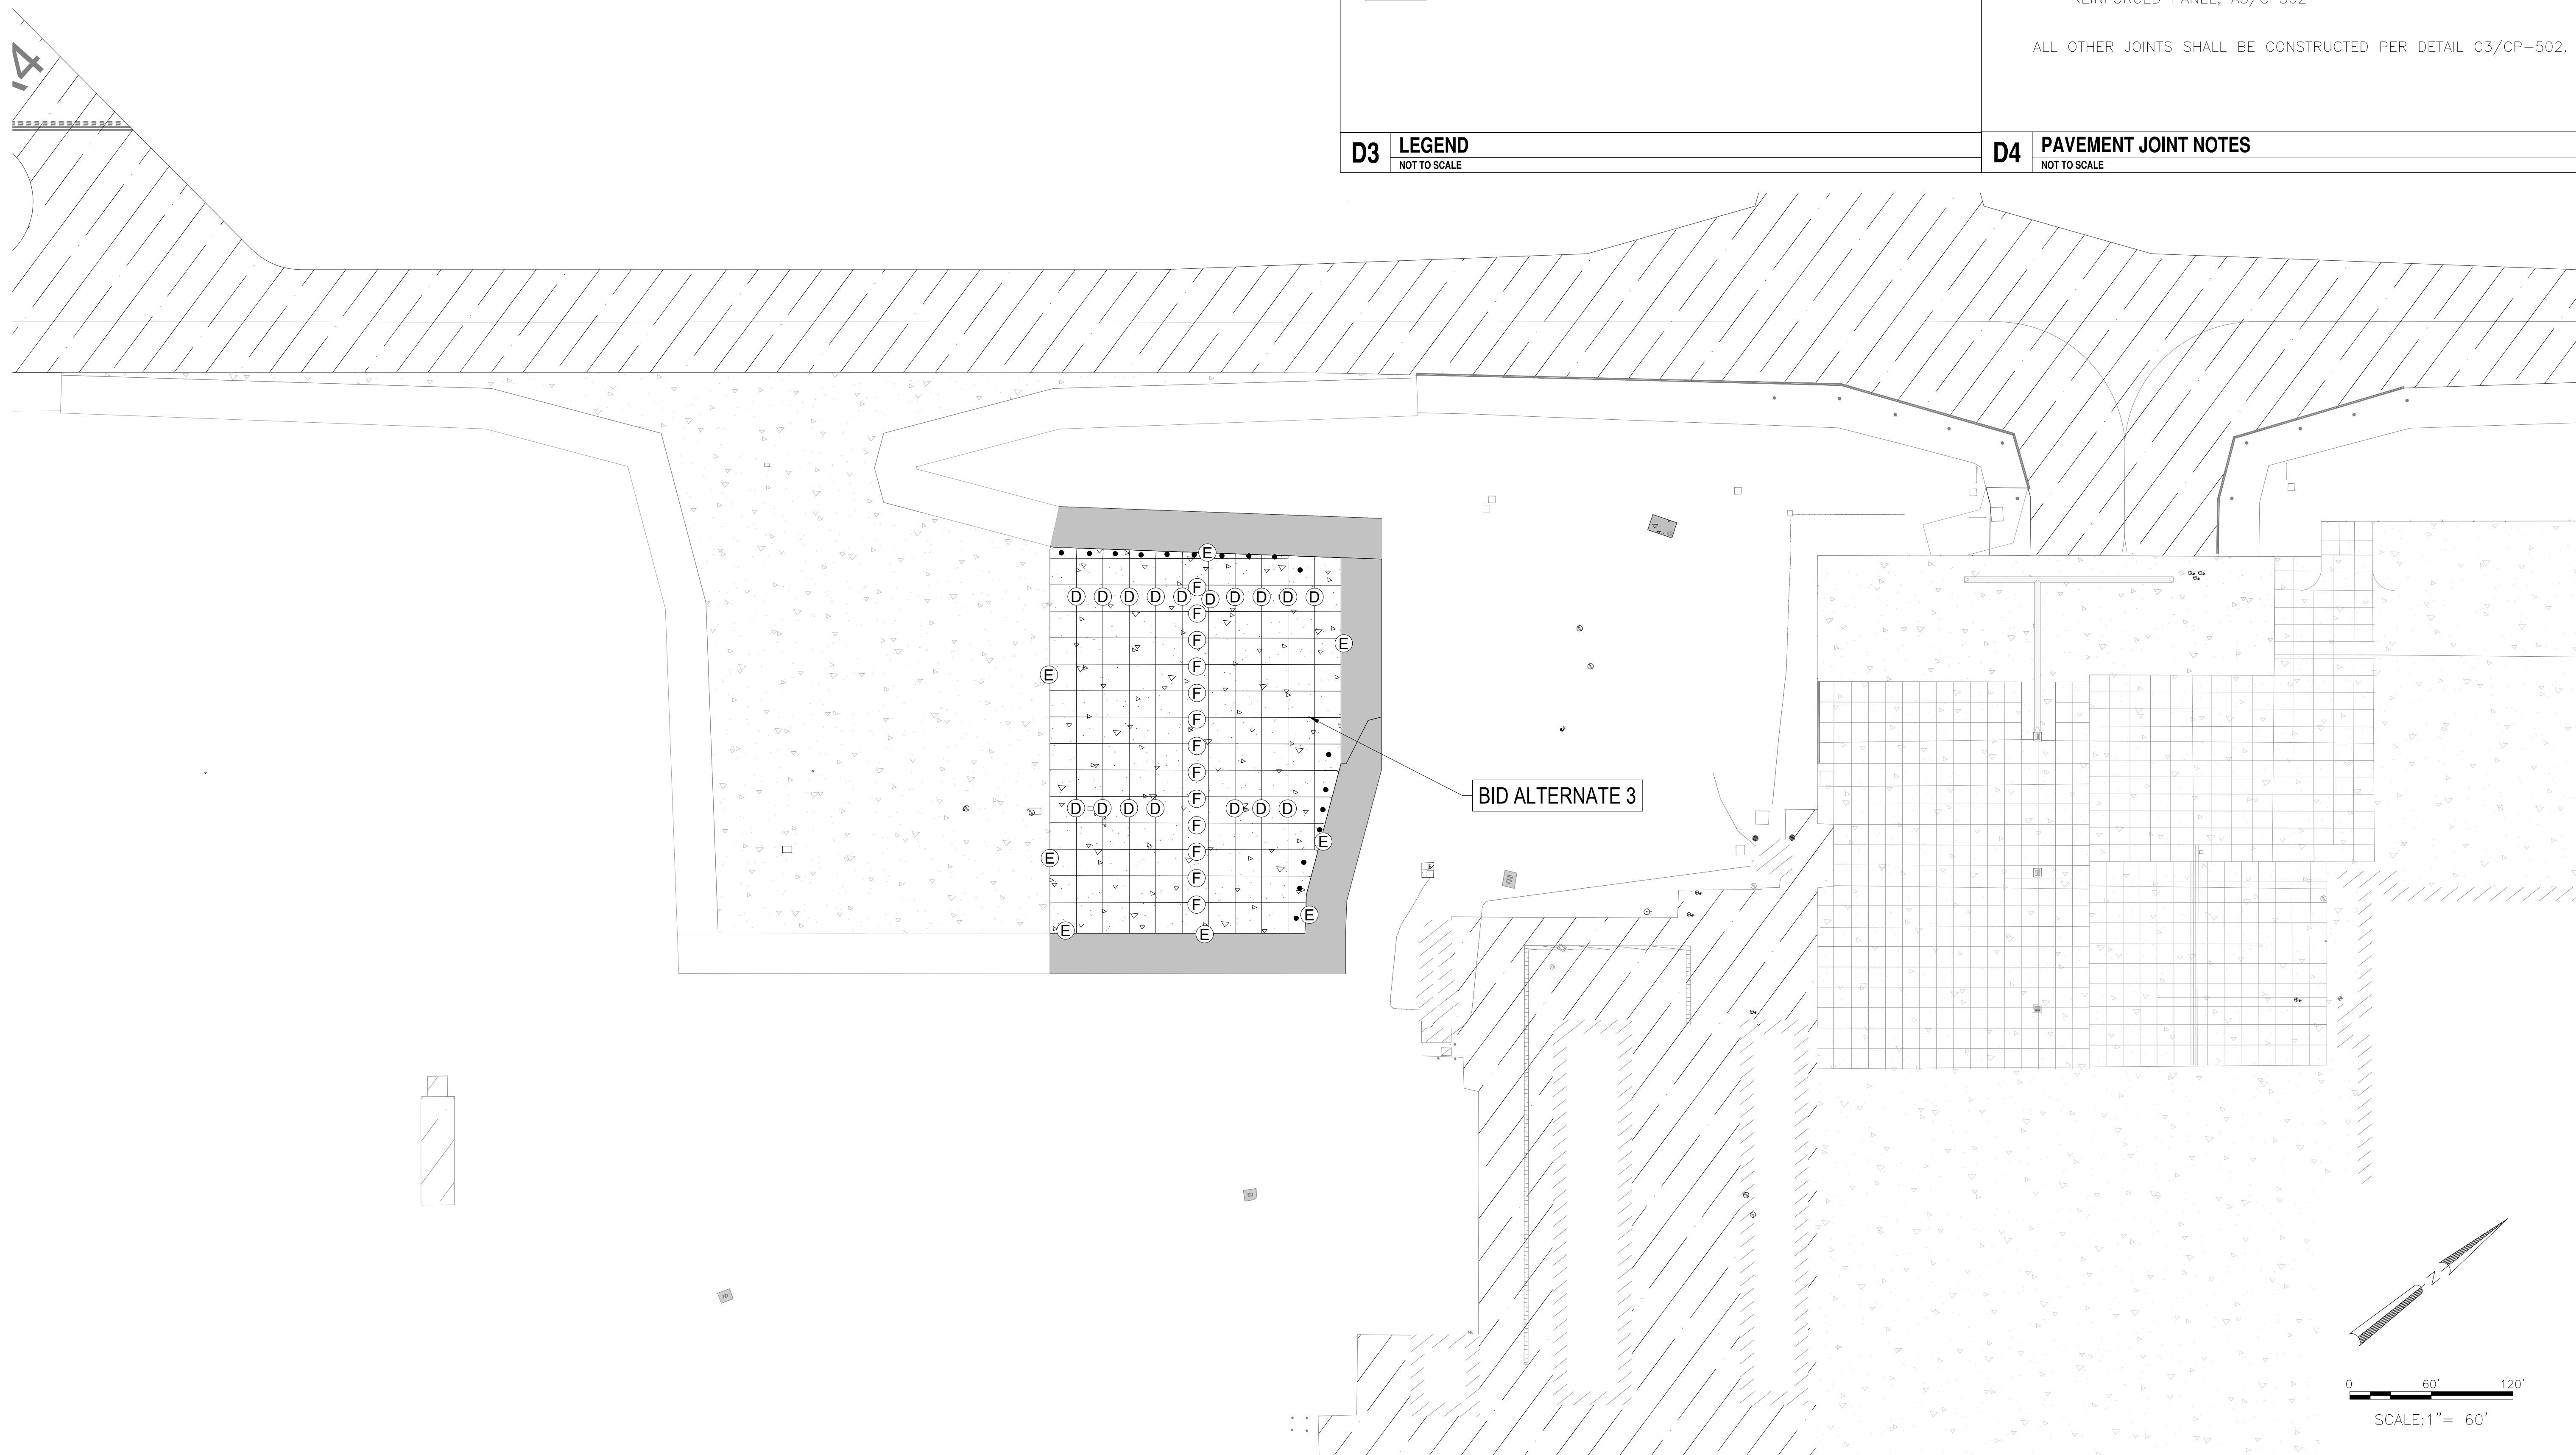

PROPOSED PCCP PAVEMENT STRUCTURAL SECTION

ALL OTHER JOINTS SHALL BE CONSTRUCTED PER DETAIL C3/CP-502.

D4	PAVEMENT JOINT NOTES
	NOT TO SCALE

PER CITY OF PHOENIX CITY CODE CHAPTER 2, SECTION 2-28, THESE PLANS ARE FOR OFFICIAL USE ONLY AND MAY NOT BE SHARED WITH OTHERS EXCEPT AS REQUIRED TO FULFILL THE OBLIGATIONS OF YOUR CONTRACT WITH THE CITY OF PHOENIX.



NO.	REVISIONS / SUBMISSIONS	DATE

AV41000077 FAA/ADOT

Drawn by: RB
Checked by: LM
Date: February 2
Dwg scale:

CIP NO.(S): AV41000077 FAA/ADOT

JOINT LAYOUT PLAN


Sheet
Reference
Number:

CG103

Sheet 23 of 61

A1	JOINT LAYOUT PLAN
	SCALE: 1" = 60'


PER CITY OF PHOENIX CODE CHAPTER 2, SECTION 2-28. THESE PLANS ARE FOR OFFICIAL USE ONLY AND MAY NOT BE SHARED WITH OTHERS EXCEPT AS REQUIRED TO FULFILL THE OBLIGATIONS OF CONTRACTOR'S CONTRACT WITH THE CITY OF PHOENIX.

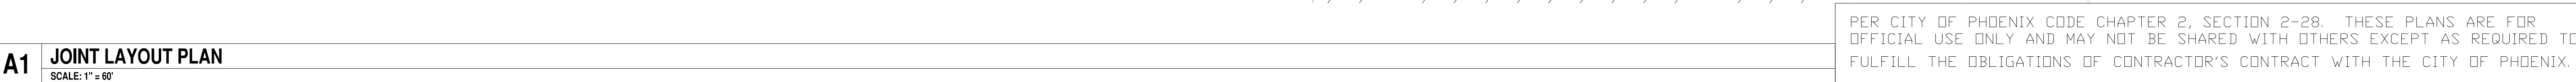


PER CITY OF PHOENIX CODE CHAPTER 2, SECTION 2-28. THESE PLANS ARE FOR OFFICIAL USE ONLY AND MAY NOT BE SHARED WITH OTHERS EXCEPT AS REQUIRED TO FULFILL THE OBLIGATIONS OF CONTRACTOR'S CONTRACT WITH THE CITY OF PHOENIX.

Designed by: RB	Drawn by: RB
 CITY OF PHOENIX AVIATION DEPARTMENT	
PHOENIX GOODYEAR AIRPORT NEW APRON AND TAXIWAY CONNECTOR	
AV41000077 FAA/ADOT	
CIP NO(S): AV41000077 FAA/ADOT	
Date: February 2023	Dwg scale: —

Sheet Overview	Sheet Reference Number:
JOINT LAYOUT PLAN BID ALT 4	CG104

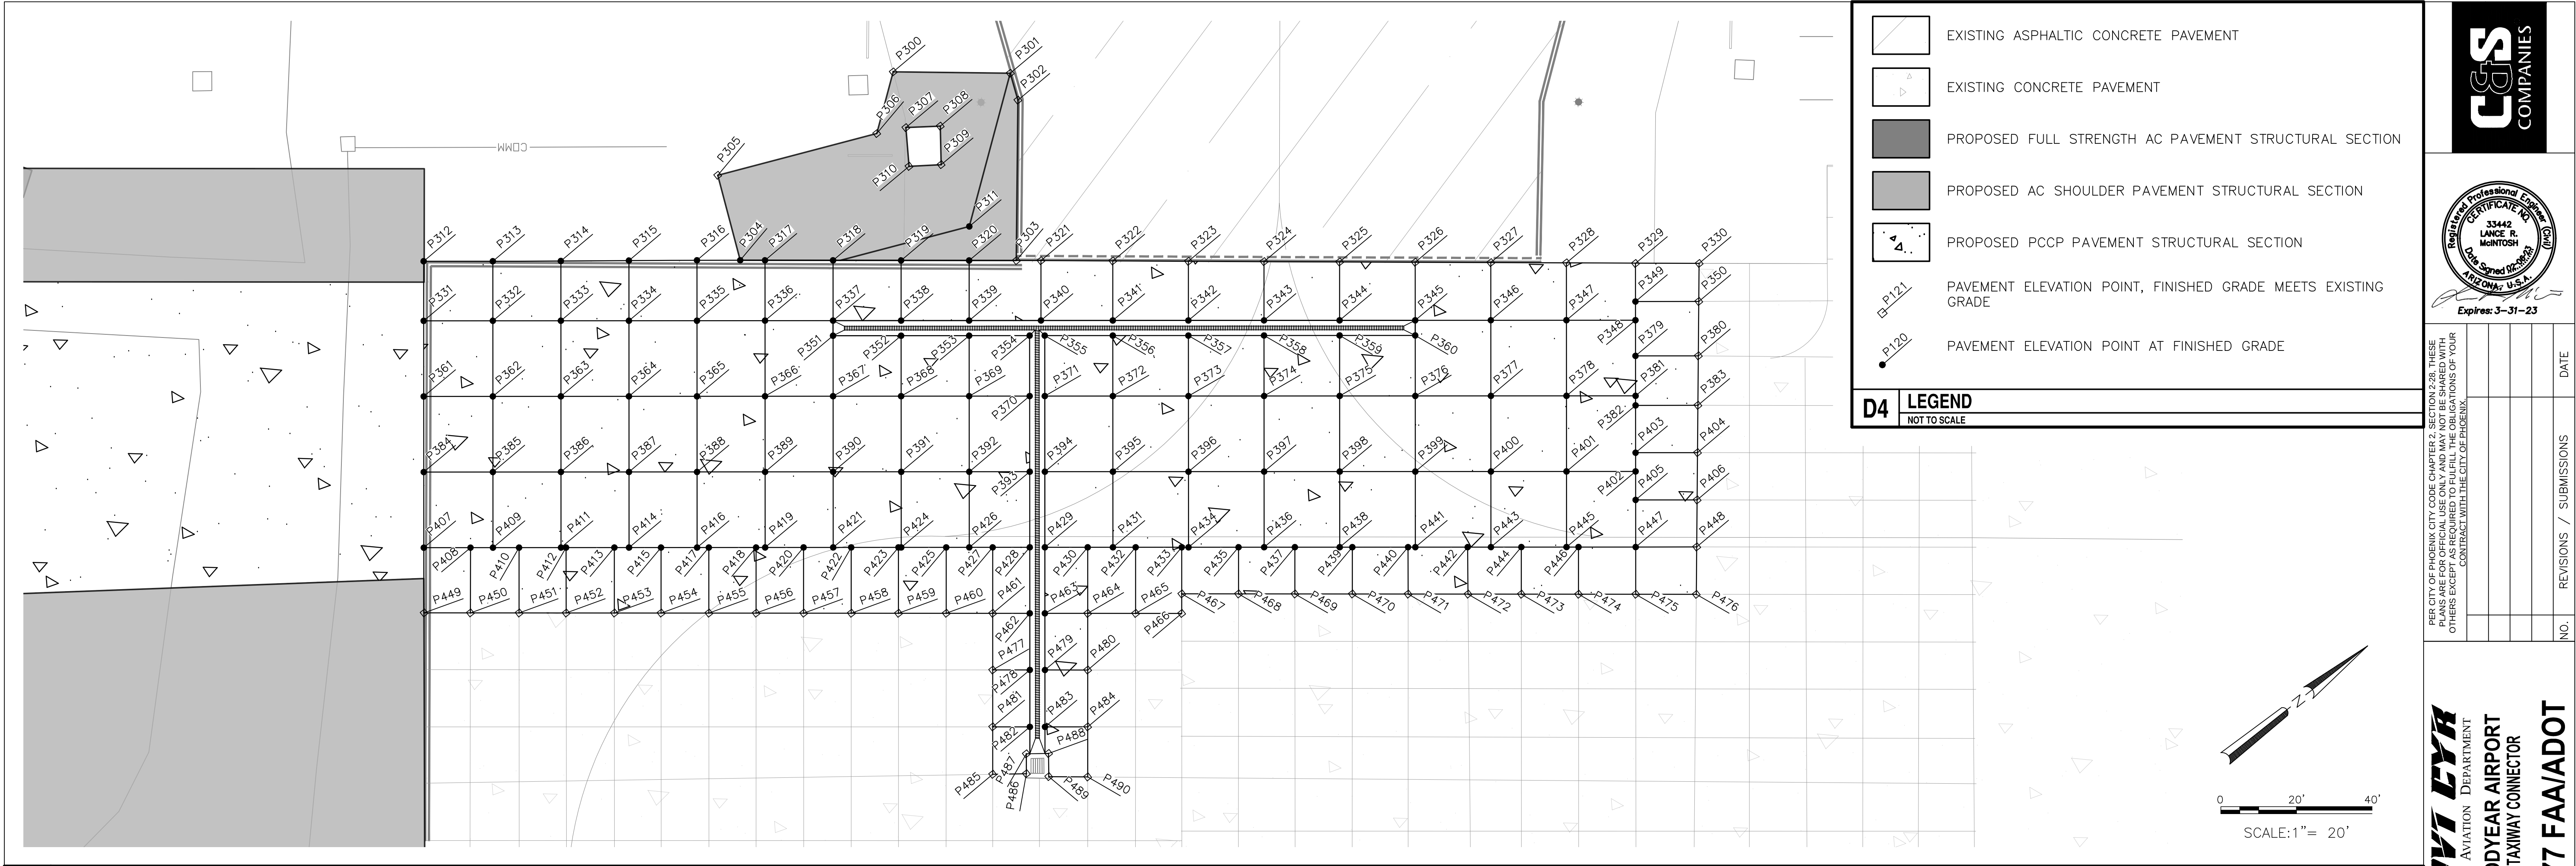

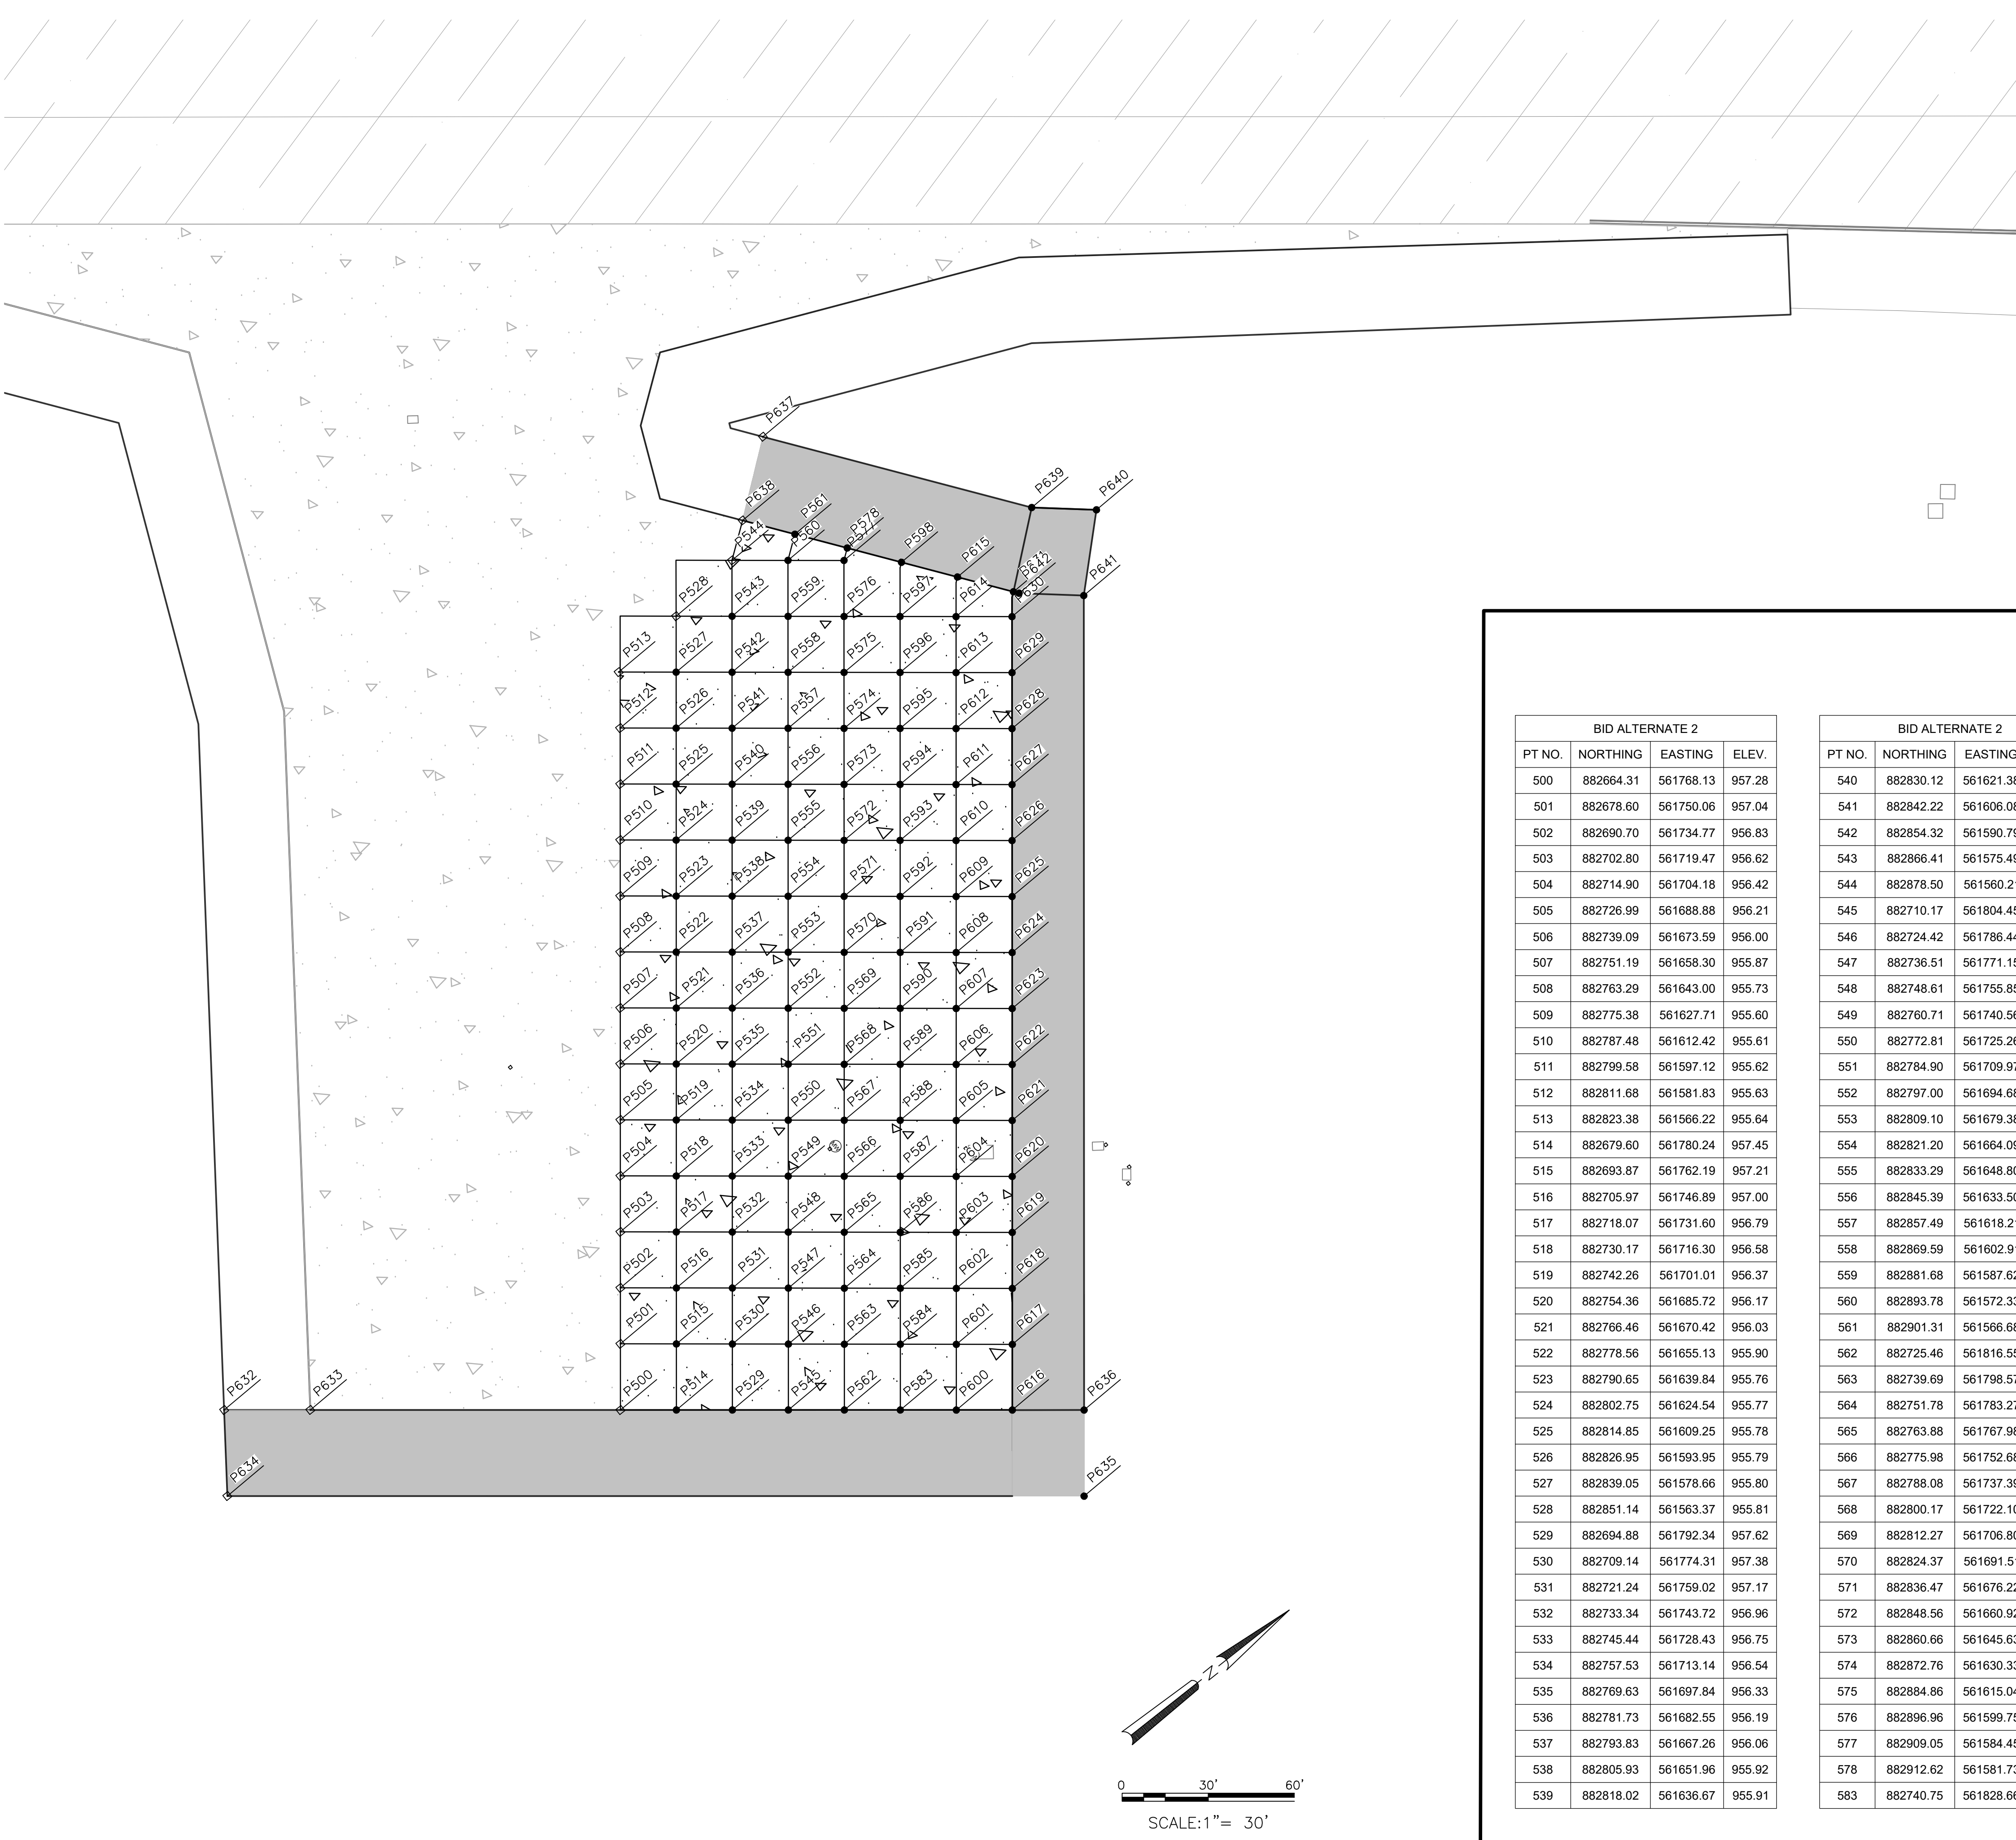

EXISTING ASPHALTIC CONCRETE PAVEMENT

EXISTING CONCRETE PAVEMENT

PROPOSED FULL STRENGTH AC PAVEMENT STRUCTURAL SECTION

PROPOSED AC SHOULDER PAVEMENT STRUCTURAL SECTION

PROPOSED PCCP PAVEMENT STRUCTURAL SECTION

P121

PAVEMENT ELEVATION POINT, FINISHED GRADE MEETS EXISTING GRADE

P120

PAVEMENT ELEVATION POINT AT FINISHED GRADE

D4

LEGEND

NOT TO SCALE

BID ALTERNATE 2			
PT NO.	NORTHING	EASTING	ELEV.
500	882864.31	561768.13	957.28
501	882678.60	561750.06	957.04
502	882690.70	561734.77	956.83
503	882702.80	561719.47	956.62
504	882714.90	561704.18	956.42
505	882726.99	561688.88	956.21
506	882739.09	561673.59	956.00
507	882751.19	561658.30	955.87
508	882763.29	561643.00	955.73
509	882775.38	561627.71	955.60
510	882787.48	561612.42	955.61
511	882799.58	561597.12	955.62
512	882811.68	561581.83	955.63
513	882823.38	561566.22	955.64
514	882679.60	561780.24	957.45
515	882693.87	561762.19	957.21
516	882705.97	561746.89	957.00
517	882718.07	561731.60	956.79
518	882730.17	561716.30	956.58
519	882742.26	561701.01	956.37
520	882754.36	561685.72	956.17
521	882766.46	561670.42	956.03
522	882778.56	561655.13	955.90
523	882790.65	561639.84	955.76
524	882802.75	561624.54	955.77
525	882814.85	561609.25	955.78
526	882826.95	561593.95	955.79
527	882839.05	561578.66	955.80
528	882851.14	561563.37	955.81
529	882694.88	561792.34	957.62
530	882709.14	561774.31	957.38
531	882721.24	561759.02	957.17
532	882733.34	561743.72	956.96
533	882745.44	561728.43	956.75
534	882757.53	561713.14	956.54
535	882769.63	561697.84	956.33
536	882781.73	561682.55	956.19
537	882793.83	561667.26	956.06
538	882805.93	561651.96	955.92
539	882818.02	561636.67	955.91

BID ALTERNATE 2			
PT NO.	NORTHING	EASTING	ELEV.
540	882830.12	561621.38	955.92
541	882842.22	561606.08	955.93
542	882854.32	561590.79	955.94
543	882866.41	561575.49	955.95
544	882878.50	561560.21	955.96
545	882710.17	561804.45	957.79
546	882724.42	561786.44	957.55
547	882736.51	561771.15	957.34
548	882748.61	561755.85	957.13
549	882760.71	561740.56	956.92
550	882772.81	561725.26	956.70
551	882784.90	561709.97	956.49
552	882797.00	561694.68	956.35
553	882809.10	561679.38	956.22
554	882821.20	561664.09	956.08
555	882833.29	561648.80	956.07
556	882845.39	561633.50	956.06
557	882857.49	561618.21	956.07
558	882869.59	561602.91	956.08
559	882881.68	561587.62	956.09
560	882893.78	561572.33	956.10
561	882901.31	561566.68	956.13
562	882725.46	561816.55	957.96
563	882739.69	561798.57	957.72
564	882751.78	561783.27	957.51
565	882763.88	561767.98	957.29
566	882775.98	561752.68	957.08
567	882788.08	561737.39	956.87
568	882800.17	561722.10	956.65
569	882812.27	561706.80	956.52
570	882824.37	561691.51	956.38
571	882836.47	561676.22	956.24
572	882848.56	561660.92	956.23
573	882860.66	561645.63	956.22
574	882872.76	561630.33	956.21
575	882884.86	561615.04	956.22
576	882896.96	561599.75	956.23
577	882909.05	561584.45	956.24
578	882912.62	561581.73	956.25
583	882740.75	561828.66	958.13

BID ALTERNATE 2			
PT NO.	NORTHING	EASTING	ELEV.
584	882754.96	561810.69	957.88
585	882767.06	561795.39	957.67
586	882779.16	561780.10	957.46
587	882791.25	561764.81	957.24
588	882803.35	561749.51	957.03
589	882815.45	561734.22	956.82
590	882827.55	561718.93	956.68
591	882839.64	561703.63	956.54
592	882851.74	561688.34	956.40
593	882863.84	561673.04	956.39
594	882875.94	561657.75	956.38
595	882888.03	561642.46	956.37
596	882900.13	561627.16	956.36
597	882912.23	561611.87	956.37
598	882924.34	561597.37	956.39
600	882756.03	561840.77	958.30
601	882770.23	561822.82	958.05
602	882782.33	561807.52	957.83
603	882794.42	561792.23	957.62
604	882806.52	561776.94	957.41
605	882818.62	561761.64	957.19
606	882830.72	561746.35	956.98
607	882842.81	561731.06	956.84
608	882854.91	561715.76	956.70
609	882867.01	561700.47	956.56
610	882879.11	561685.17	956.55
611	882891.20	561669.88	956.54
612	882903.30	561654.59	956.53
613	882915.40	561639.29	956.51
614	882927.50	561624.00	956.51
615	882936.45	561613.50	956.52
616	882771.32	561852.87	958.47
617	882785.50	561834.94	958.22
618	882797.60	561819.65	958.00
619	882809.69	561804.36	957.79
620	882821.79	561789.06	957.58
621	882833.89	561773.77	957.36
622	882845.99	561758.48	957.14
623	882858.08	561743.18	957.00
624	882870.18	561727.89	956.86

BID ALTERNATE 2			
PT NO.	NORTHING	EASTING	ELEV.
625	882882.28	561712.59	956.72
626	882894.38	561697.30	956.71
627	882906.48	561682.01	956.70
628	882918.57	561666.71	956.69
629	882930.67	561651.42	956.67
630	882942.77	561636.13	956.66
631	882948.55	561629.63	956.66
632	882556.08	561682.44	954.87
633	882579.63	561701.07	956.38
634	882538.35	561706.65	954.18
635	882772.30	561891.91	957.07
636	882790.93	561868.39	958.69
637	882913.65	561533.12	954.39
638	882890.00	561551.59	956.00
639	882971.75	561610.59	955.18
640	882988.92	561625.21	955.38
641	882966.92	561645.89	956.87
642	882949.76	561631.26	956.68

PER CITY OF PHOENIX CODE CHAPTER 2, SECTION 2-28, THESE PLANS ARE FOR OFFICIAL USE ONLY AND MAY NOT BE SHARED WITH OTHERS EXCEPT AS REQUIRED TO FULFILL THE OBLIGATIONS OF CONTRACTOR'S CONTRACT WITH THE CITY OF PHOENIX.

PER CITY OF PHOENIX CITY CODE CHAPTER 2, SECTION 2-28, THESE PLANS ARE FOR OFFICIAL USE ONLY AND MAY NOT BE SHARED WITH OTHERS EXCEPT AS REQUIRED TO FULFILL THE OBLIGATIONS OF YOUR CONTRACT WITH THE CITY OF PHOENIX.

NO.		REVISIONS / SUBMISSIONS		DATE	

PHX DOT CYR

CITY OF PHOENIX AVIATION DEPARTMENT

PHOENIX GOODYEAR AIRPORT


NEW APRON AND TAXIWAY CONNECTOR

AV41000077 FAA/ADOT

Designed by: NM	Drawn by: RB
Checked by: LM	Date: February 2023
Dwg scale: 1"=30'	


PAVING PLAN
BID ALT 2

Sheet Reference Number:

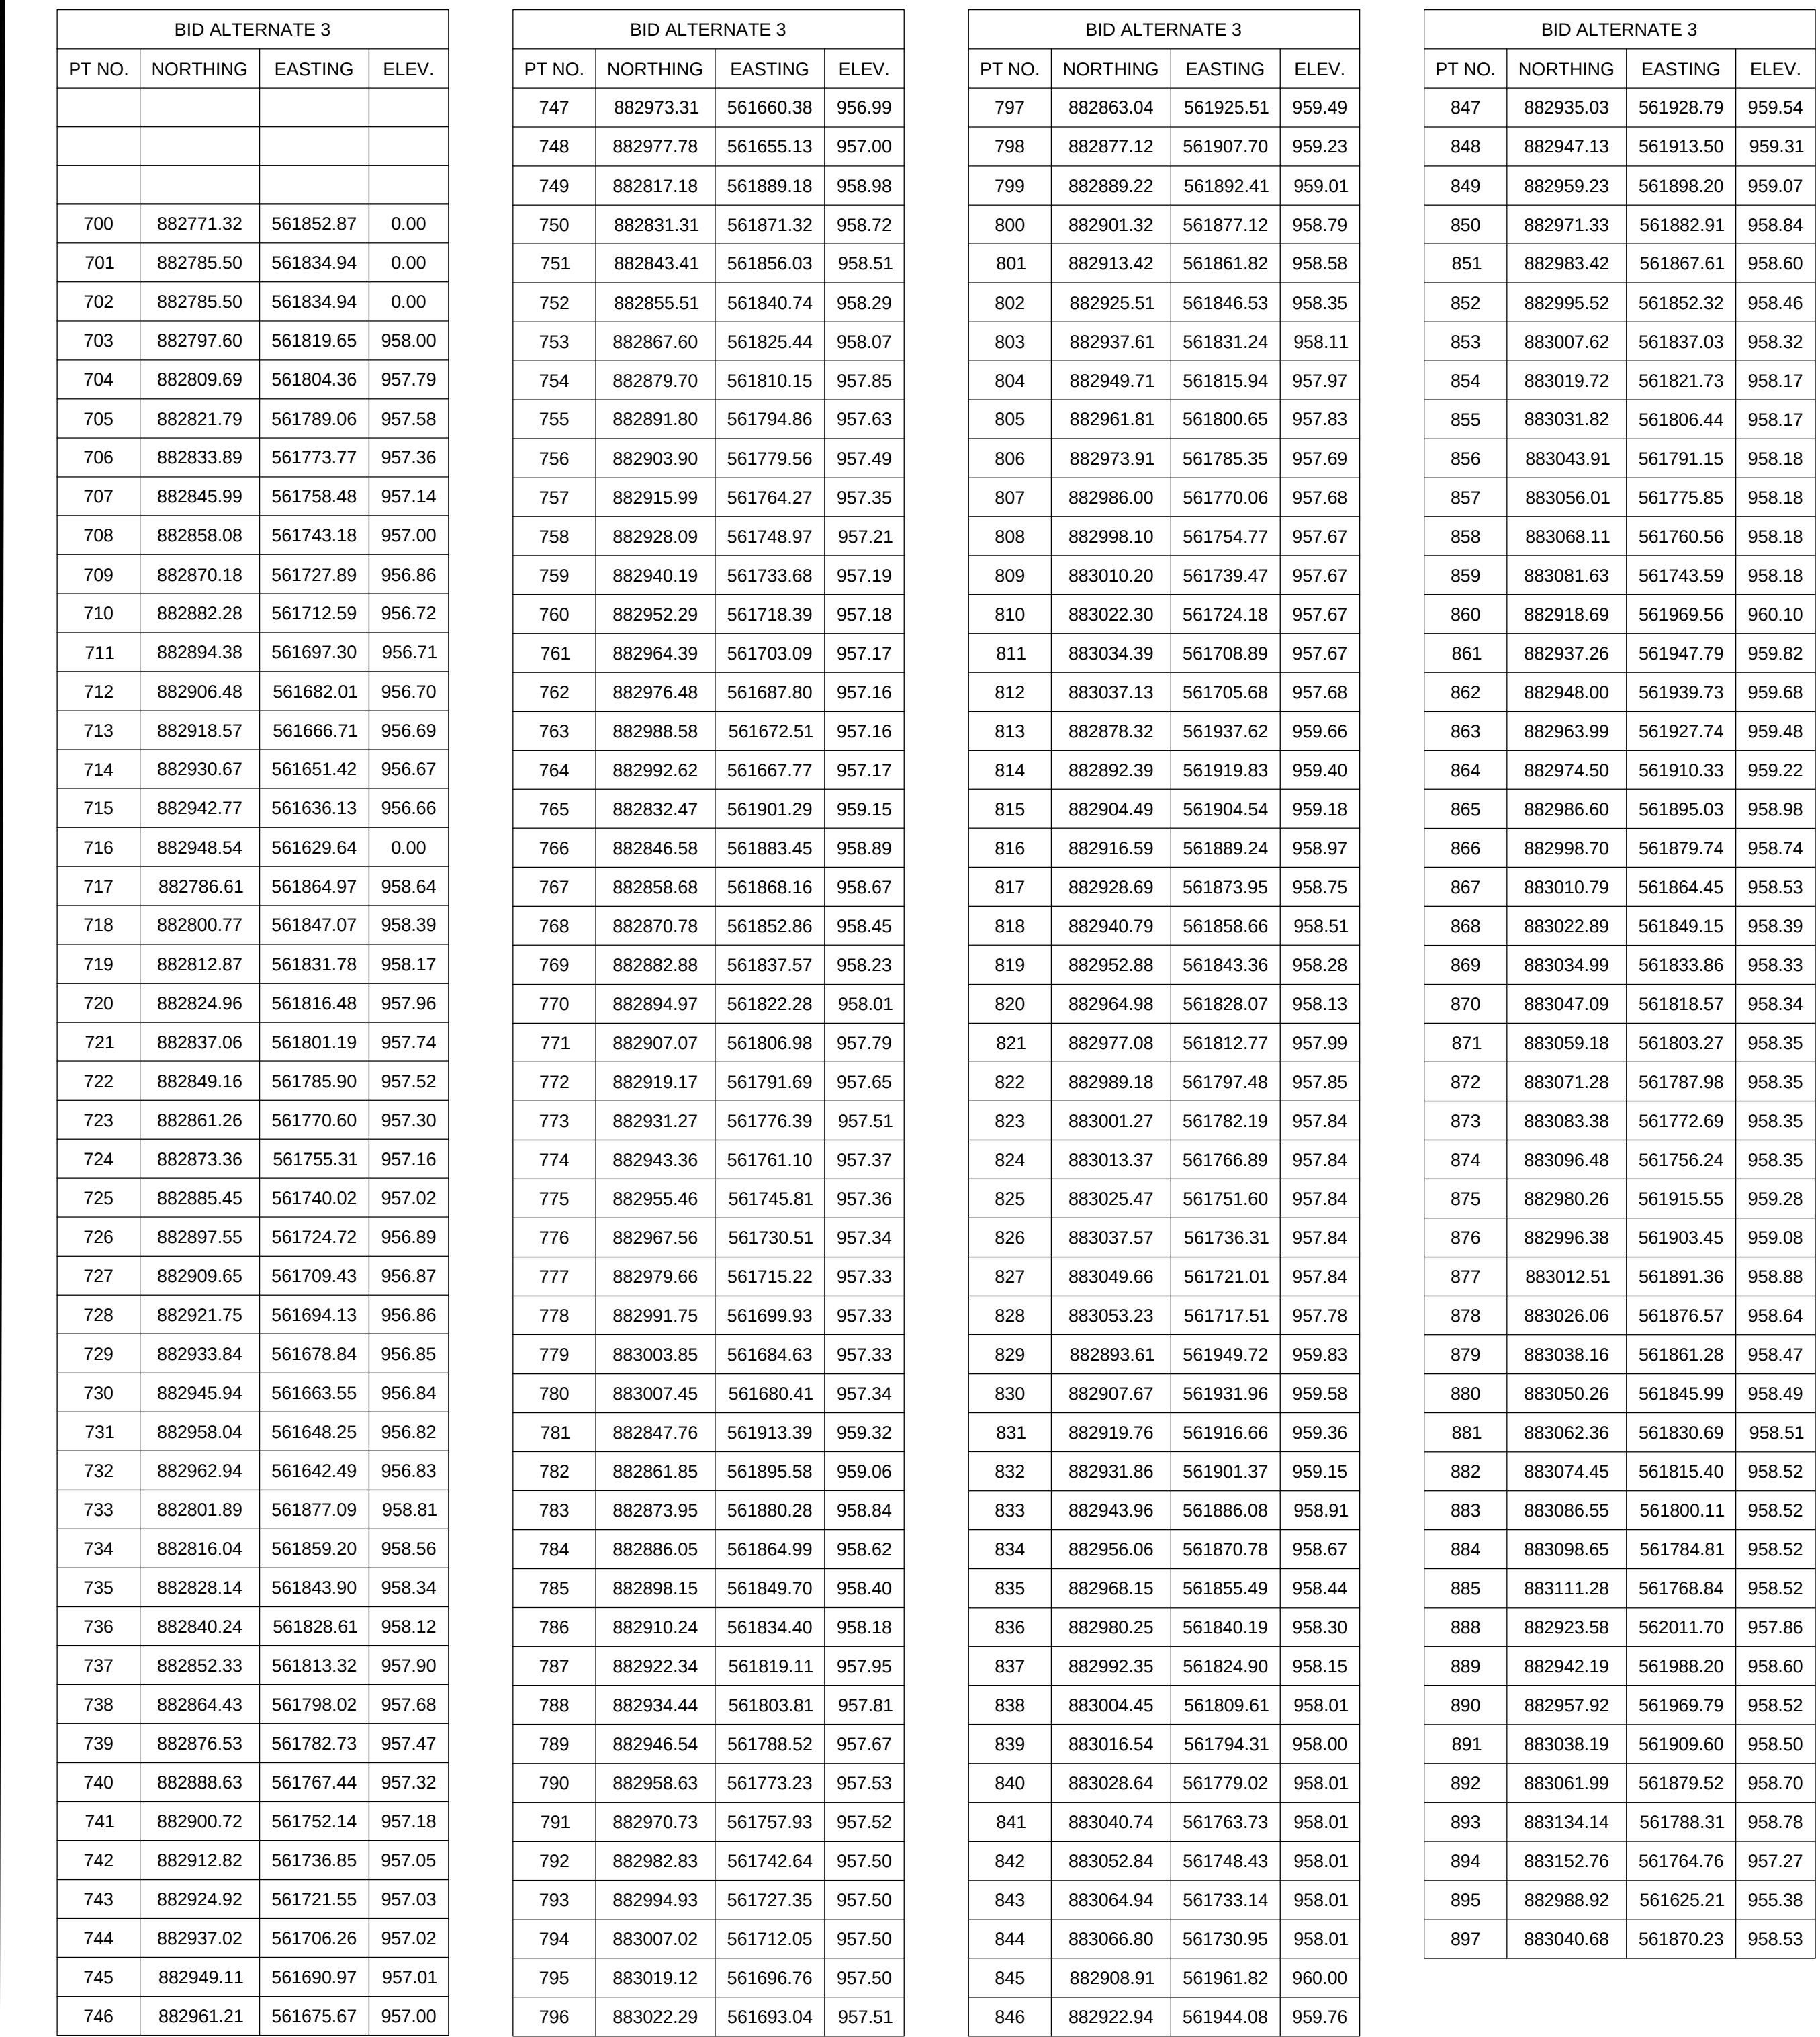

BID ALTERNATE 3				BID ALTERNATE 3				BID ALTERNATE 3				BID ALTERNATE 3			
PT NO.	NORTHING	EASTING	ELEV.	PT NO.	NORTHING	EASTING	ELEV.	PT NO.	NORTHING	EASTING	ELEV.	PT NO.	NORTHING	EASTING	ELEV.
				747	882973.31	561660.38	956.99	797	882863.04	561925.51	959.49	847	882935.03	561928.79	959.54
				748	882977.18	561655.13	957.00	798	882877.12	561907.70	959.23	848	882947.13	561913.50	959.31
				749	882817.18	561889.18	958.98	799	882889.22	561892.41	959.01	849	882958.23	561898.20	959.07
700	882771.32	561852.87	0.00	750	882831.31	561871.32	958.72	800	882901.32	561877.12	958.79	850	882971.33	561882.91	958.84
701	882785.50	561834.94	0.00	751	882843.41	561856.03	958.51	801	882913.42	561861.82	958.58	851	882983.42	561867.61	958.60
702	882785.50	561834.94	0.00	752	882855.51	561840.74	958.29	802	882925.51	561846.53	958.35	852	882995.52	561852.32	958.46
703	882797.60	561819.65	958.00	753	882867.60	561825.44	958.07	803	882937.61	561831.24	958.11	853	883007.62	561837.03	958.32
704	882809.69	561804.36	957.79	754	882879.70	561810.15	957.85	804	882949.71	561815.94	957.97	854	883019.72	561821.73	958.17
705	882821.79	561789.06	957.58	755	882891.80	561794.86	957.63	805	882961.81	561800.65	957.83	855	883031.82	561806.44	958.17
706	882833.89	561773.77	957.36	756	882903.90	561779.56	957.49	806	882973.91	561785.35	957.69	856	883043.91	561791.15	958.18
707	882845.99	561758.48	957.14	757	882915.99	561764.27	957.35	807	882986.00	561770.06	957.68	857	883056.01	561775.85	958.18
708	882858.08	561743.18	957.00	758	882928.09	561748.97	957.21	808	882998.10	561754.77	957.67	858	883068.11	561760.56	958.18
709	882870.18	561727.89	956.86	759	882940.19	561733.68	957.19	809	883010.20	561739.47	957.67	859	883081.63	561743.59	958.18
710	882882.28	561712.59	956.72	760	882952.29	561718.39	957.18	810	883022.30	561724.18	957.67	860	882918.69	561969.56	960.10
711	882894.38	561697.30	956.71	761	882964.39	561703.09	957.17	811	883034.39	561708.89	957.67	861	882937.26	561947.79	959.82
712	882906.48	561682.01	956.70	762	882976.48	561687.80	957.16	812	883037.13	561705.68	957.68	862	882948.00	561939.73	959.68
713	882918.57	561666.71	956.69	763	882988.58	561672.51	957.16	813	882878.32	561937.62	959.66	863	882963.99	561927.74	959.48
714	882930.67	561651.42	956.67	764	882992.62	561667.77	957.17	814	882892.39	561919.83	959.40	864	882974.50	561910.33	959.22
715	882942.77	561636.13	956.66	765	882832.47	561901.29	959.15	815	882904.49	561904.54	959.18	865	882986.60	561895.03	958.98
716	882948.54	561629.64	0.00	766	882846.58	561883.45	958.89	816	882916.59	561889.24	958.97	866	882998.70	561879.74	958.74
717	882786.61	561864.97	958.64	767	882858.68	561868.16	958.67	817	882928.69	561873.95	958.75	867	883010.79	561864.45	958.53
718	882800.77	561847.07	958.39	768	882870.78	561852.86	958.45	818	882940.79	561858.66	958.51	868	883022.89	561849.15	958.39
719	882812.87	561831.78	958.17	769	882882.88	561837.57	958.23	819	882952.88	561843.36	958.28	869	883034.99	561833.86	958.33
720	882824.96	561816.48	957.96	770	882894.97	561822.28	958.01	820	882964.98	561828.07	958.13	870	883047.09	561818.57	958.34
721	882837.06	561801.19	957.74	771	882907.07	561806.98	957.79	821	882977.08	561812.77	957.99	871	883059.18	561803.27	958.35
722	882849.16	561785.90	957.52	772	882919.17	561791.69	957.65	822	882989.18	561797.48	957.85	872	883071.28	561787.98	958.35
723	882861.26	561770.60	957.30	773	882931.27	561776.39	957.51	823	883001.27	561782.19	957.84	873	883083.38	561772.69	958.35
724	882873.36	561755.31	957.16	774	882943.36	561761.10	957.37	824	883013.37	561766.89	957.84	874	883096.48	561756.24	958.35
725	882885.45	561740.02	957.02	775	882955.46	561745.81	957.36	825	883025.47	561751.60	957.84	875	883098.26	561751.55	959.28
726	882897.55	561724.72	956.89	776	882967.56	561730.51	957.34	826	883037.57	561736.31	957.84	876	882996.38	561903.45	959.08
727	882909.65	561709.43	956.87	777	882979.66	561715.22	957.33	827	883049.66	561721.01	957.84	877	883012.51	561891.36	958.88
728	882921.75	561694.13	956.86	778	882991.75	561699.93	957.33	828	883053.23	561717.51	957.78	878	883026.06	561876.57	958.64
729	882933.84	561678.84	956.85	779	883003.85	561684.63	957.33	829	882893.61	561949.72	959.83	879	883038.16	561861.28	958.47
730	882945.94	561663.55	956.84	780	883007.45	561680.41	957.34	830	882907.67	561931.96	959.58	880	883050.26	561845.99	958.49
731	882958.04	561648.25	956.82	781	882847.76	561913.39	959.32	831	882919.76	561916.66	959.36	881	883062.36	561830.69	958.51
732	882962.94	561642.49	956.83	782	882861.85	561895.58	959.06	832	882931.86	561901.37	959.15	882	883074.45	561815.40	958.52
733	882801.89	561877.09	958.81	783	882873.95	561880.28	958.84	833	882943.96	561886.08	958.91	883	883086.55	561800.11	958.52
734	882816.04	561859.20	958.56	784	882886.05	561864.99	958.62	834	882956.06	561870.78	958.67	884	883098.65	561784.81	958.52
735	882828.14	561843.90	958.34	785	882898.15	561849.70	958.40	835	882968.15	561855.49	958.44	885	883111.28	561768.84	958.52
736	882840.24	561828.61	958.12	786	882910.24	561834.40	958.18	836	882980.25	561840.19	958.30	888	882923.58	562011.70	957.86
737	882852.33	561813.32	957.90	787	882922.34	561819.11	957.95	837	882992.35	561824.90	958.15	889	882942.19	561988.20	958.60
738	882864.43	561798.02	957.68	788	882934.44	561803.81	957.81	838	883004.45	561809.61	958.01	890	882957.92	561969.79	958.52
739	882876.53	561782.73	957.47	789	882946.54	561788.52	957.67	839	883016.54	561794.31	958.00	891	883038.19	561909.60	958.50
740	882888.63	561767.44	957.32	790	882958.63	561773.23	957.53	840	883028.64	561779.02	958.01	892	883061.99	561879.52	958.70
741	882900.72	561752.14	957.18	791	882970.73	561757.93	957.52	841	883040.74	561763.73	958.01	893	883134.14	561788.31	958.78
742	882912.82	561736.85	957.05	792	882982.83	561742.64	957.50	842	883052.84	561748.43	958.01	894	883152.76	561764.76	957.27
743	882924.92	561721.55	957.03	793	882994.93	561727.35	957.50	843	883064.94	561733.14	958.01	895	882988.92	561625.21	955.38
744	882937.02	561706.26	957.02	794	883007.02	561712.05	957.50	844	883068.60	561730.95	958.01	897	883040.68	561870.23	958.53
745	882949.11	561690.97	957.01	795	883019.12	561696.76	957.50	845	882908.91	561961.82	960.00				
746	882961.21	561675.67	957.00	796	883022.29	561693.04	957.51	846	882922.94	561944.08	959.76				

PER CITY OF PHOENIX CODE CHAPTER 2, SECTION 2-28. THESE PLANS ARE FOR OFFICIAL USE ONLY AND MAY NOT BE SHARED WITH OTHERS EXCEPT AS REQUIRED TO FULFILL THE OBLIGATIONS OF CONTRACTOR'S CONTRACT WITH THE CITY OF PHOENIX.

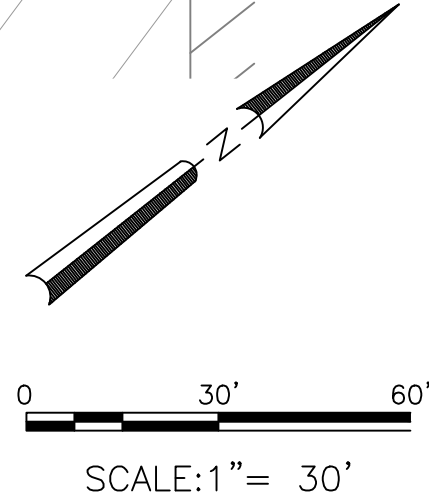


- | | |
|-----------|---------------|
| D4 | LEGEND |
| | NOT TO SCALE |

A3	BASE BID POINT TABLE
	NOT TO SCALE





PER CITY OF PHOENIX CODE CHAPTER 2, SECTION 2-28. THESE PLANS ARE FOR OFFICIAL USE ONLY AND MAY NOT BE SHARED WITH OTHERS EXCEPT AS REQUIRED TO FULFILL THE OBLIGATIONS OF CONTRACTOR'S CONTRACT WITH THE CITY OF PHOENIX.

X CODE CHAPTER 2, SECTION 2-28. THESE PLANS ARE FOR
AND MAY NOT BE SHARED WITH OTHERS EXCEPT AS REQUIRED TO
TIONS OF CONTRACTOR'S CONTRACT WITH THE CITY OF PHOENIX.

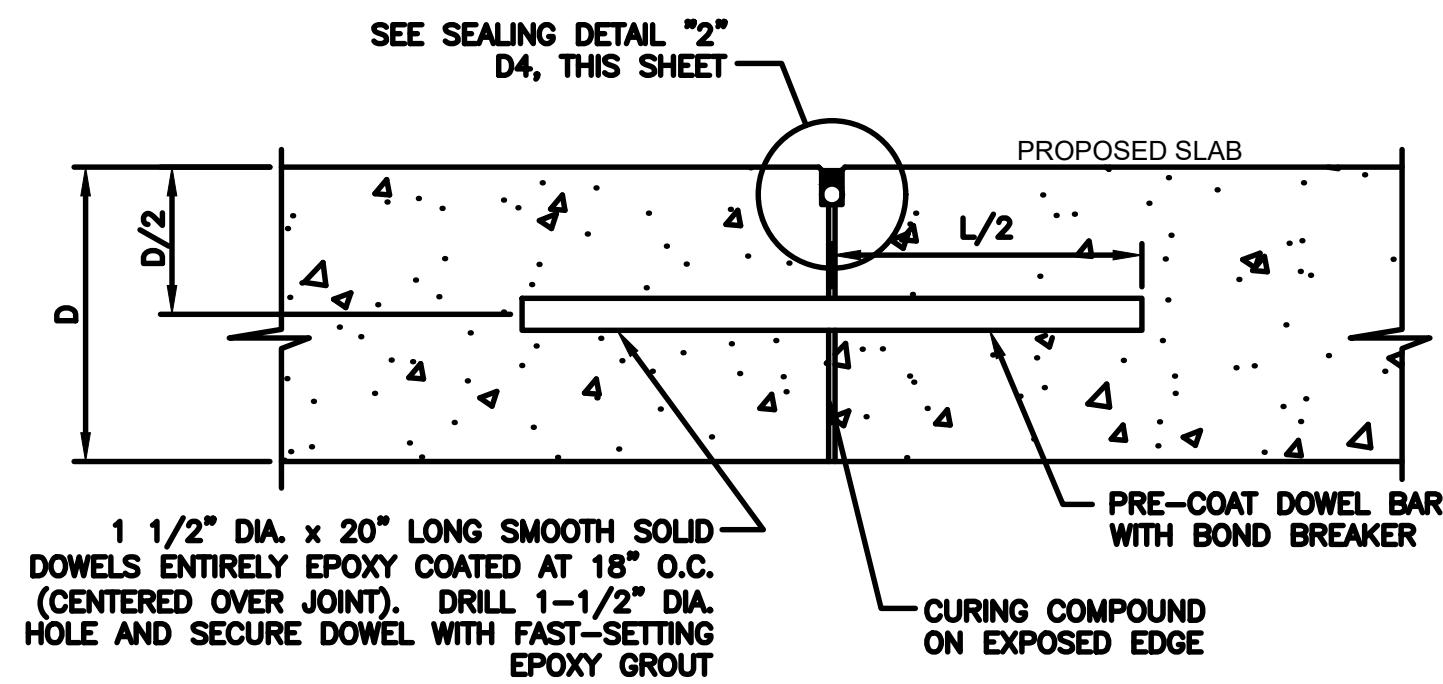




NOTES:

1. REMOVE PLASTIC EPOXY RETENTION RINGS AROUND DOWEL BARS PRIOR TO PLACEMENT OF ADJACENT SLAB


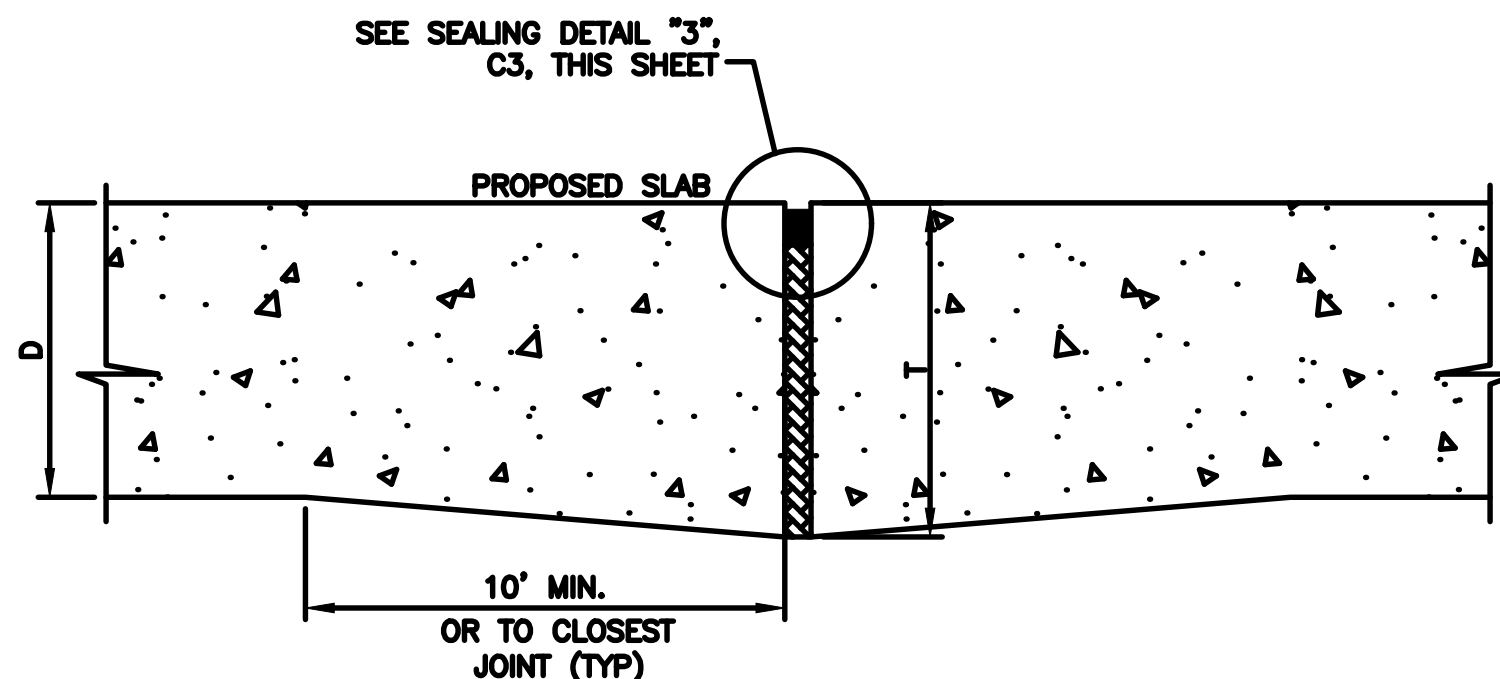
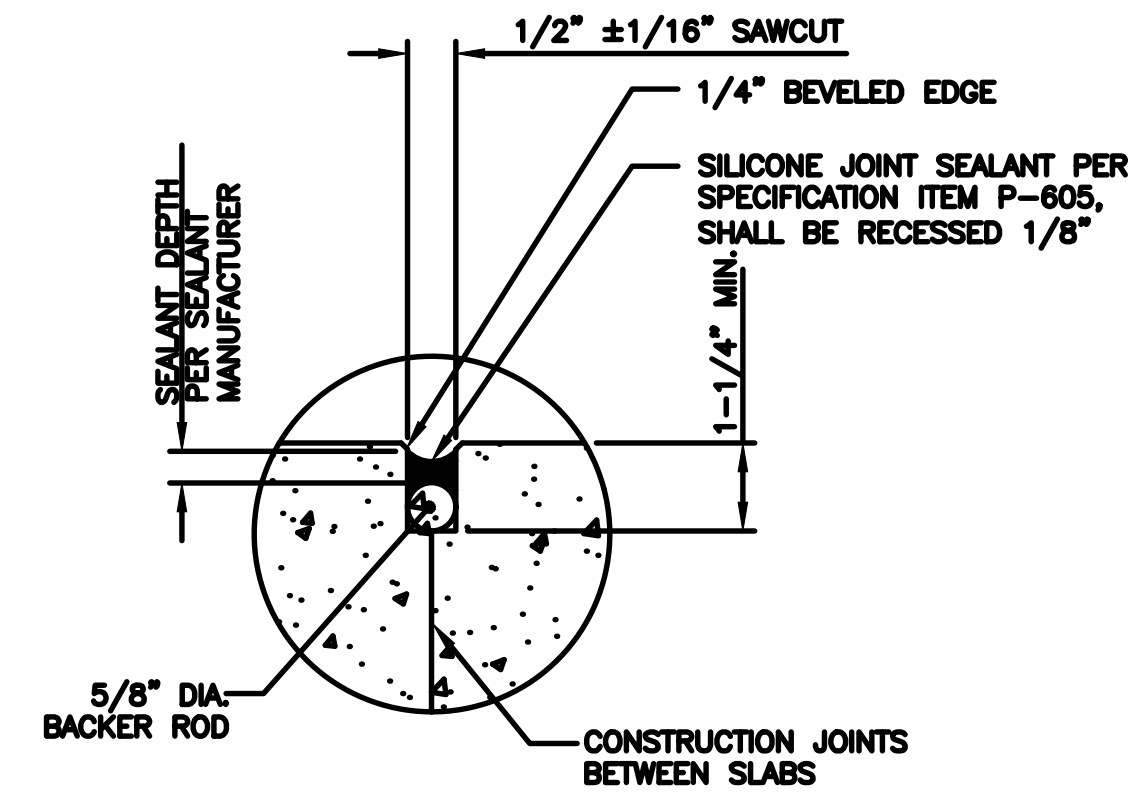
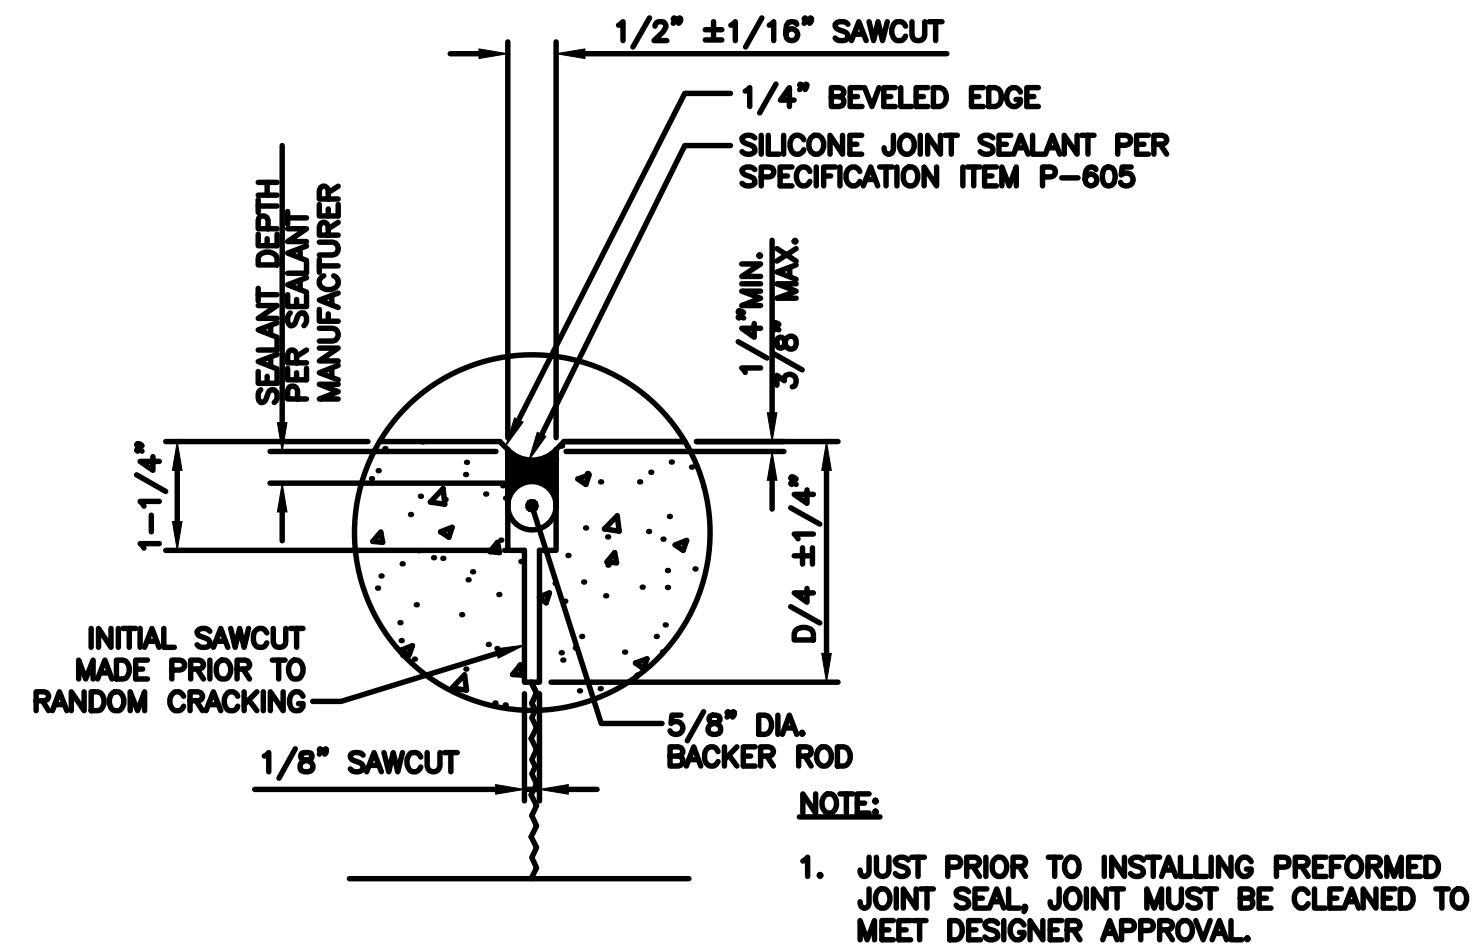
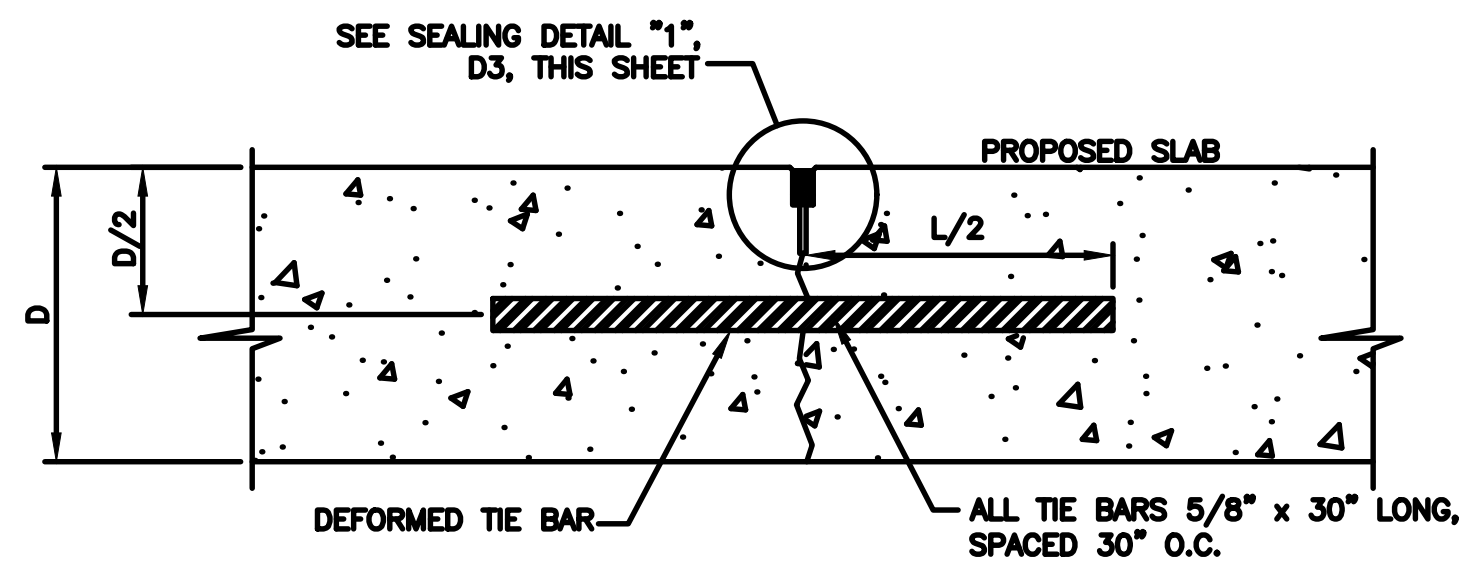


NOTES


1. FOR TYPE B, THICKENED EDGE SLABS, THE P -209 SHALL BE CONSTRUCTED TO FULL DEPTHS. COST FOR MODIFYING THESE COURSES SHALL BE CONSIDERED INCIDENTAL TO ITEM P-501.
2. FOR TYPE B JOINT AT TRENCH DRAIN AND DRAINAGE STRUCTURES, SEE DETAIL C2/C-18
3. T = 1.25D

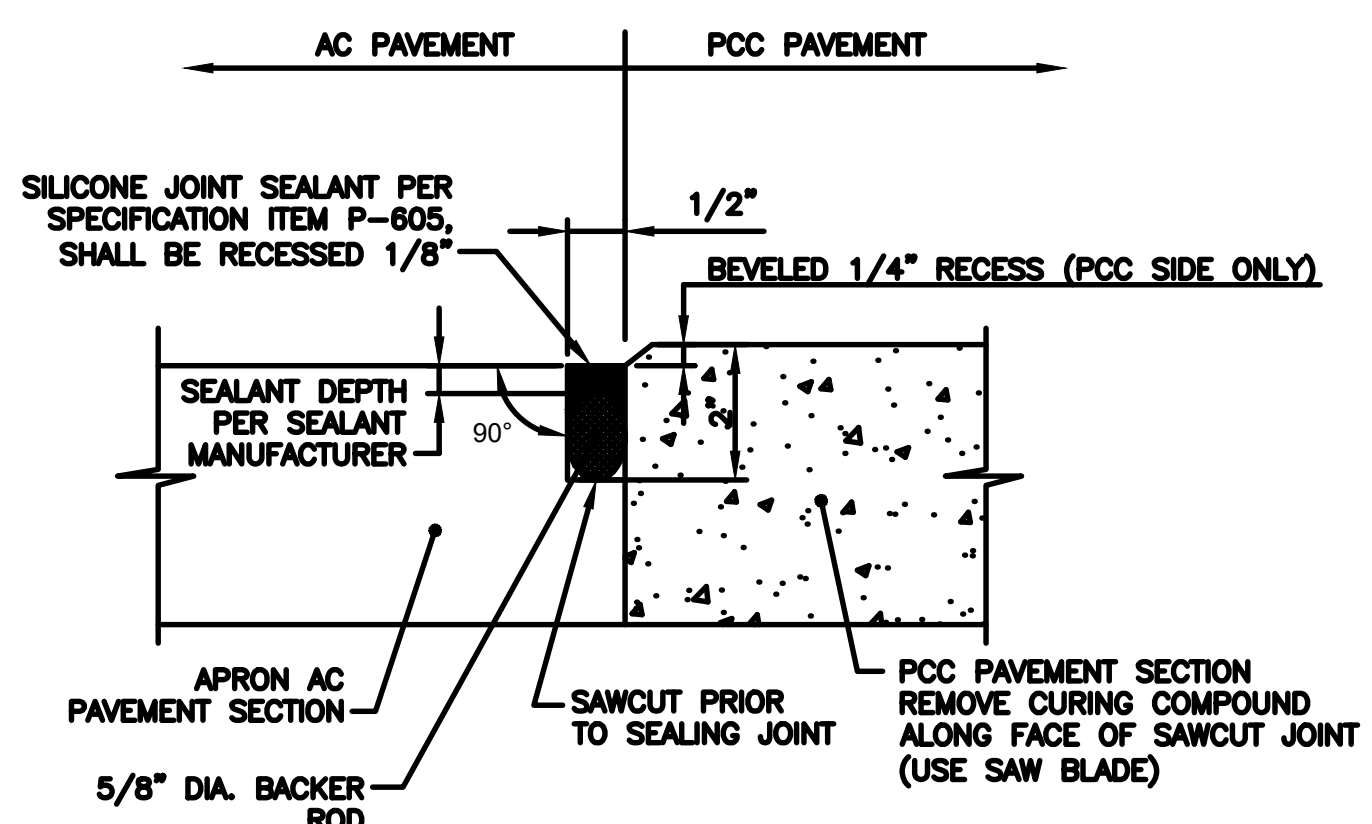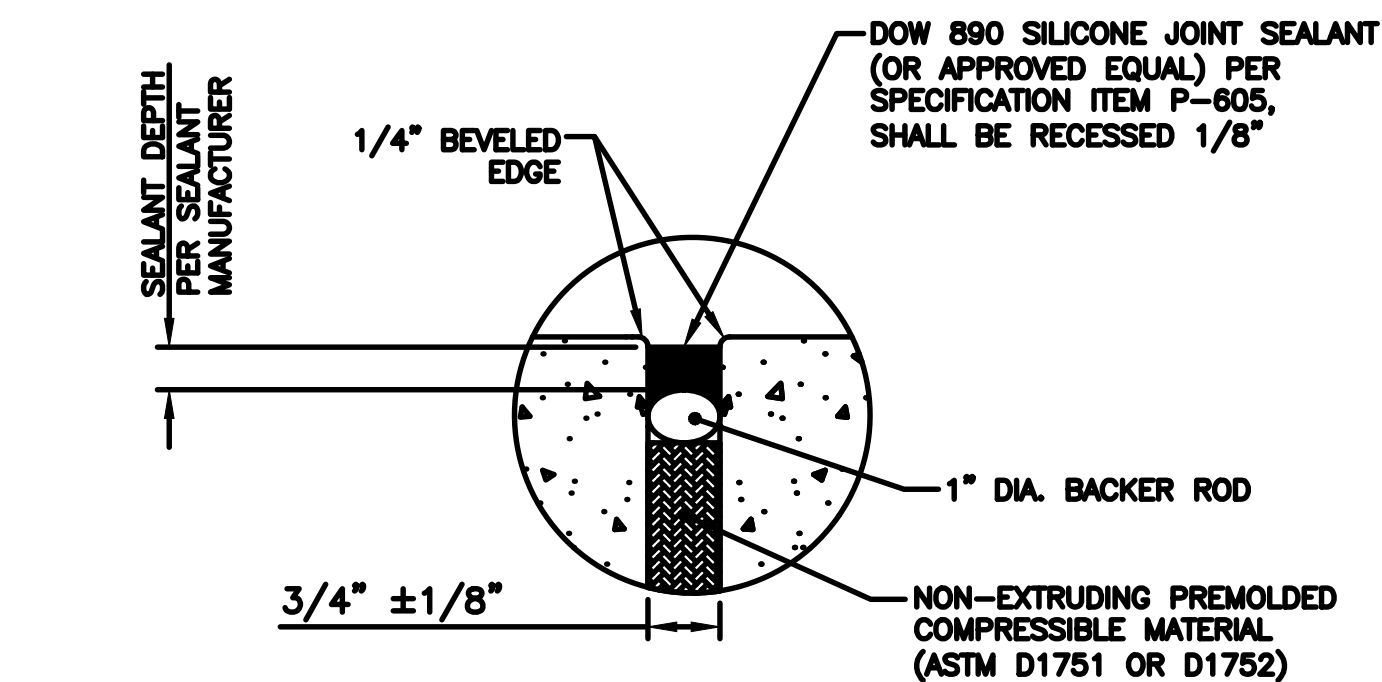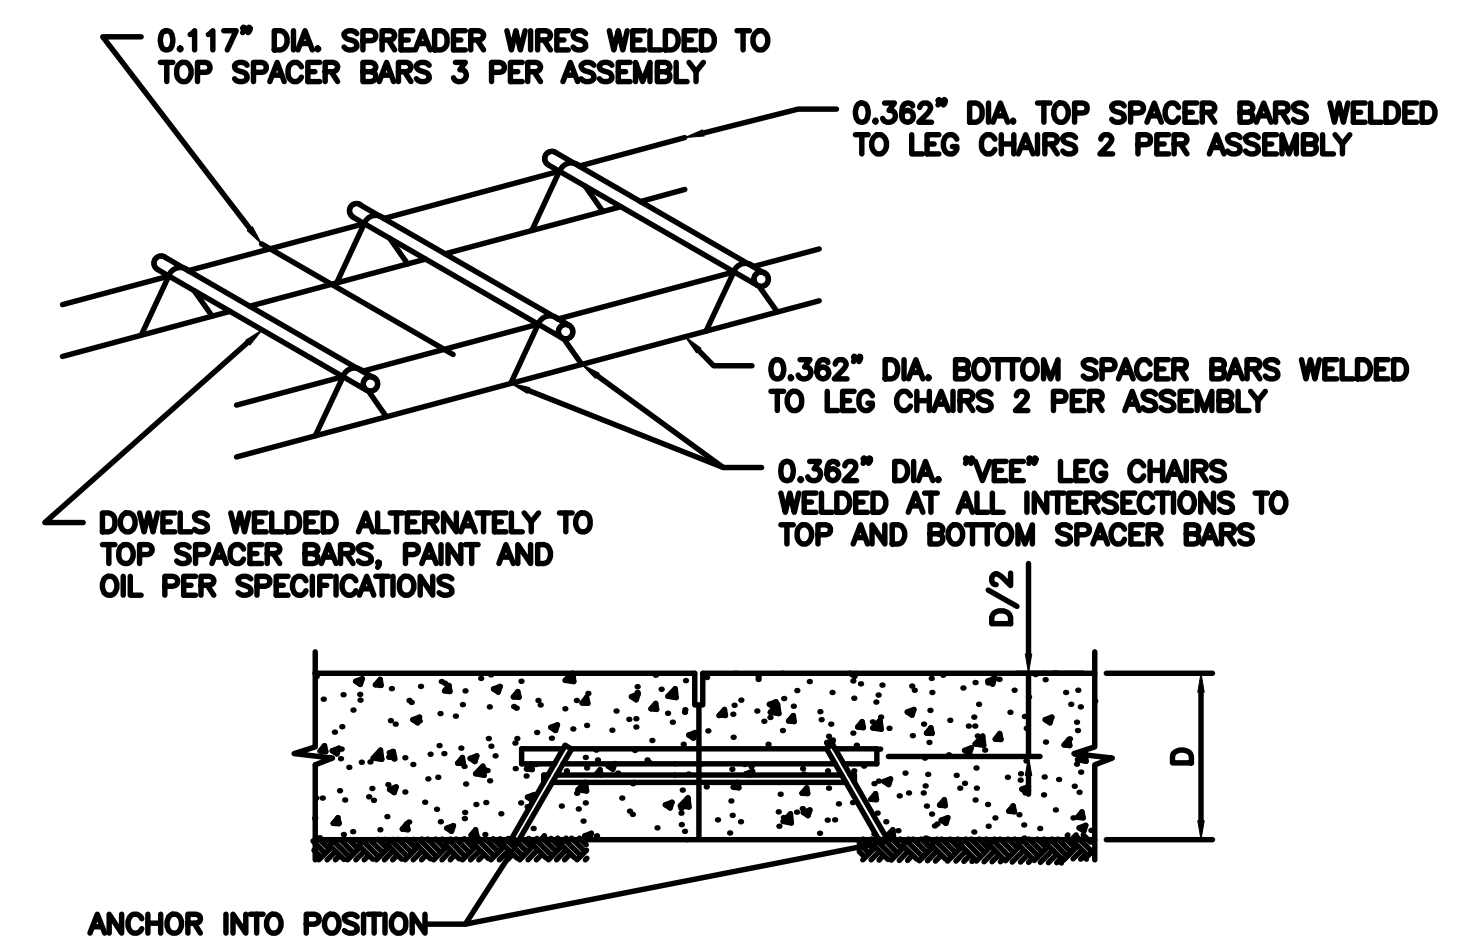

1. A TRANSVERSE CONSTRUCTION JOINT SHALL BE INSTALLED AT A PLANNED JOINT WHEN PAVING OPERATIONS ARE INTERRUPTED FOR MORE THAN A HALF AN HOUR (30 MINUTES). IF AN INTERRUPTION OCCURS BETWEEN PLANNED JOINTS, THE FRESH CONCRETE SHALL BE REMOVED BACK TO THE PREVIOUSLY INSTALLED JOINT. NO JOINTS WILL BE ALLOWED BETWEEN THE JOINTS SHOWN WITHIN THESE PLANS.
2. EDGES OF CONCRETE SLABS SHALL BE COVERED WITH AN APPROVED CURING MATERIAL AT THE SAME TIME AS THE SURFACE IS CURED. AT FORMED LOCATIONS, SLAB SIDES SHALL BE CURED WHEN FORMS ARE REMOVED.
3. THE PRE-FORMED JOINT SEAL IN TRANSVERSE (CONTRACTION) JOINTS SHALL BE INSTALLED IN ONE CONTINUOUS PIECE ACROSS THE APRON. THE LONGITUDINAL (CONSTRUCTION) JOINT SEALANT SHALL BE INTERRUPTED AT EVERY TRANSVERSE JOINT THROUGHOUT ITS LENGTH. SEALANT RESERVOIR SHAPE FACTOR (W/D) SHALL BE PER THE SEALANT MANUFACTURER'S INSTRUCTION RECOMMENDATIONS. ALL JOINT SEALANT RESERVOIRS SHOWN WITHIN THESE PLANS SHALL BE VERIFIED BY THE SEALANT MANUFACTURER PRIOR TO CONSTRUCTION (REFERENCE SPECIFICATIONS P-804 AND P-805 FOR MORE INFORMATION).
4. THE COST OF MODIFYING THE UNDERLYING PAVEMENT COURSES TO ACCOMMODATE THE CONCRETE PAVEMENT THICKENED EDGE IS INCIDENTAL TO ITEM P-501. NO SEPARATE PAYMENT WILL BE MADE FOR NECESSARY MODIFICATIONS.

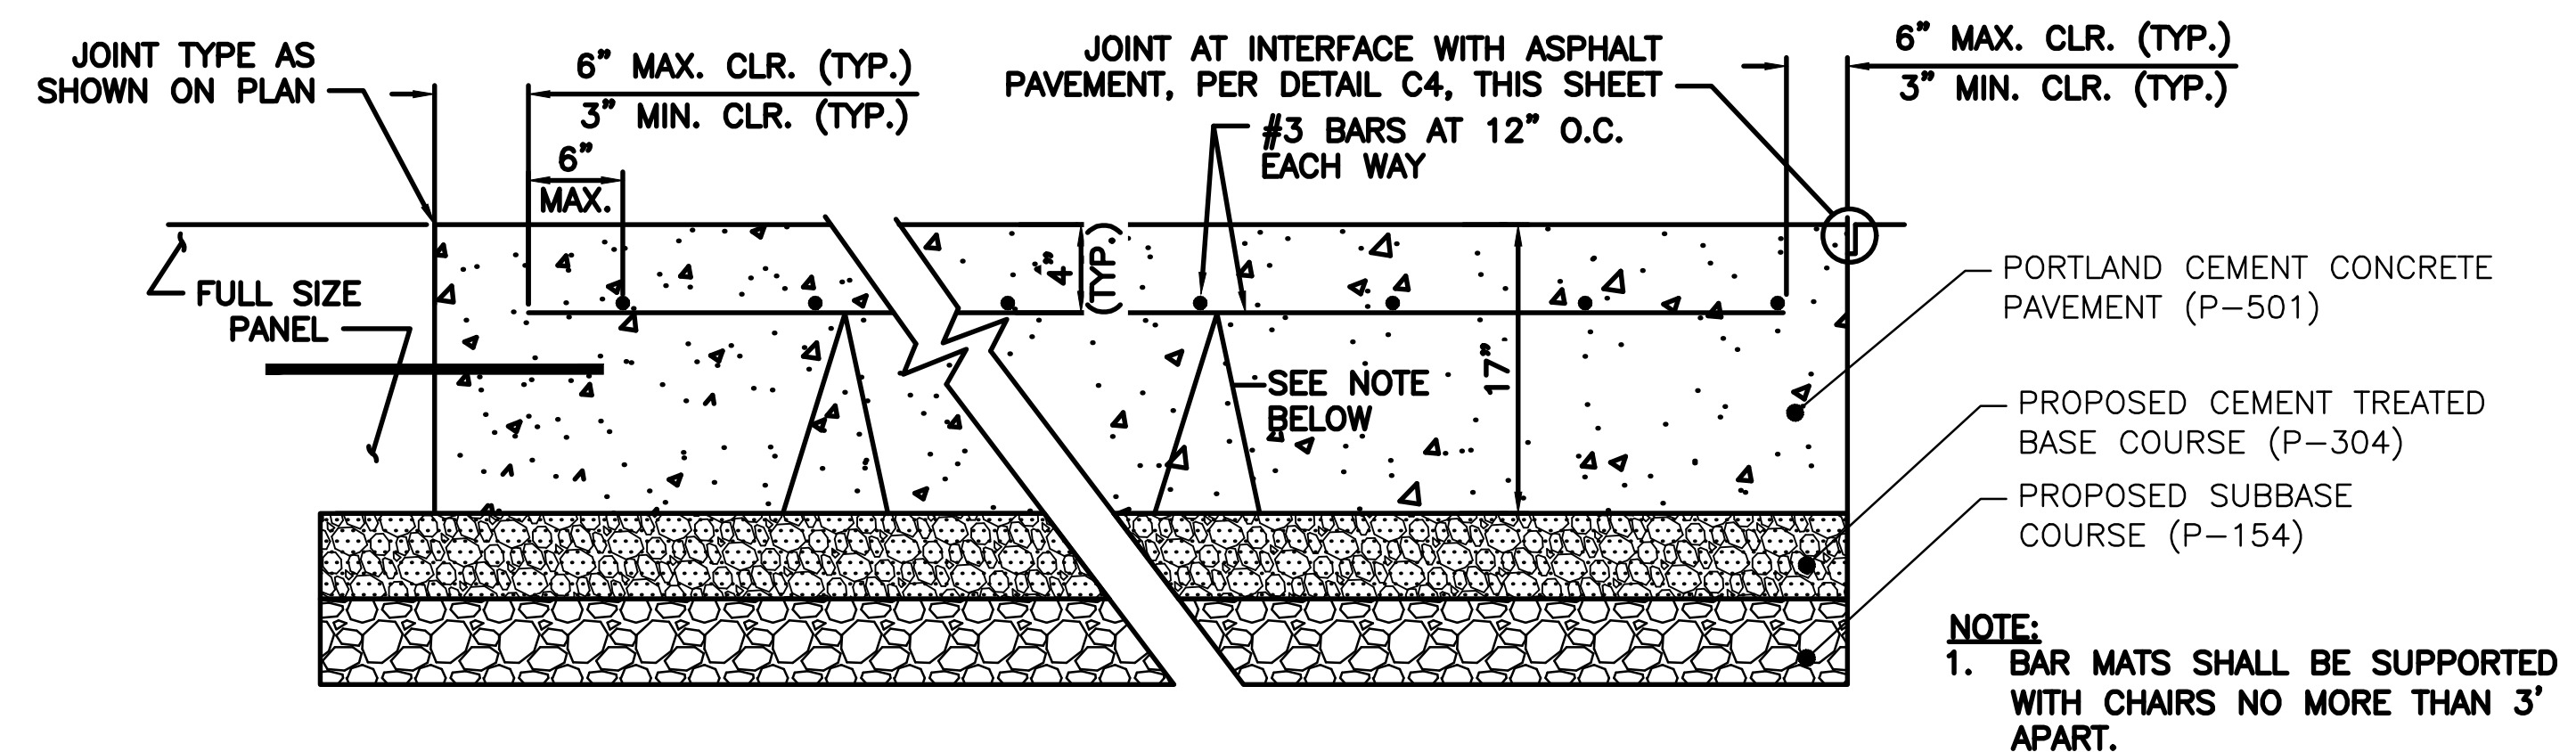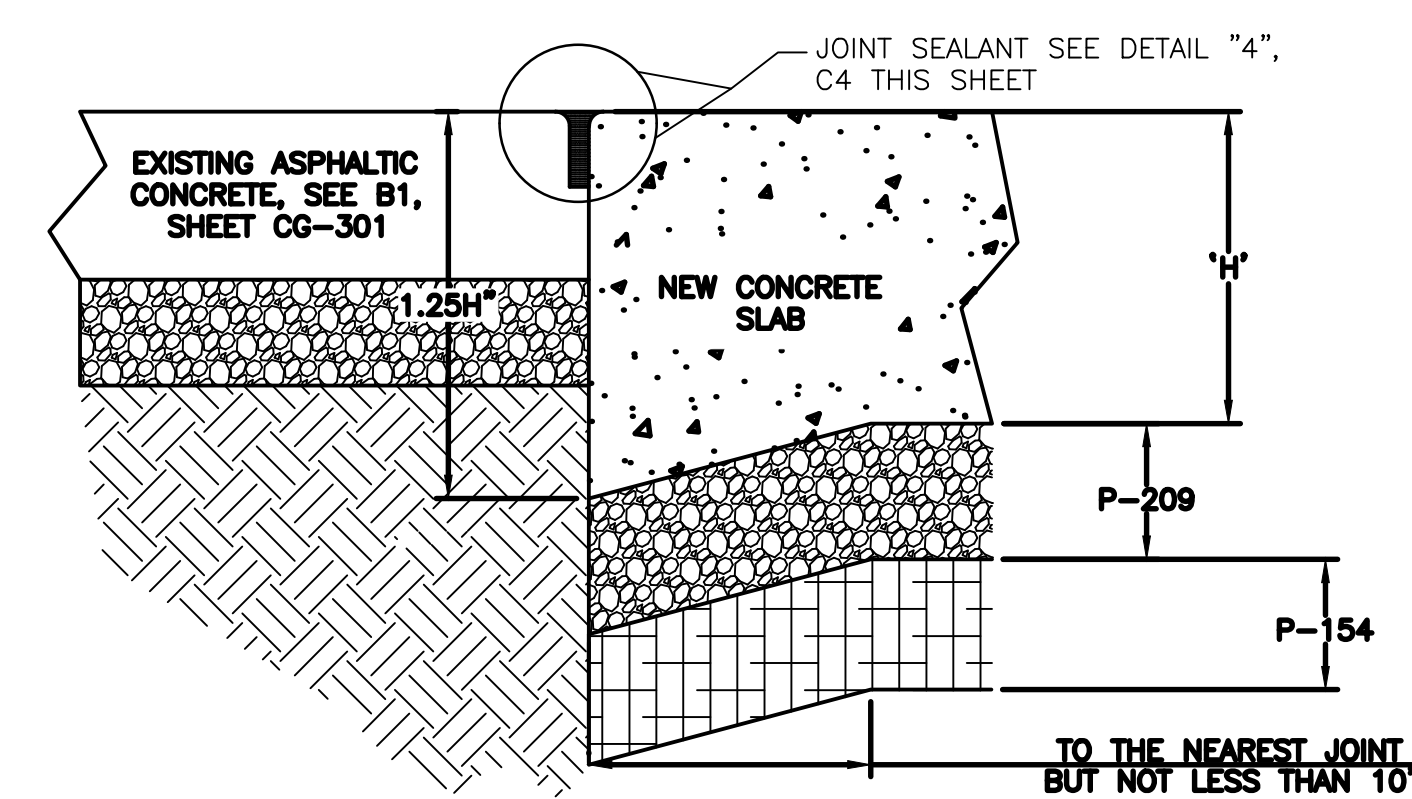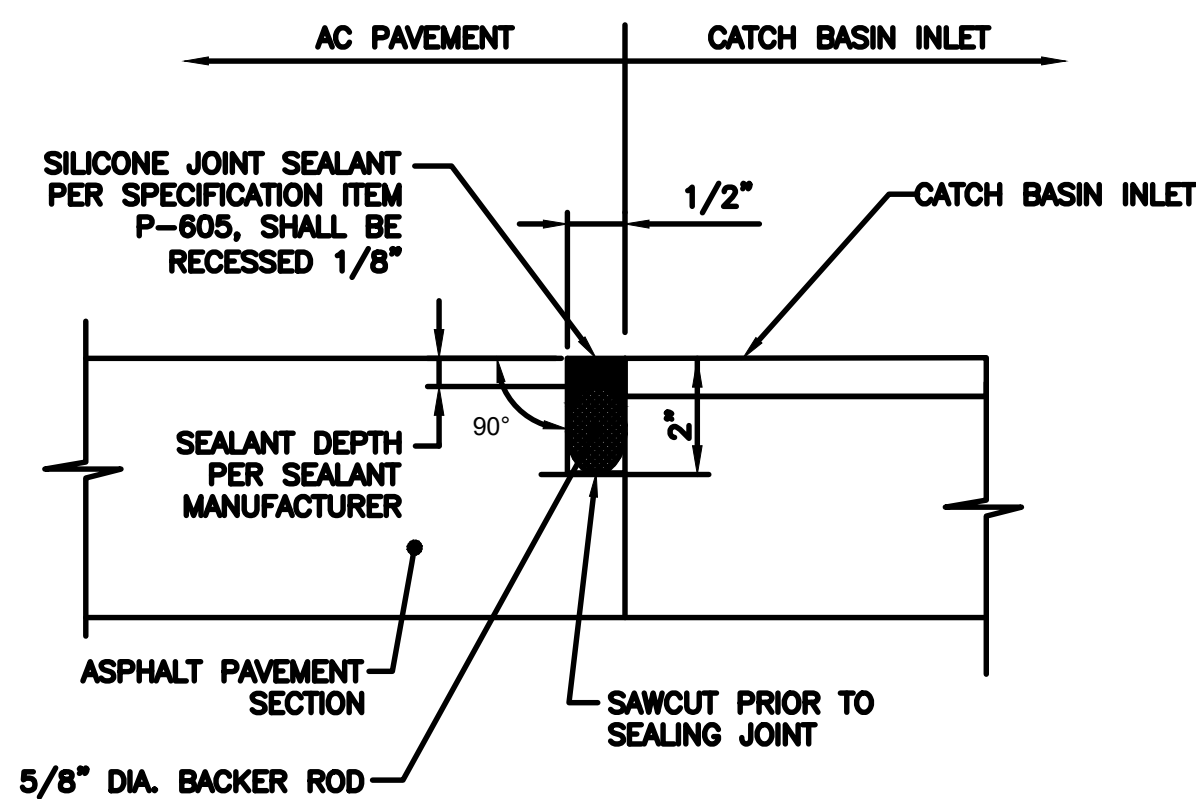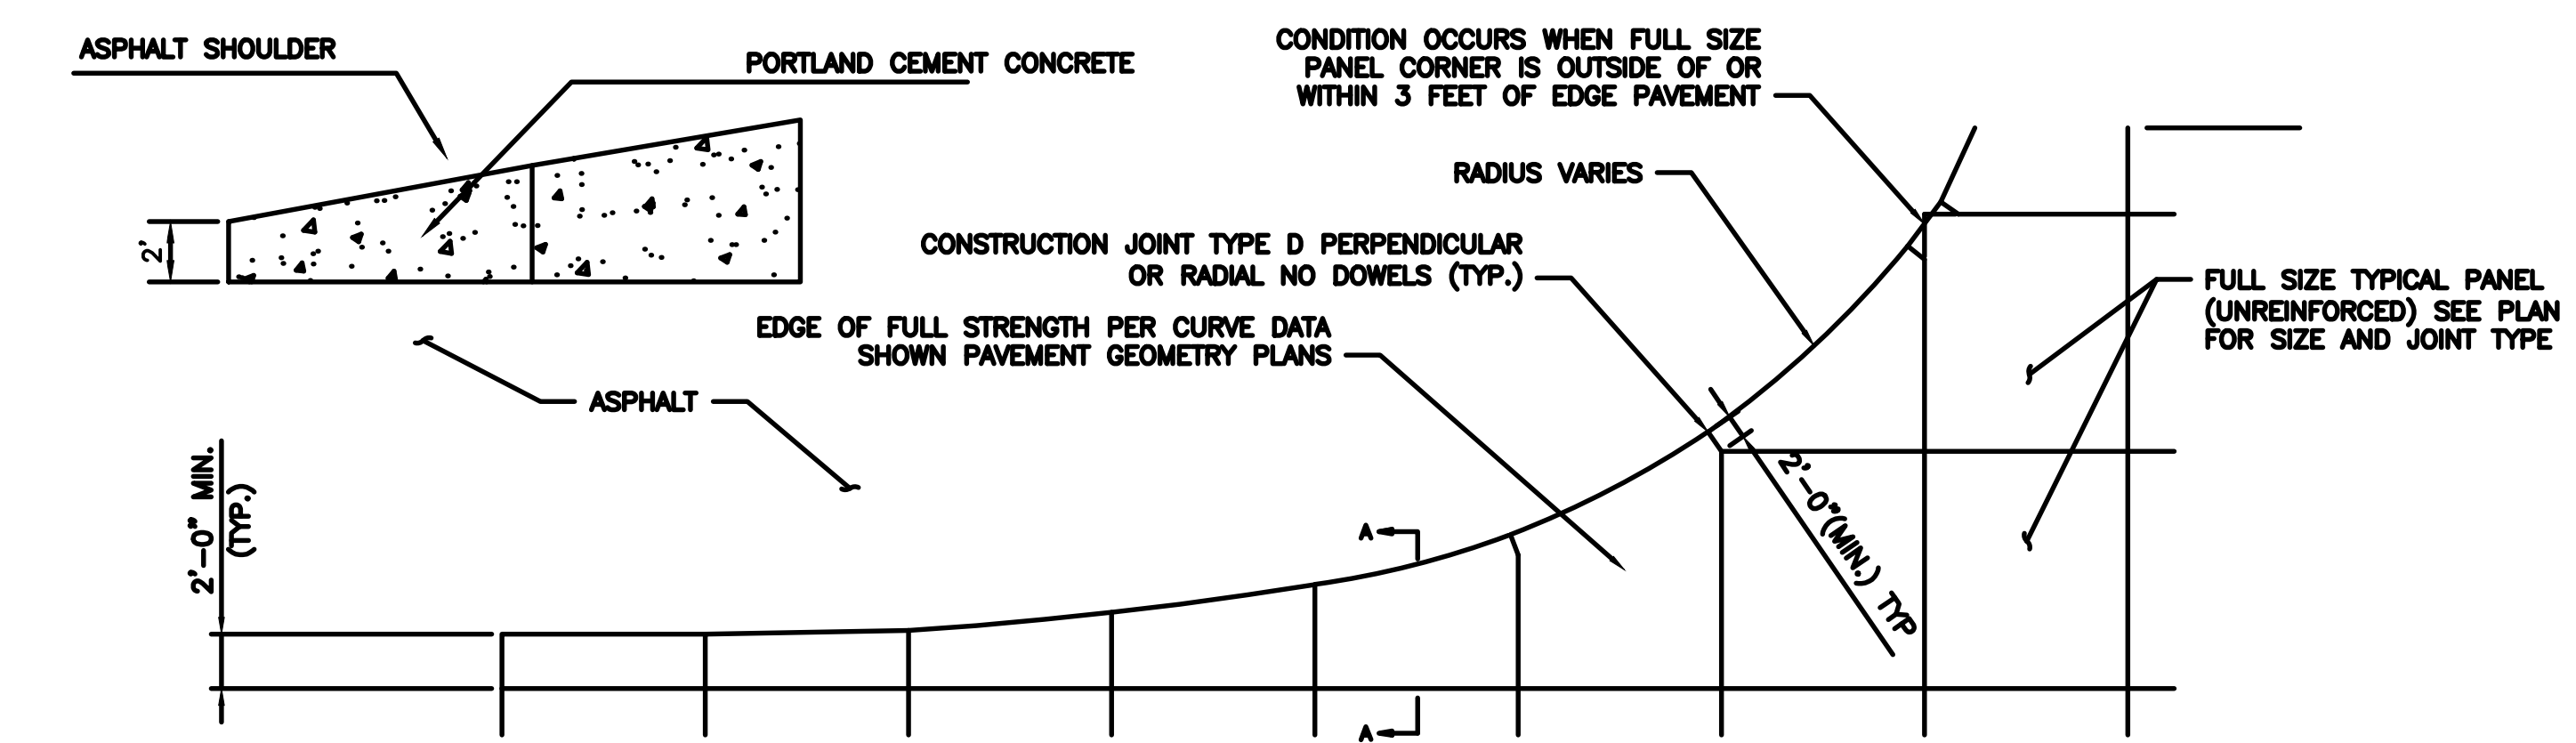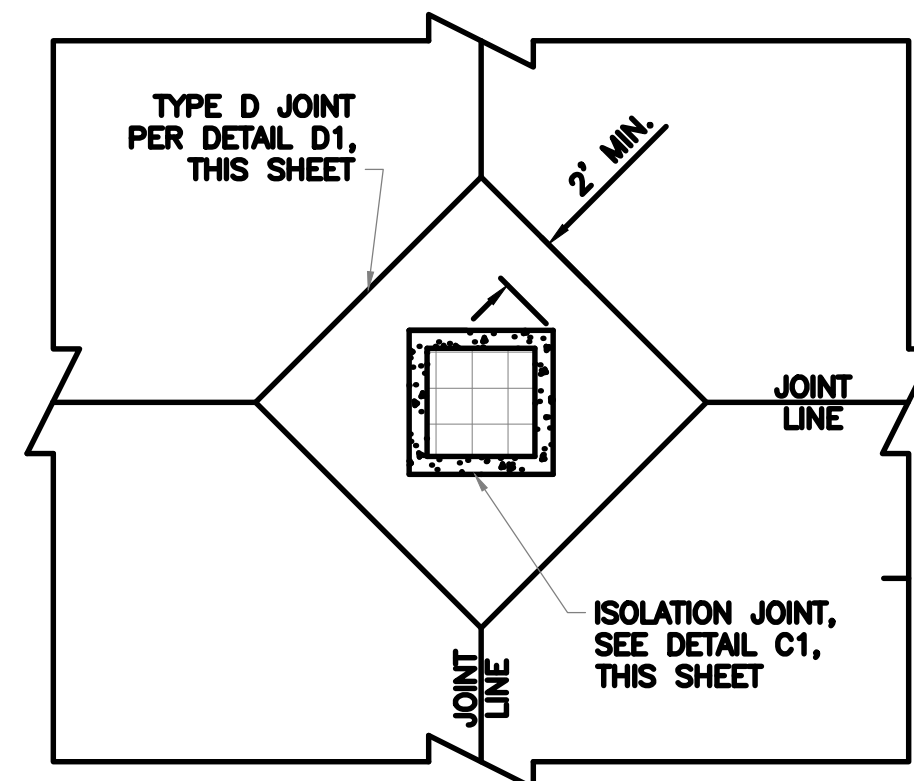


PER CITY OF PHOENIX CODE CHAPTER 2, SECTION 2-28. THESE PLANS ARE FOR OFFICIAL USE ONLY AND MAY NOT BE SHARED WITH OTHERS EXCEPT AS REQUIRED TO FULFILL THE OBLIGATIONS OF CONTRACTOR'S CONTRACT WITH THE CITY OF PHOENIX.

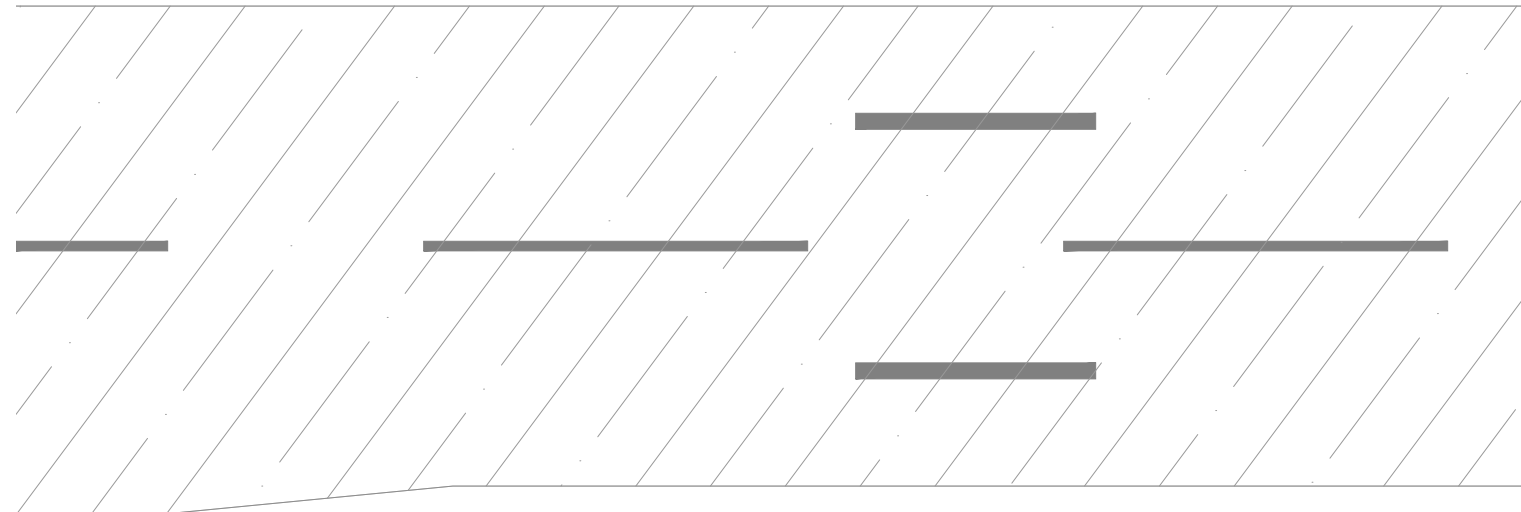

TW
A4

TW
A3

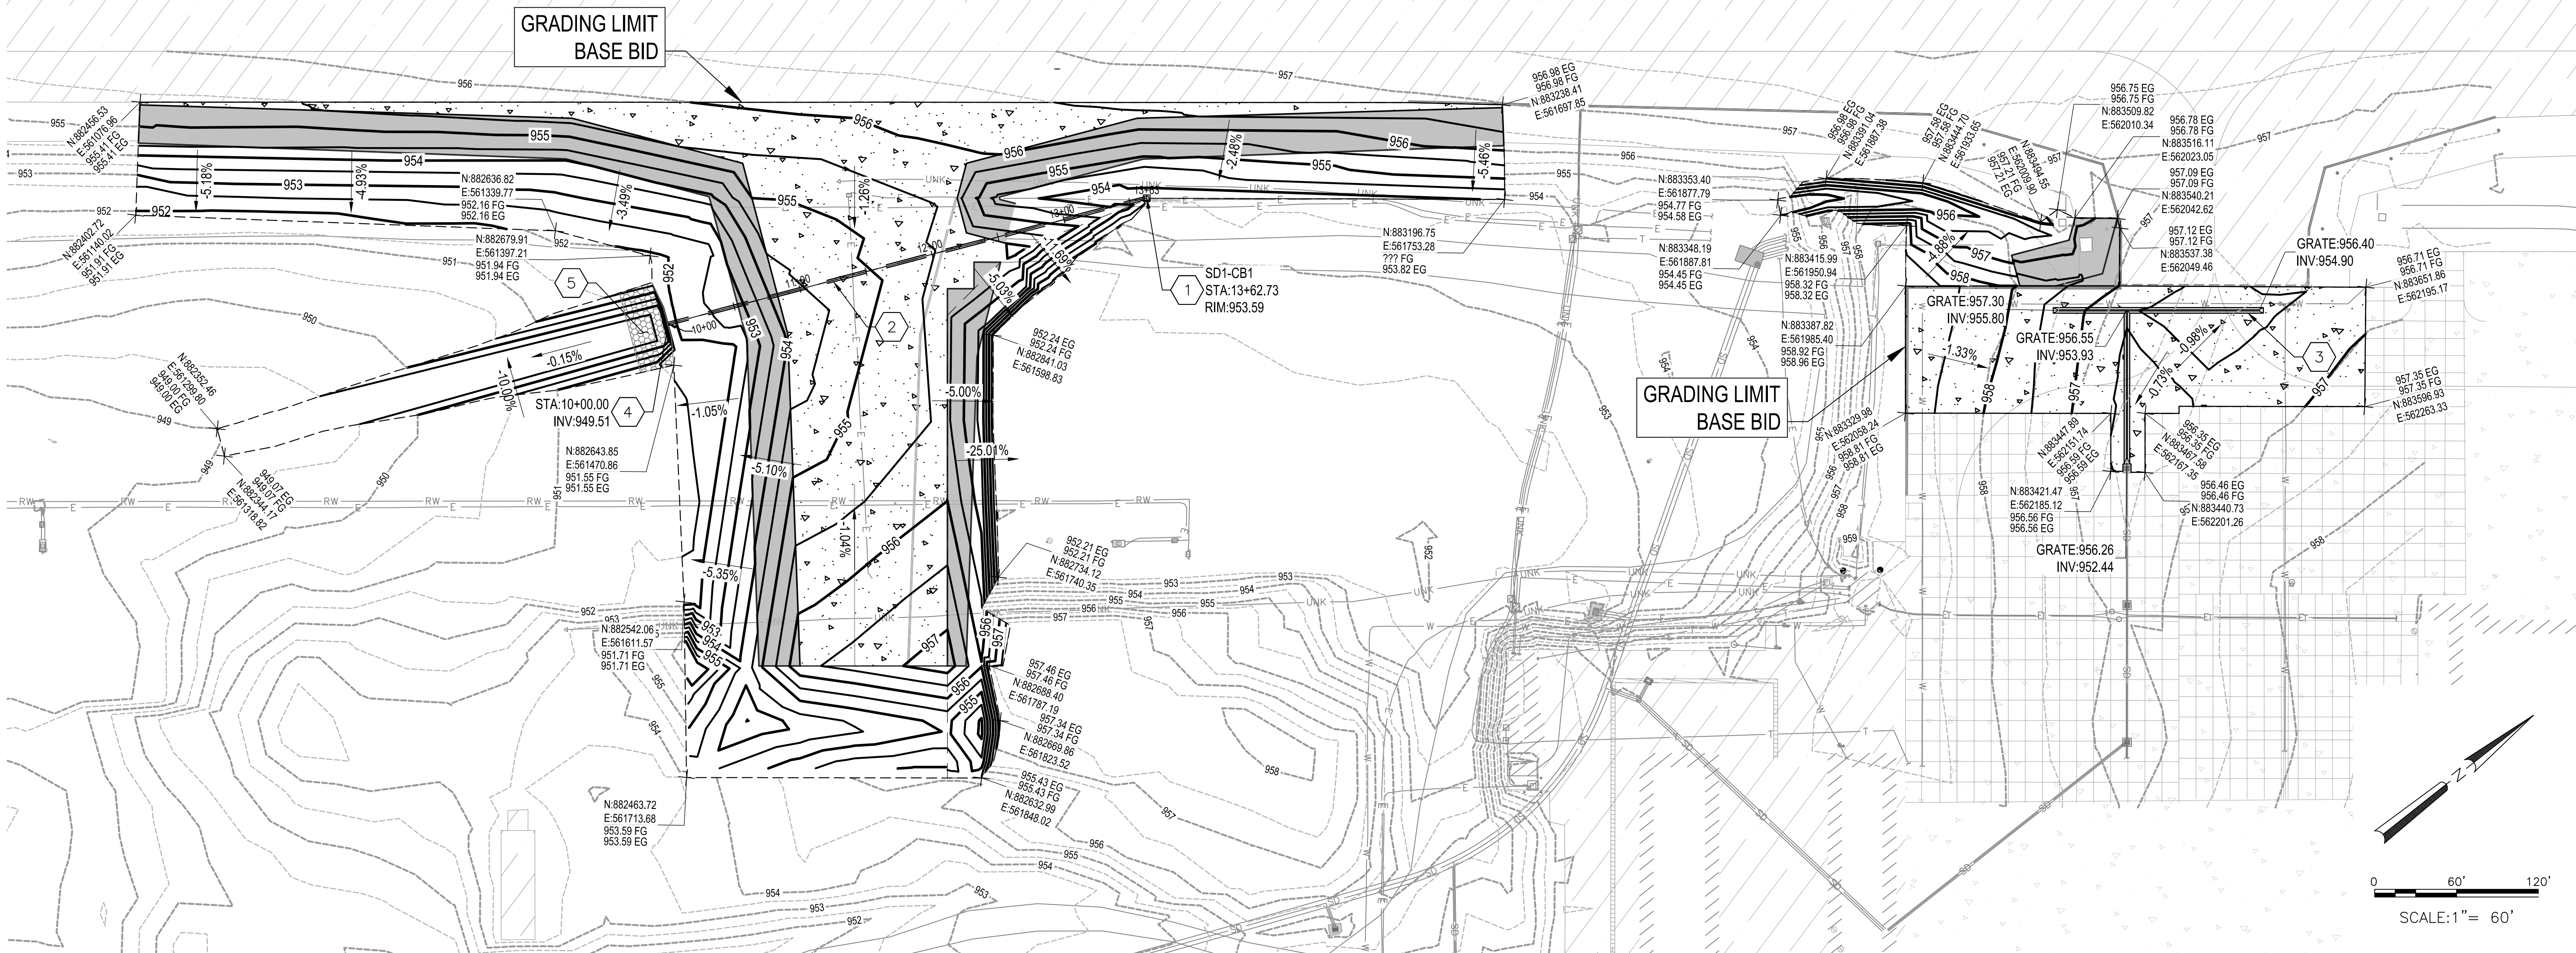

- PROPOSED GRADING LIMITS
- xxx---/--- PROPOSED MAJOR/MINOR CONTOUR
- xxx---/--- EXISTING MAJOR/MINOR CONTOUR
- == == == PROPOSED STORM DRAIN PIPE
- ===== PROPOSED AIRCRAFT RATED TRENCH DRAIN
- ▣ PROPOSED AIRCRAFT RATED CATCH BASIN
- ▷ PROPOSED FLARED END SECTION
- ▨ PROPOSED RIPRAP

- 1 AIRCRAFT RATED CATCH BASIN PER DETAIL A1, SHEET CU502. (BASE BID). ITEM D-751.
- 2 24" DIAMETER REINFORCED CONCRETE PIPE PER DETAIL B2, SHEET CU502. (BASE BID). ITEM D-701.
- 3 12" AIRCRAFT RATED TRENCH DRAIN PER DETAILS A3, A4, B3, C3, AND D3 ON SHEET CU501. (BASE BID). ITEM D-750.
- 4 END SECTION - REINFORCED CONCRETE PIPE PER MAG STD. DETAIL 545. (BASE BID). INCIDENTAL TO ITEM D-701.
- 5 INSTALL RIPRAP (D60=6", DEPTH=24"). (BASE BID). ITEM TSP-4.

D2 GENERAL NOTES
NOT TO SCALE

D3 LEGEND
NOT TO SCALE

D4 CONSTRUCTION NOTES
NOT TO SCALE

A1 GRADING AND DRAINAGE PLAN

SCALE: 1"=60'

PER CITY OF PHOENIX CODE CHAPTER 2, SECTION 2-28, THESE PLANS ARE FOR OFFICIAL USE ONLY AND MAY NOT BE SHARED WITH OTHERS EXCEPT AS REQUIRED TO FULFILL THE OBLIGATIONS OF CONTRACTOR'S CONTRACT WITH THE CITY OF PHOENIX.

C&S
COMPANIES



PER CITY OF PHOENIX CITY CODE CHAPTER 2, SECTION 2-28, THESE PLANS ARE FOR OFFICIAL USE ONLY AND MAY NOT BE SHARED WITH OTHERS EXCEPT AS REQUIRED TO FULFILL THE OBLIGATIONS OF YOUR CONTRACT WITH THE CITY OF PHOENIX.

NO. REVISIONS / SUBMISSIONS DATE

PHX DVT CYR
CITY OF PHOENIX AVIATION DEPARTMENT

PHOENIX GOODYEAR AIRPORT
NEW APRON AND TAXIWAY CONNECTOR

AV41000077 FAA/ADOT


Designed by: RB
Drawn by: RB
Checked by: LM
Date: February 2023
Dwg. scale: ---

GRADING AND DRAINAGE PLAN
BASE BID

Sheet
Reference
Number:


CU101

Sheet 32 of 61

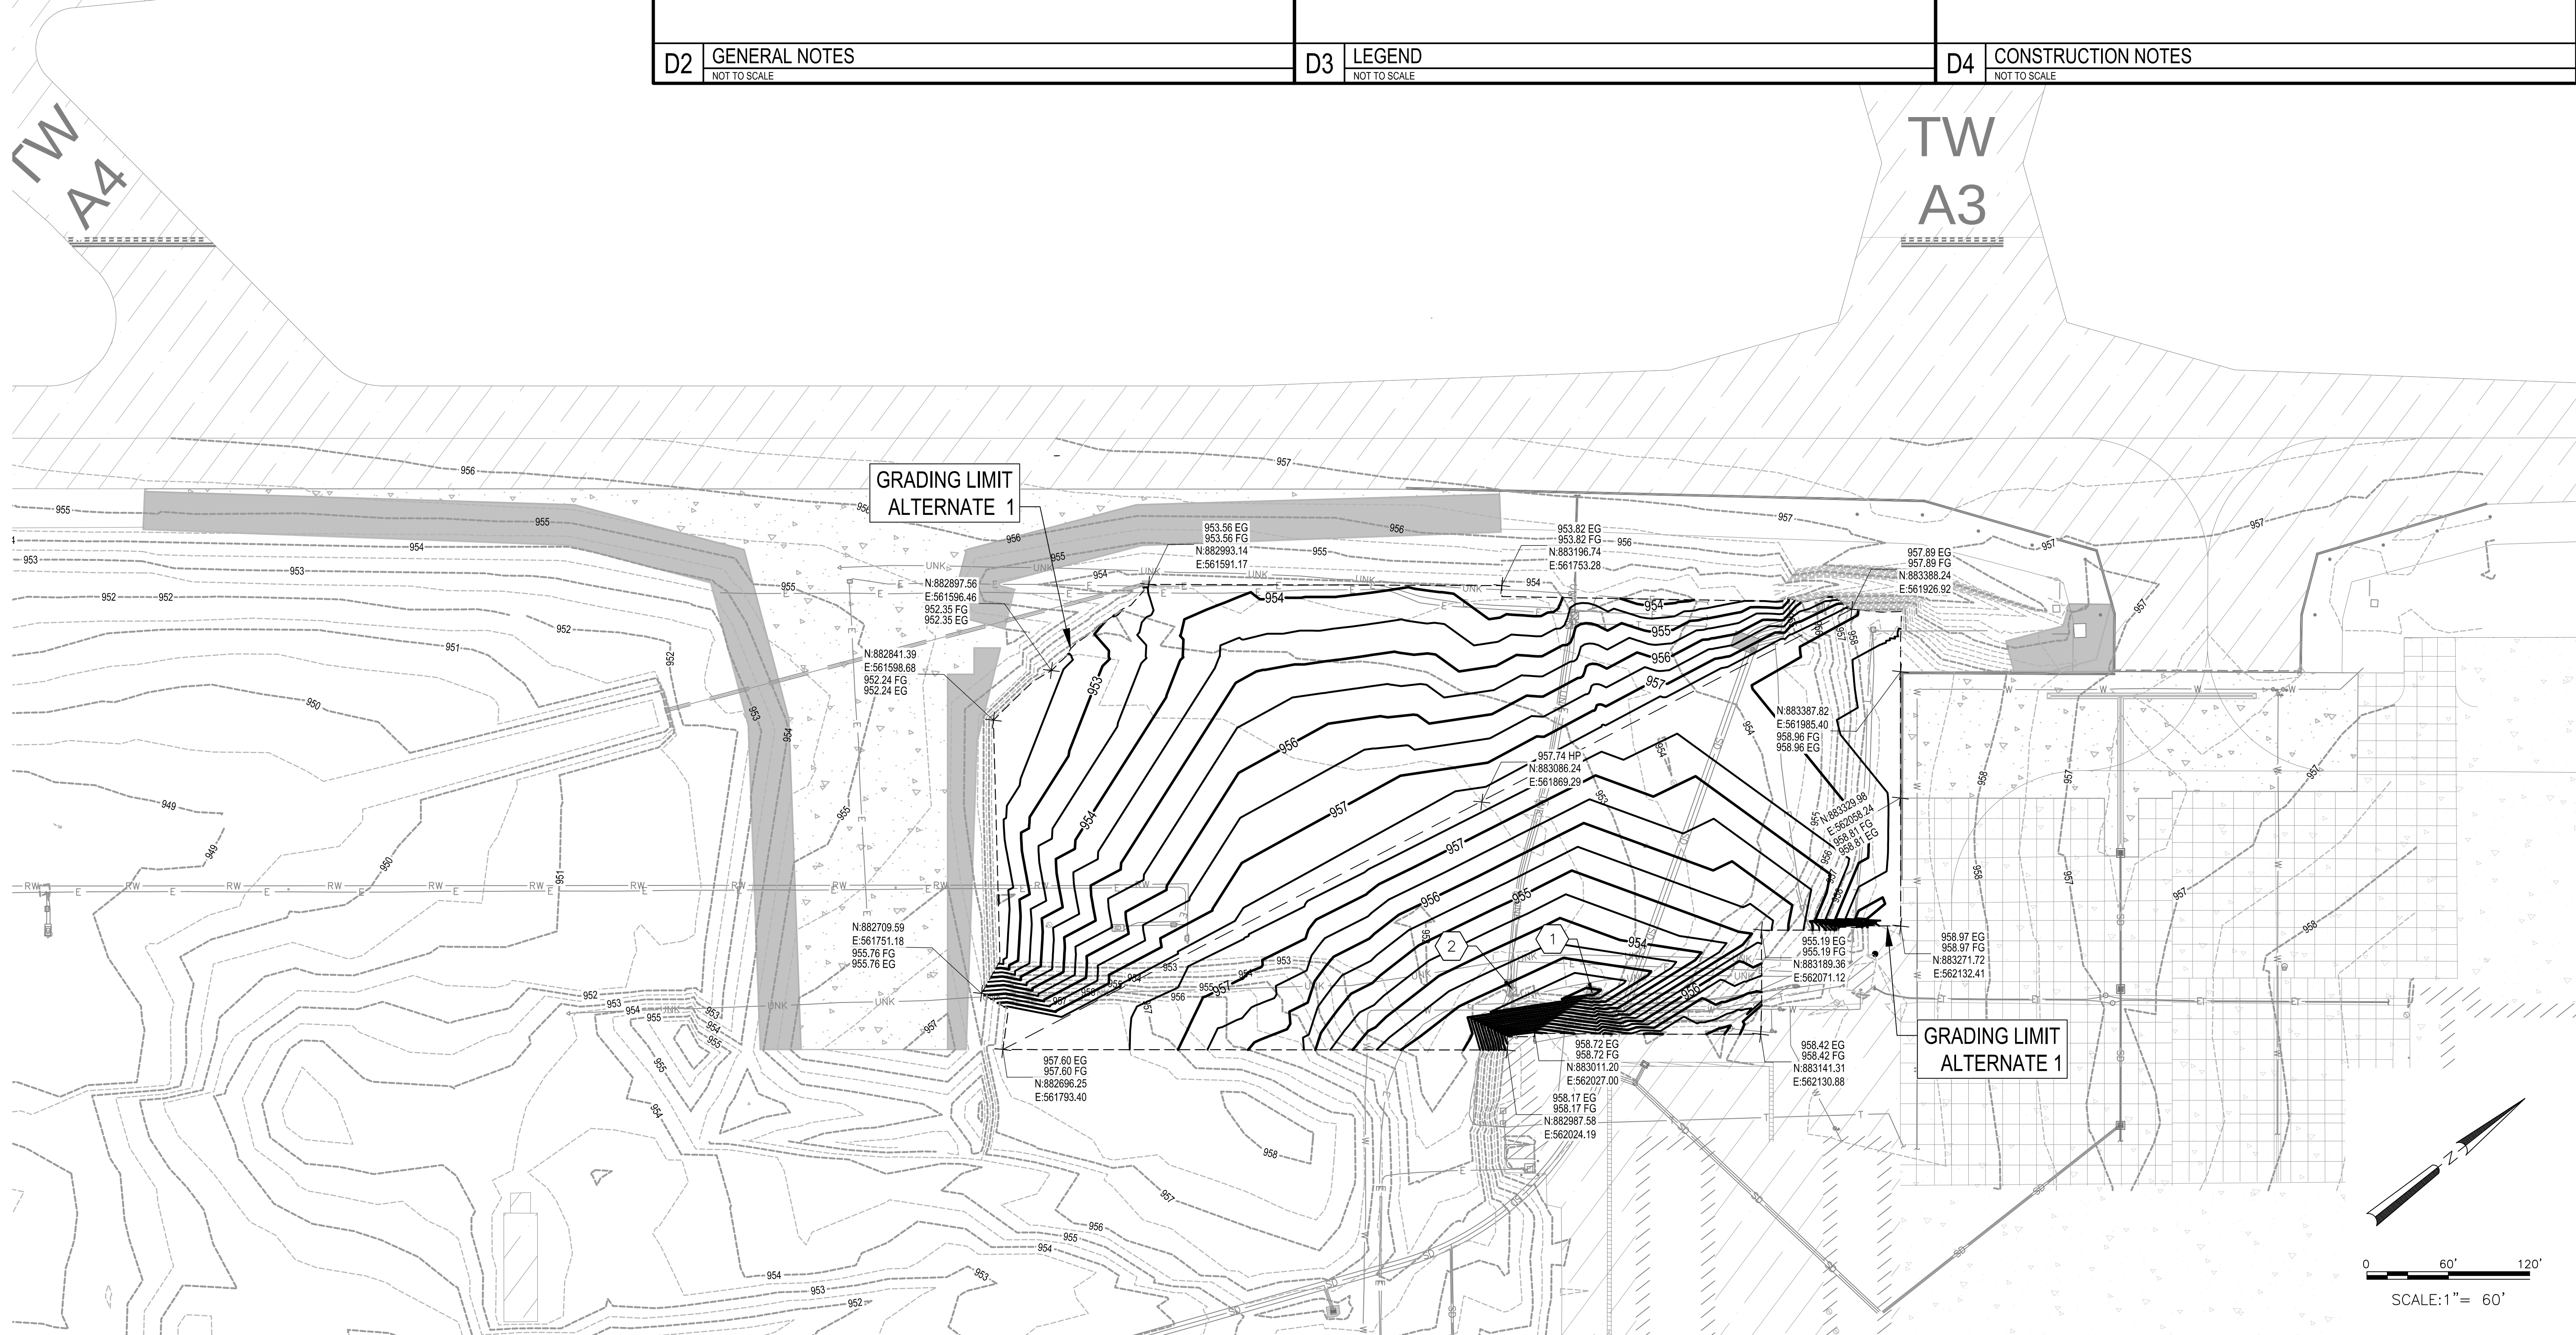

		----- PROPOSED GRADING LIMITS ---xxx/ PROPOSED MAJOR/MINOR CONTOUR ---xxx/ EXISTING MAJOR/MINOR CONTOUR > <		1 PROTECT EXISTING CATCH BASIN IN PLACE 2 PROTECT EXISTING STRUCTURE IN PLACE	
D2	GENERAL NOTES NOT TO SCALE	D3	LEGEND NOT TO SCALE	D4	CONSTRUCTION NOTES NOT TO SCALE

PER CITY OF PHOENIX CODE CHAPTER 2, SECTION 2-28. THESE PLANS ARE FOR OFFICIAL USE ONLY AND MAY NOT BE SHARED WITH OTHERS EXCEPT AS REQUIRED TO FULFILL THE OBLIGATIONS OF CONTRACTOR'S CONTRACT WITH THE CITY OF PHOENIX.

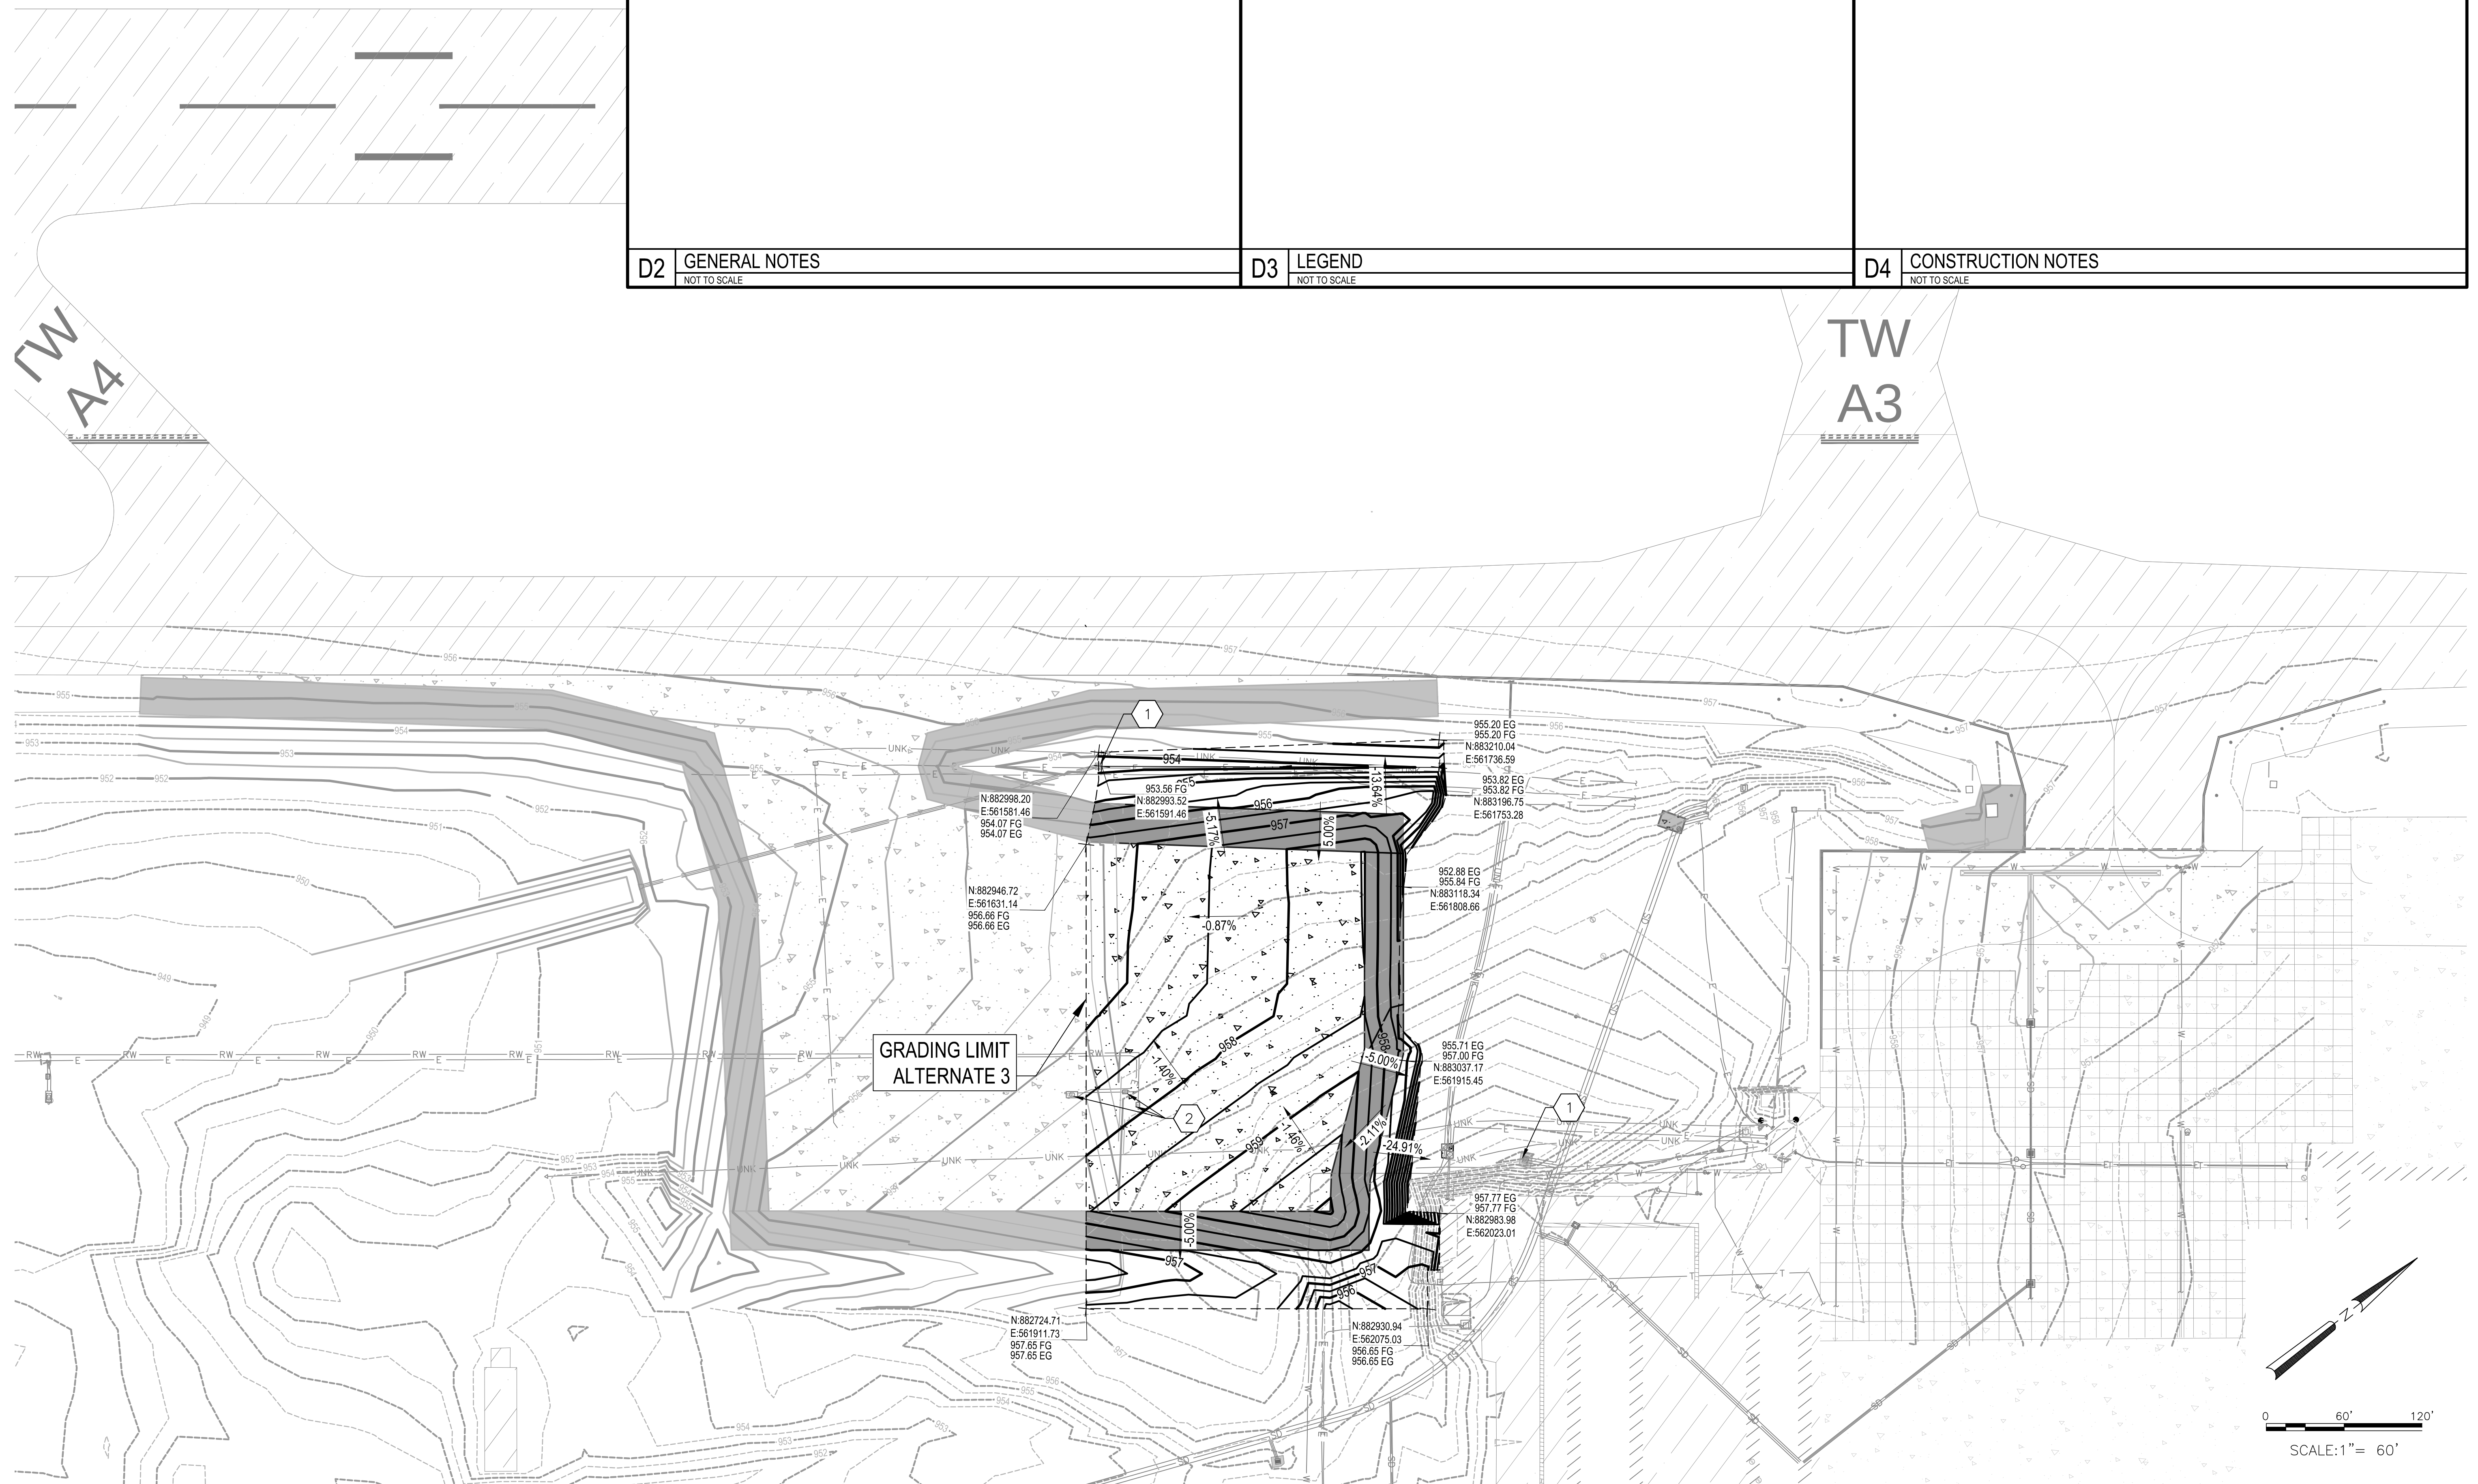[illegible]

PER CITY OF PHOENIX CODE CHAPTER 2, SECTION 2-28. THESE PLANS ARE FOR OFFICIAL USE ONLY AND MAY NOT BE SHARED WITH OTHERS EXCEPT AS REQUIRED TO FULFILL THE OBLIGATIONS OF CONTRACTOR'S CONTRACT WITH THE CITY OF PHOENIX.

Sheet Overview Title	GRADING AND DRAINAGE PLAN BID ALT 3			
Designed by: RB	Drawn by: RB	Checked by: LM	Date: February 2023	Dwg scale: —


CU104

Sheet Reference Number:

PHOENIX GOODYEAR AIRPORT
NEW APRON AND TAXIWAY CONNECTOR
AV41000077 FAA/ADOT

CIP NO. (S): AV41000077 FAA/ADOT

Sheet 35 of 61

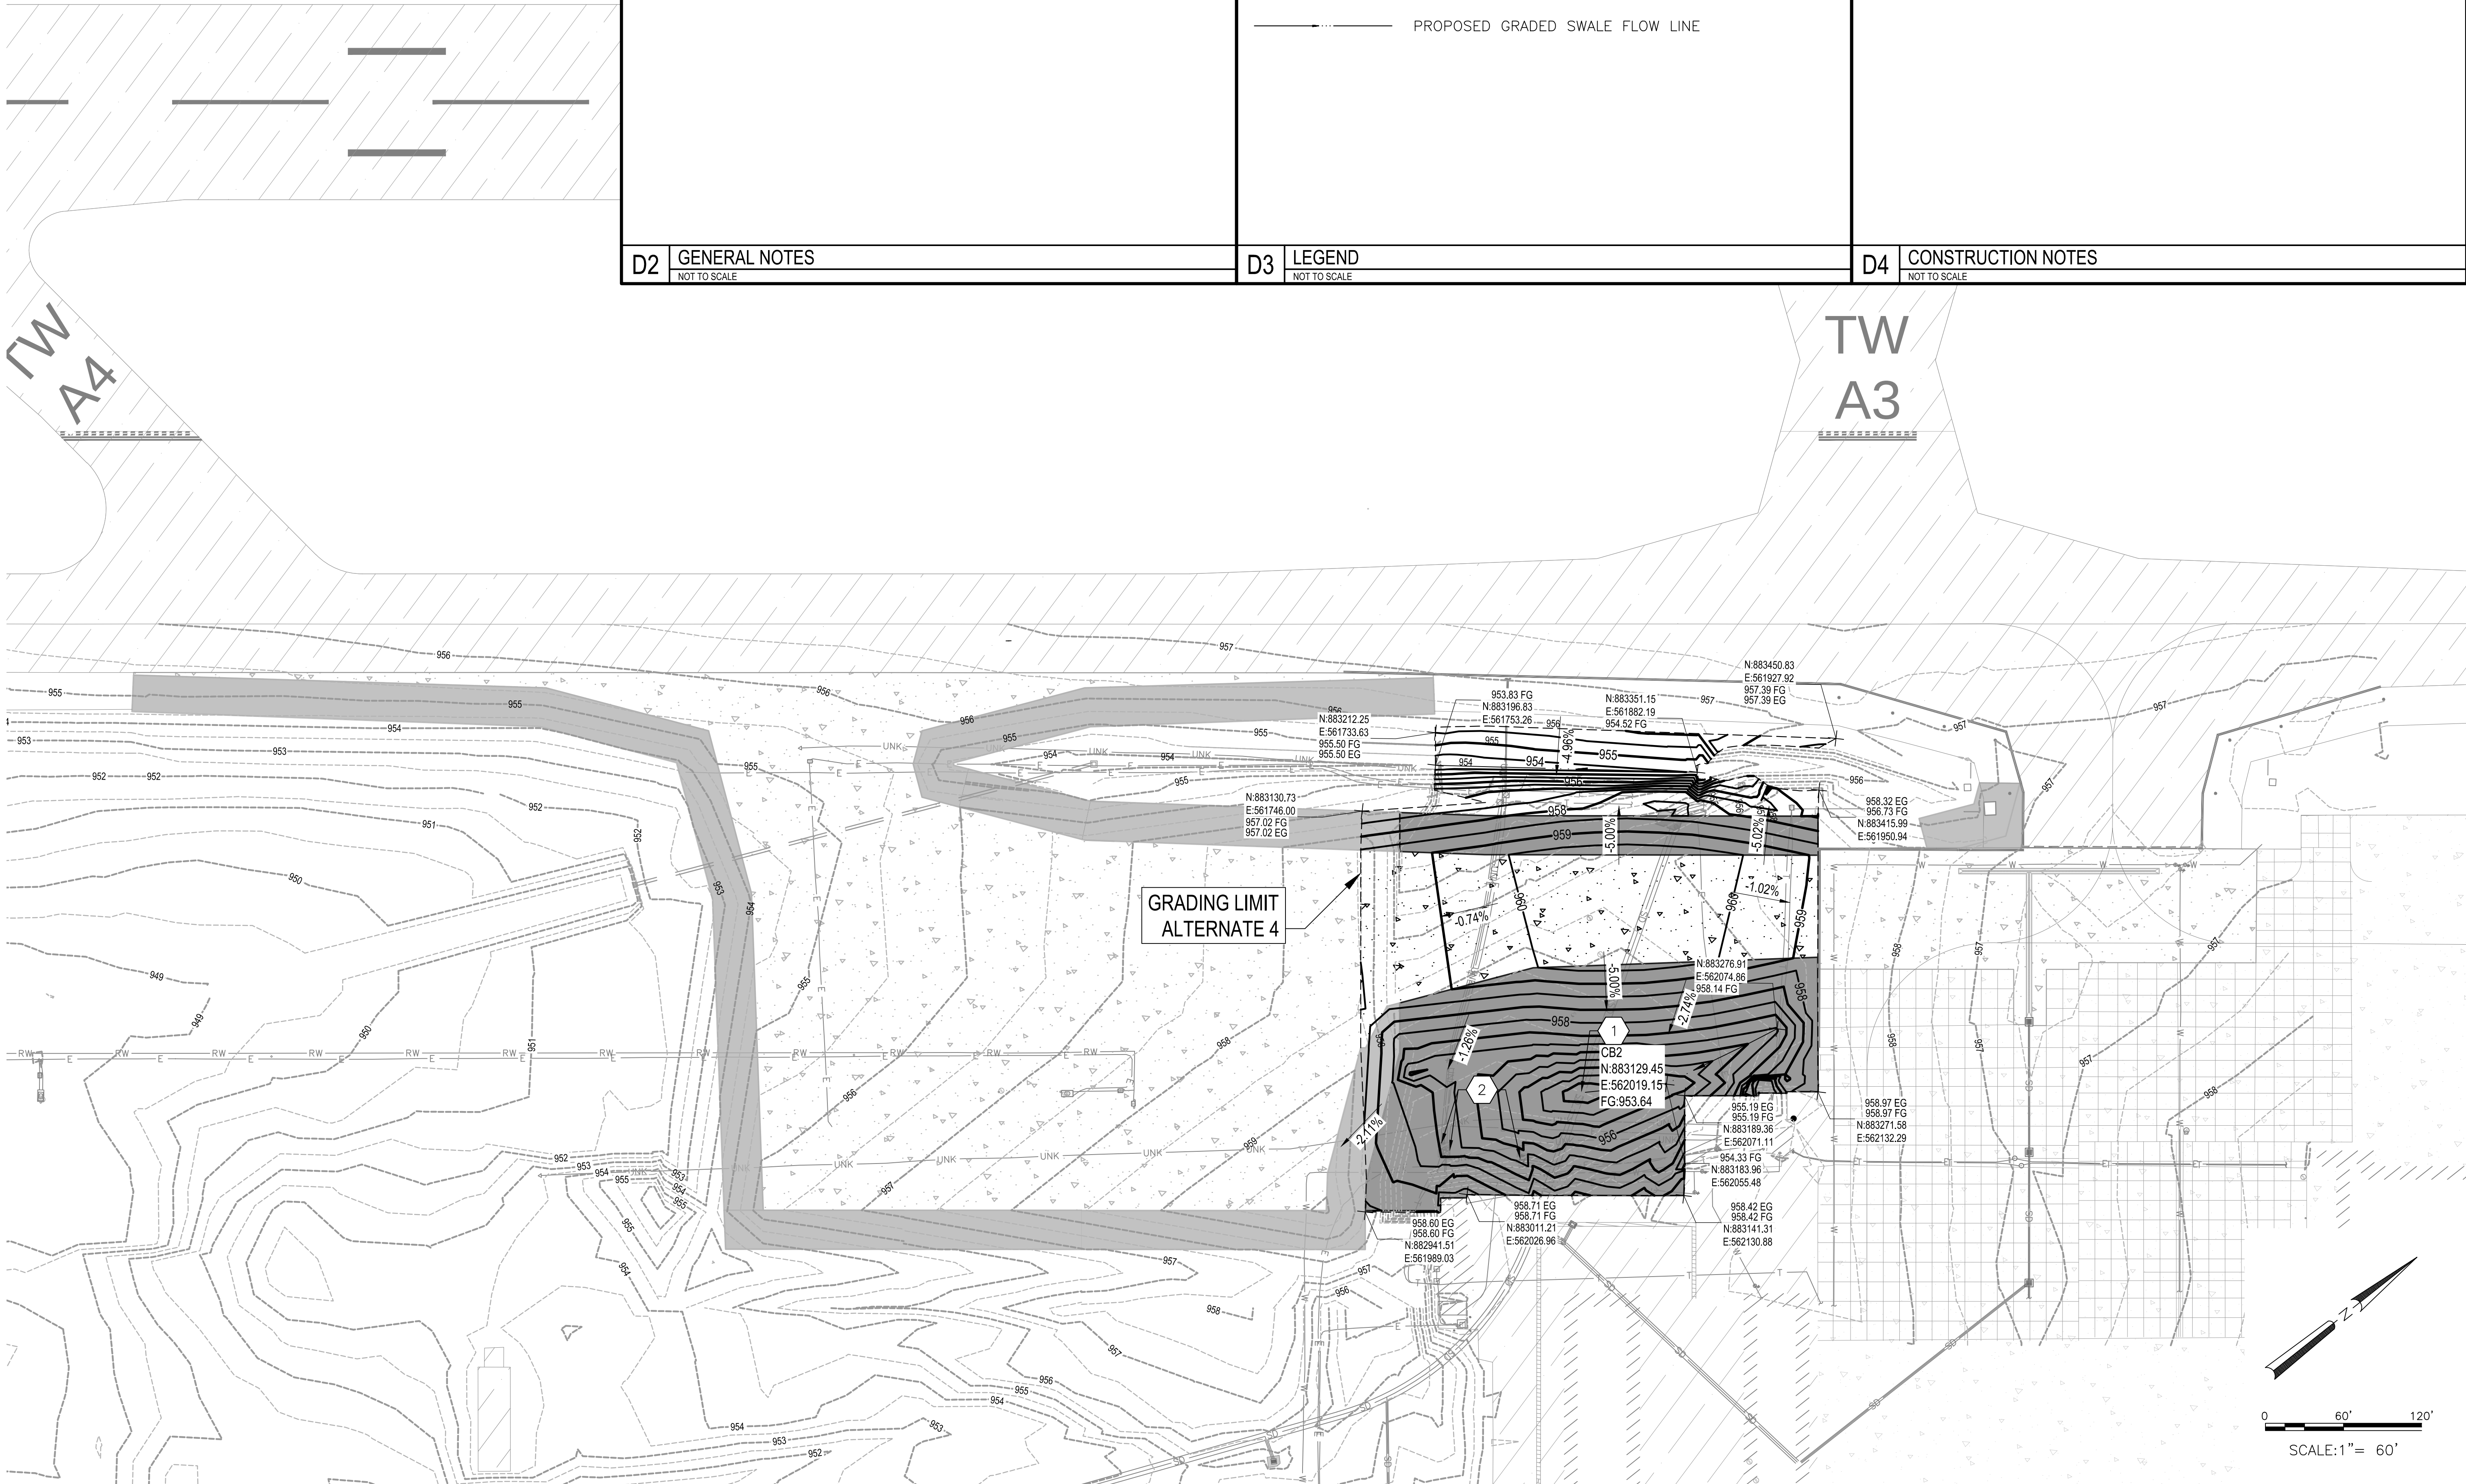

- PROPOSED GRADING LIMITS
- xxx---/--- PROPOSED MAJOR/MINOR CONTOUR
- xxx---/--- EXISTING MAJOR/MINOR CONTOUR
- ▣ PROPOSED AIRCRAFT RATED CATCH BASIN
- PROPOSED GRADED SWALE FLOW LINE

- 1 AIRCRAFT RATED CATCH BASIN PER DETAIL A1, SHEET CU502. (BASE BID). ITEM D-751.
- 2 EXISTING UTILITY STRUCTURE TO BE MODIFIED, ADJUST TO PROPOSED GRADE. SEE DETAIL A3/CU502

D2	GENERAL NOTES	D3	LEGEND	D4	CONSTRUCTION NOTES
	NOT TO SCALE		NOT TO SCALE		NOT TO SCALE

PER CITY OF PHOENIX CODE CHAPTER 2, SECTION 2-28, THESE PLANS ARE FOR OFFICIAL USE ONLY AND MAY NOT BE SHARED WITH OTHERS EXCEPT AS REQUIRED TO FULFILL THE OBLIGATIONS OF CONTRACTOR'S CONTRACT WITH THE CITY OF PHOENIX.

PER CITY OF PHOENIX CITY CODE CHAPTER 2, SECTION 2-28, THESE PLANS ARE FOR OFFICIAL USE ONLY AND MAY NOT BE SHARED WITH OTHERS EXCEPT AS REQUIRED TO FULFILL THE OBLIGATIONS OF YOUR CONTRACT WITH THE CITY OF PHOENIX.					
NO.	REVISIONS /	SUBMISSIONS	DATE		

PHX DVT CYR

CITY OF PHOENIX AVIATION DEPARTMENT

PHOENIX GOODYEAR AIRPORT

NEW APRON AND TAXIWAY CONNECTOR


AV41000077 FAA/ADOT







Designed by: RB	Drawn by: RB	Checked by: LM	Date: February 2023
Dwg scale:			

Sheet Overview Title

GRADING AND DRAINAGE PLAN

BID ALT 4

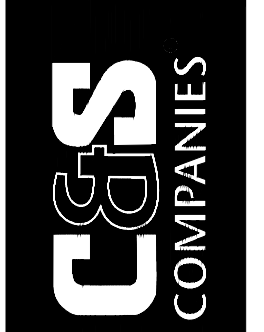

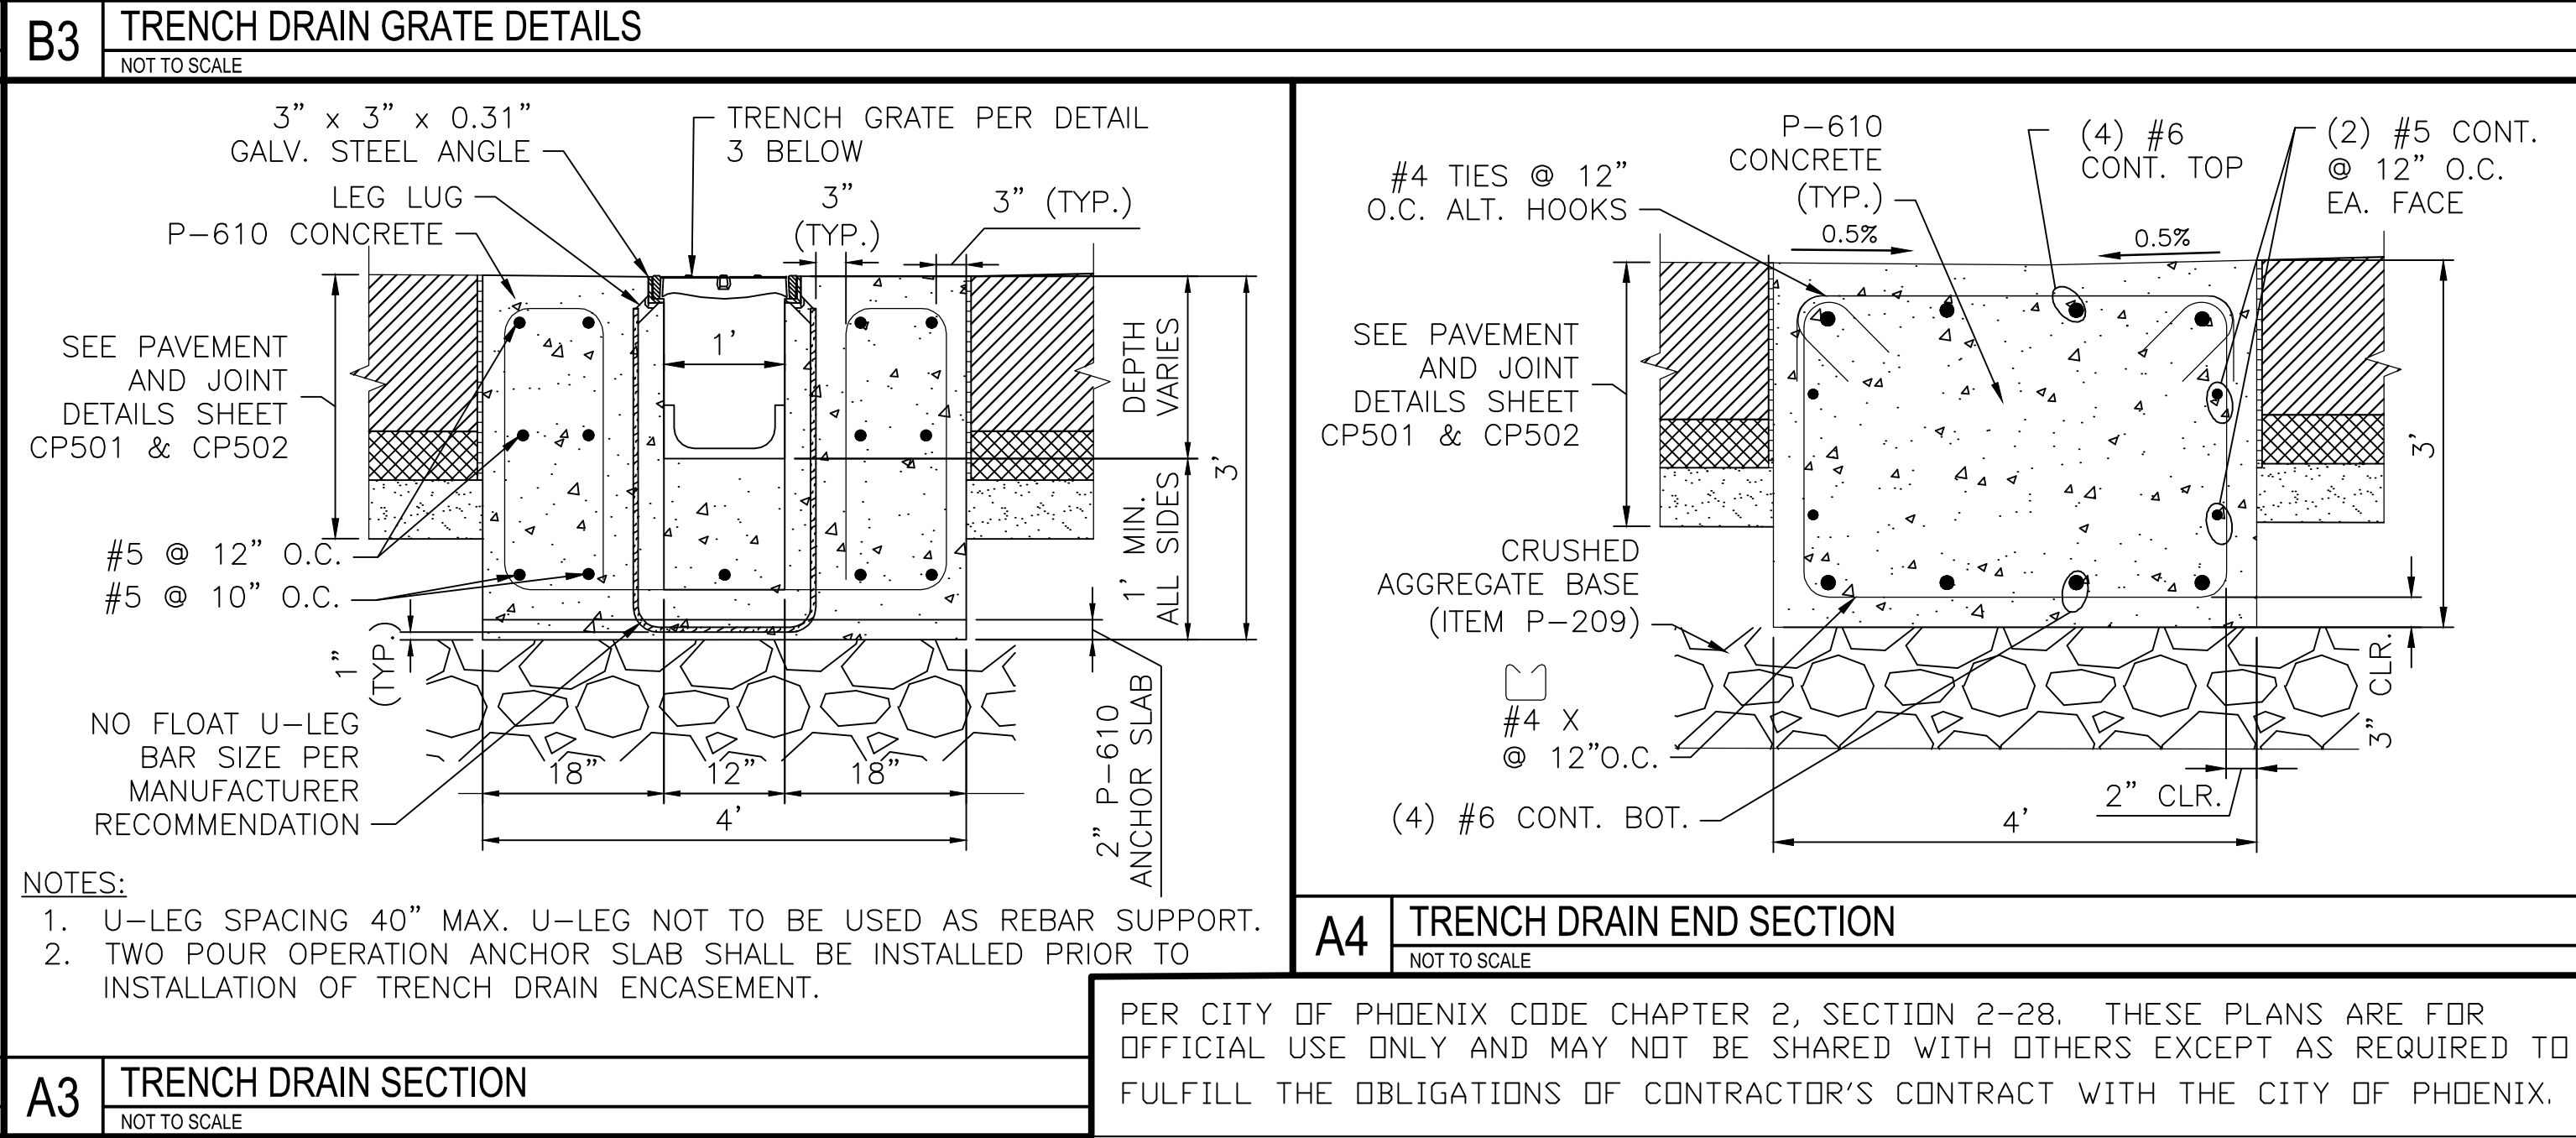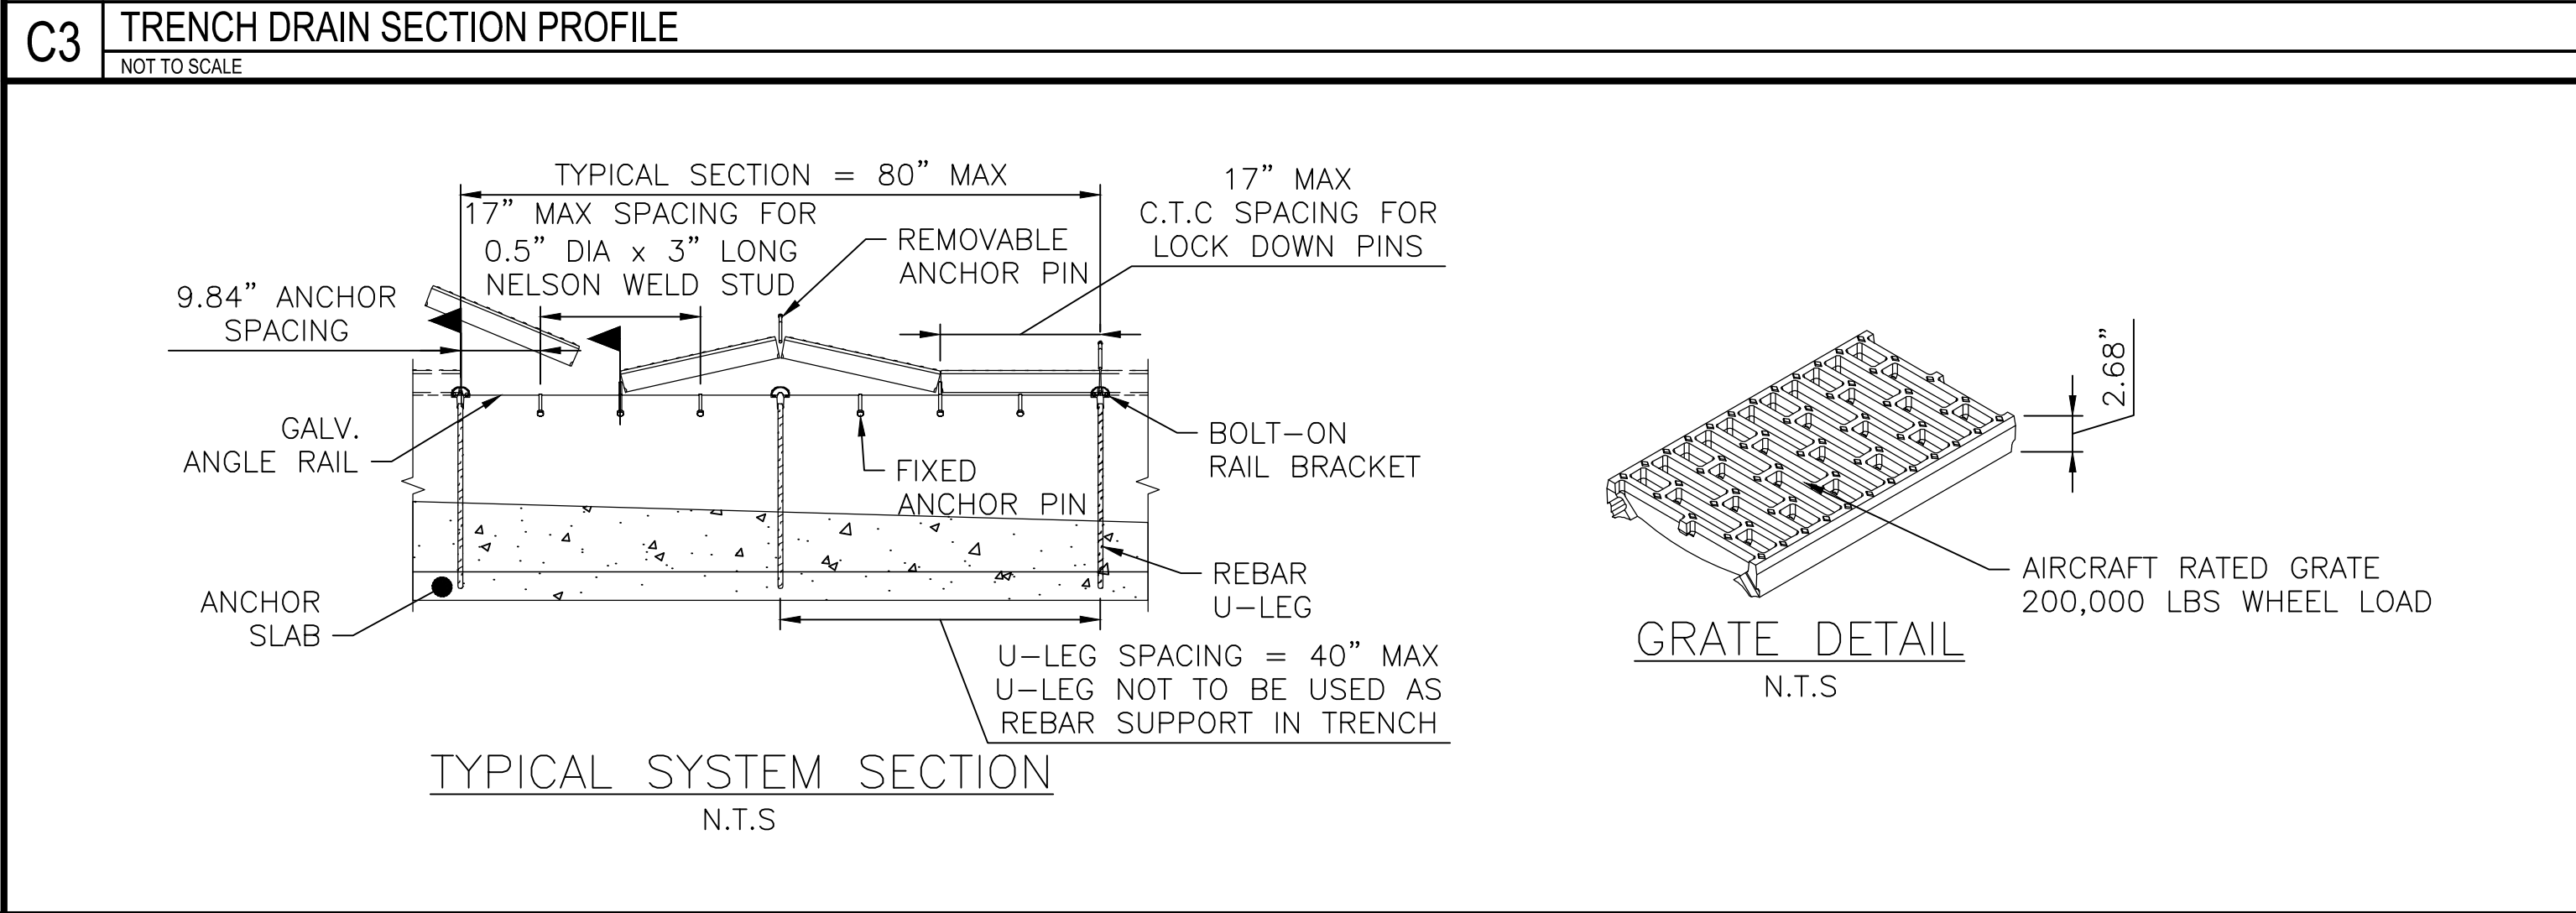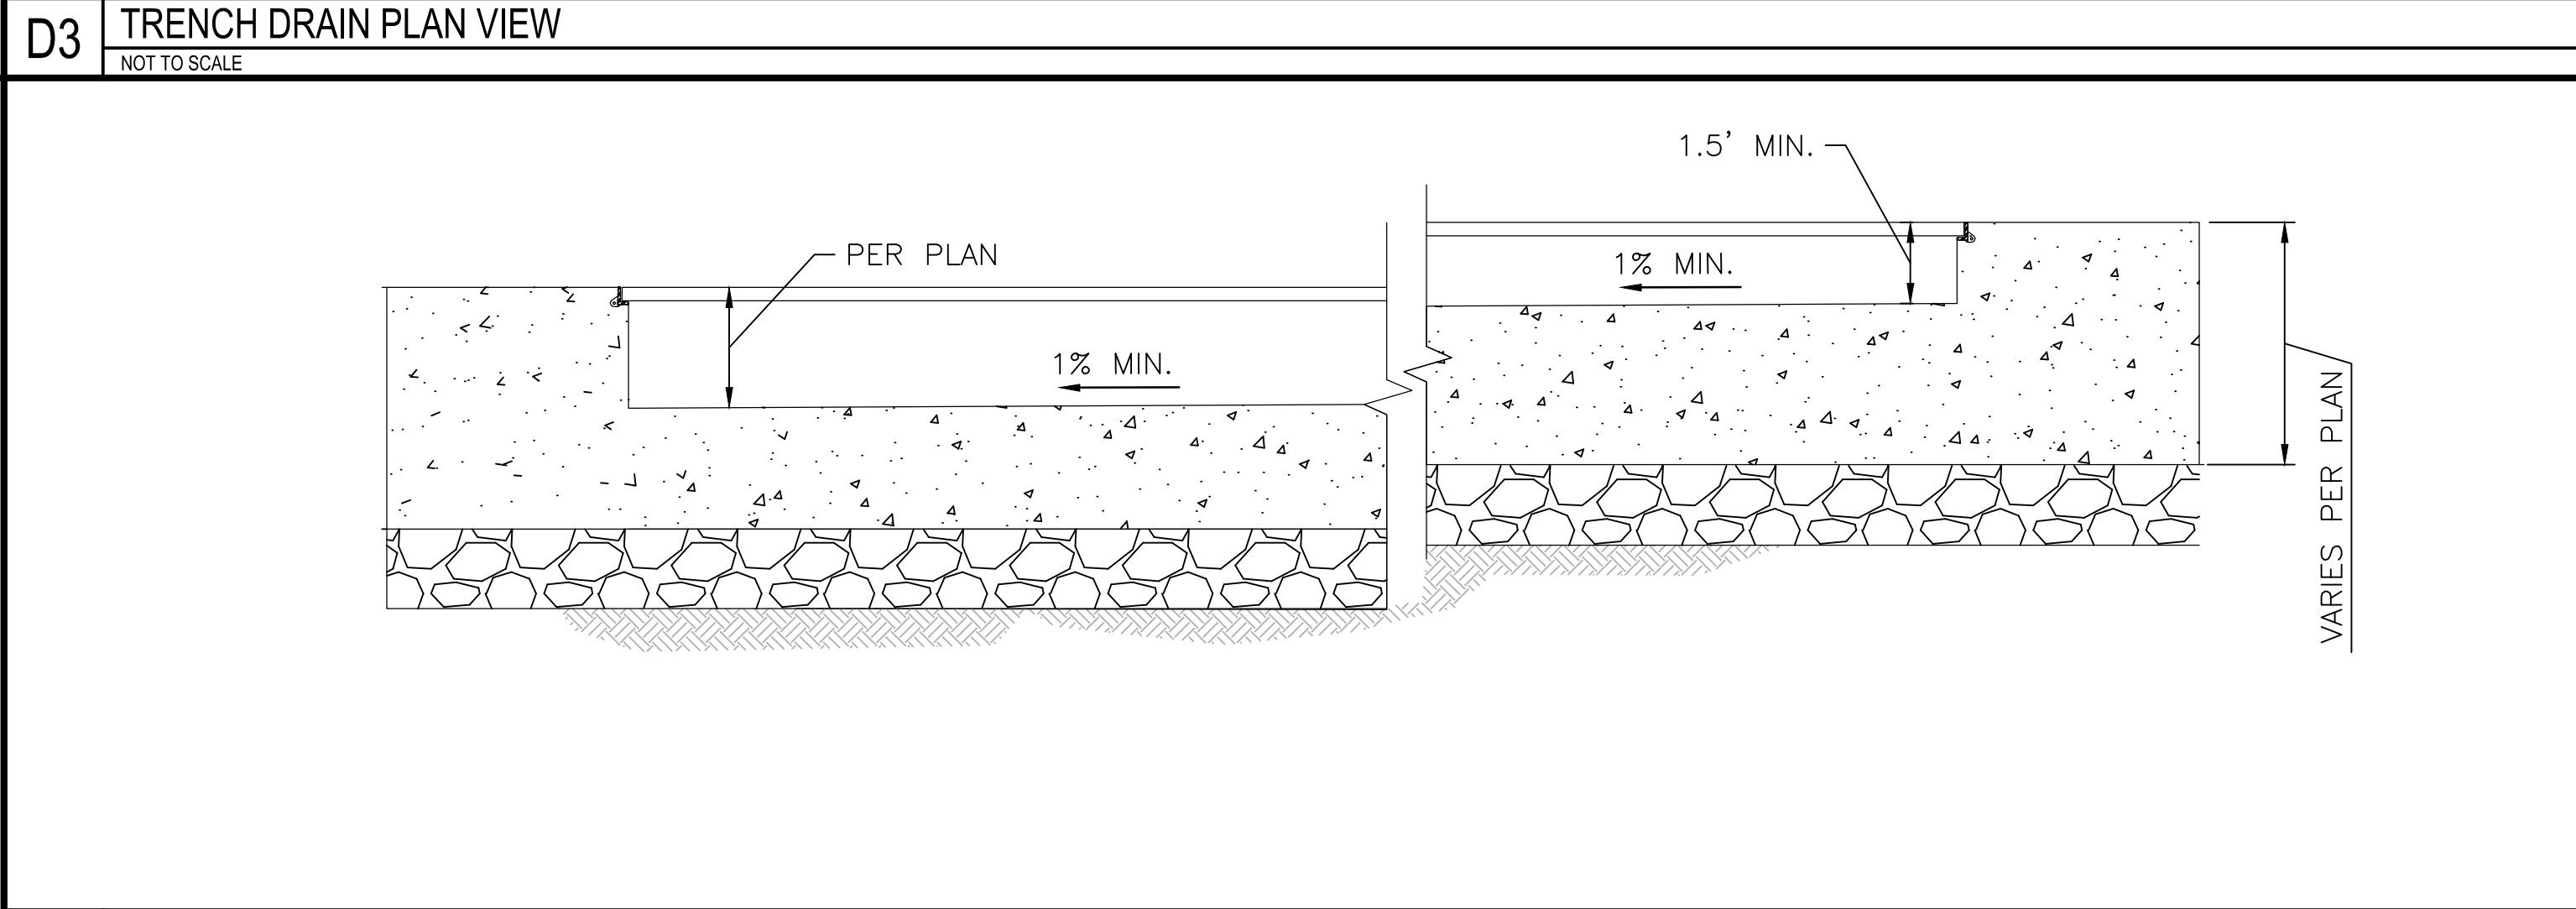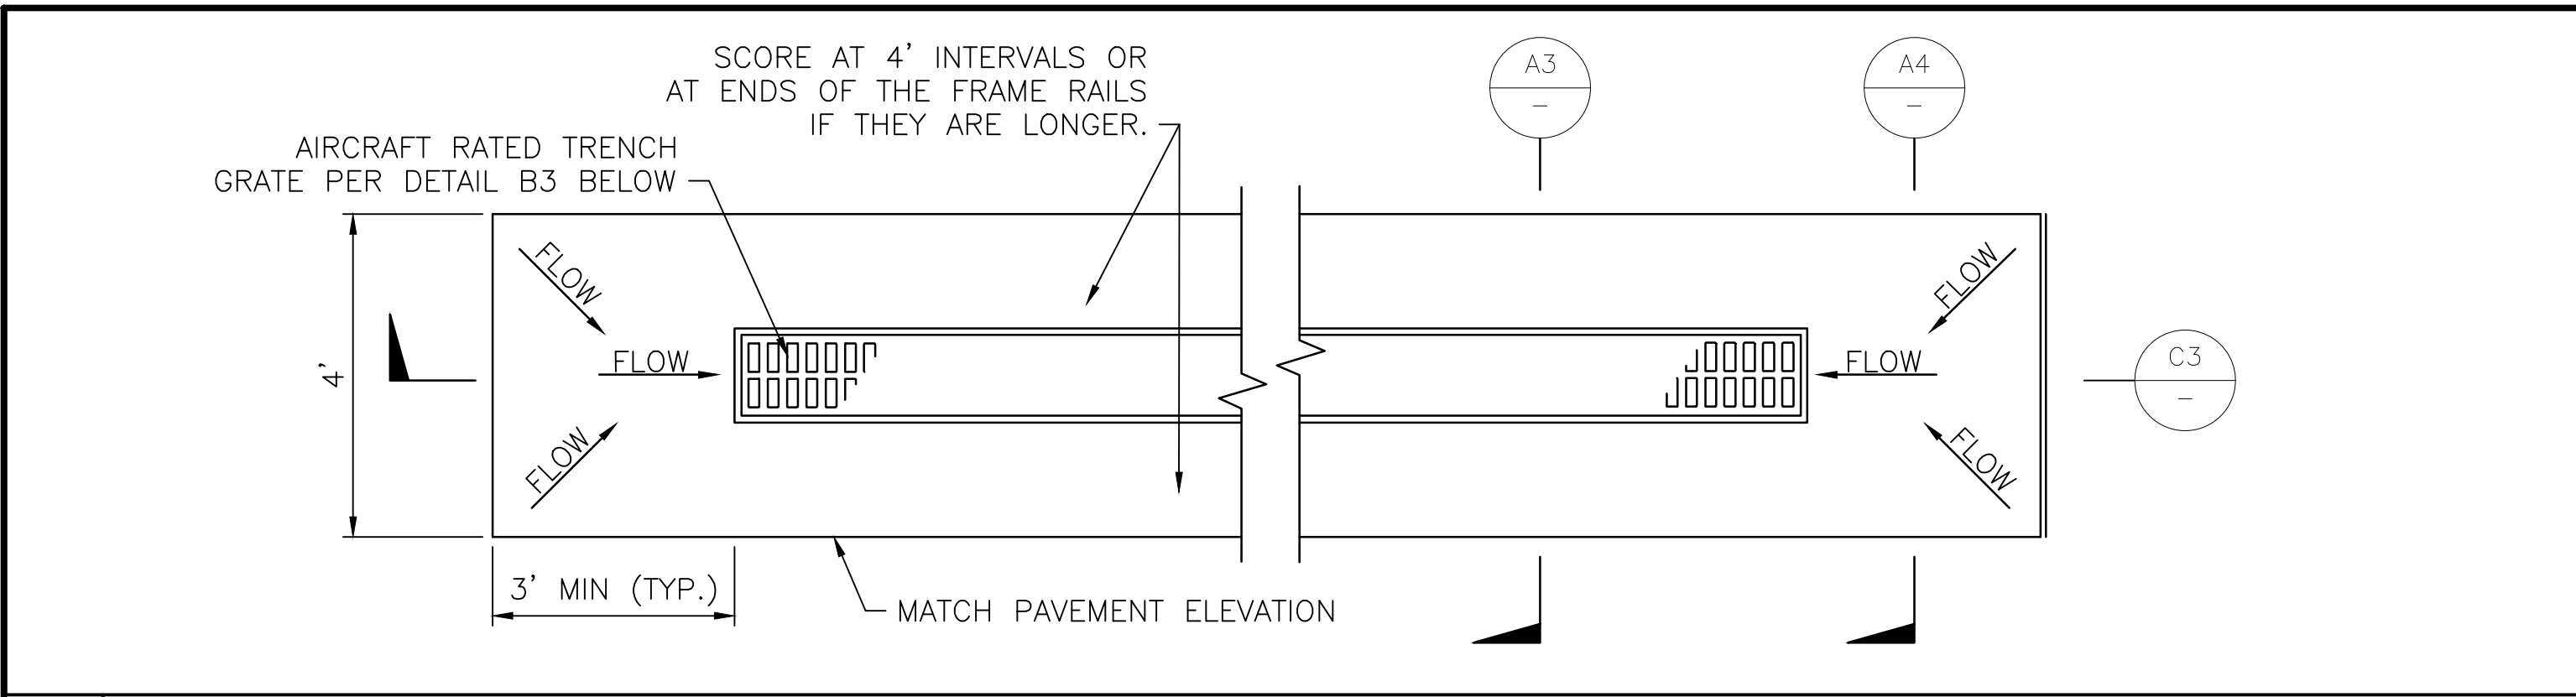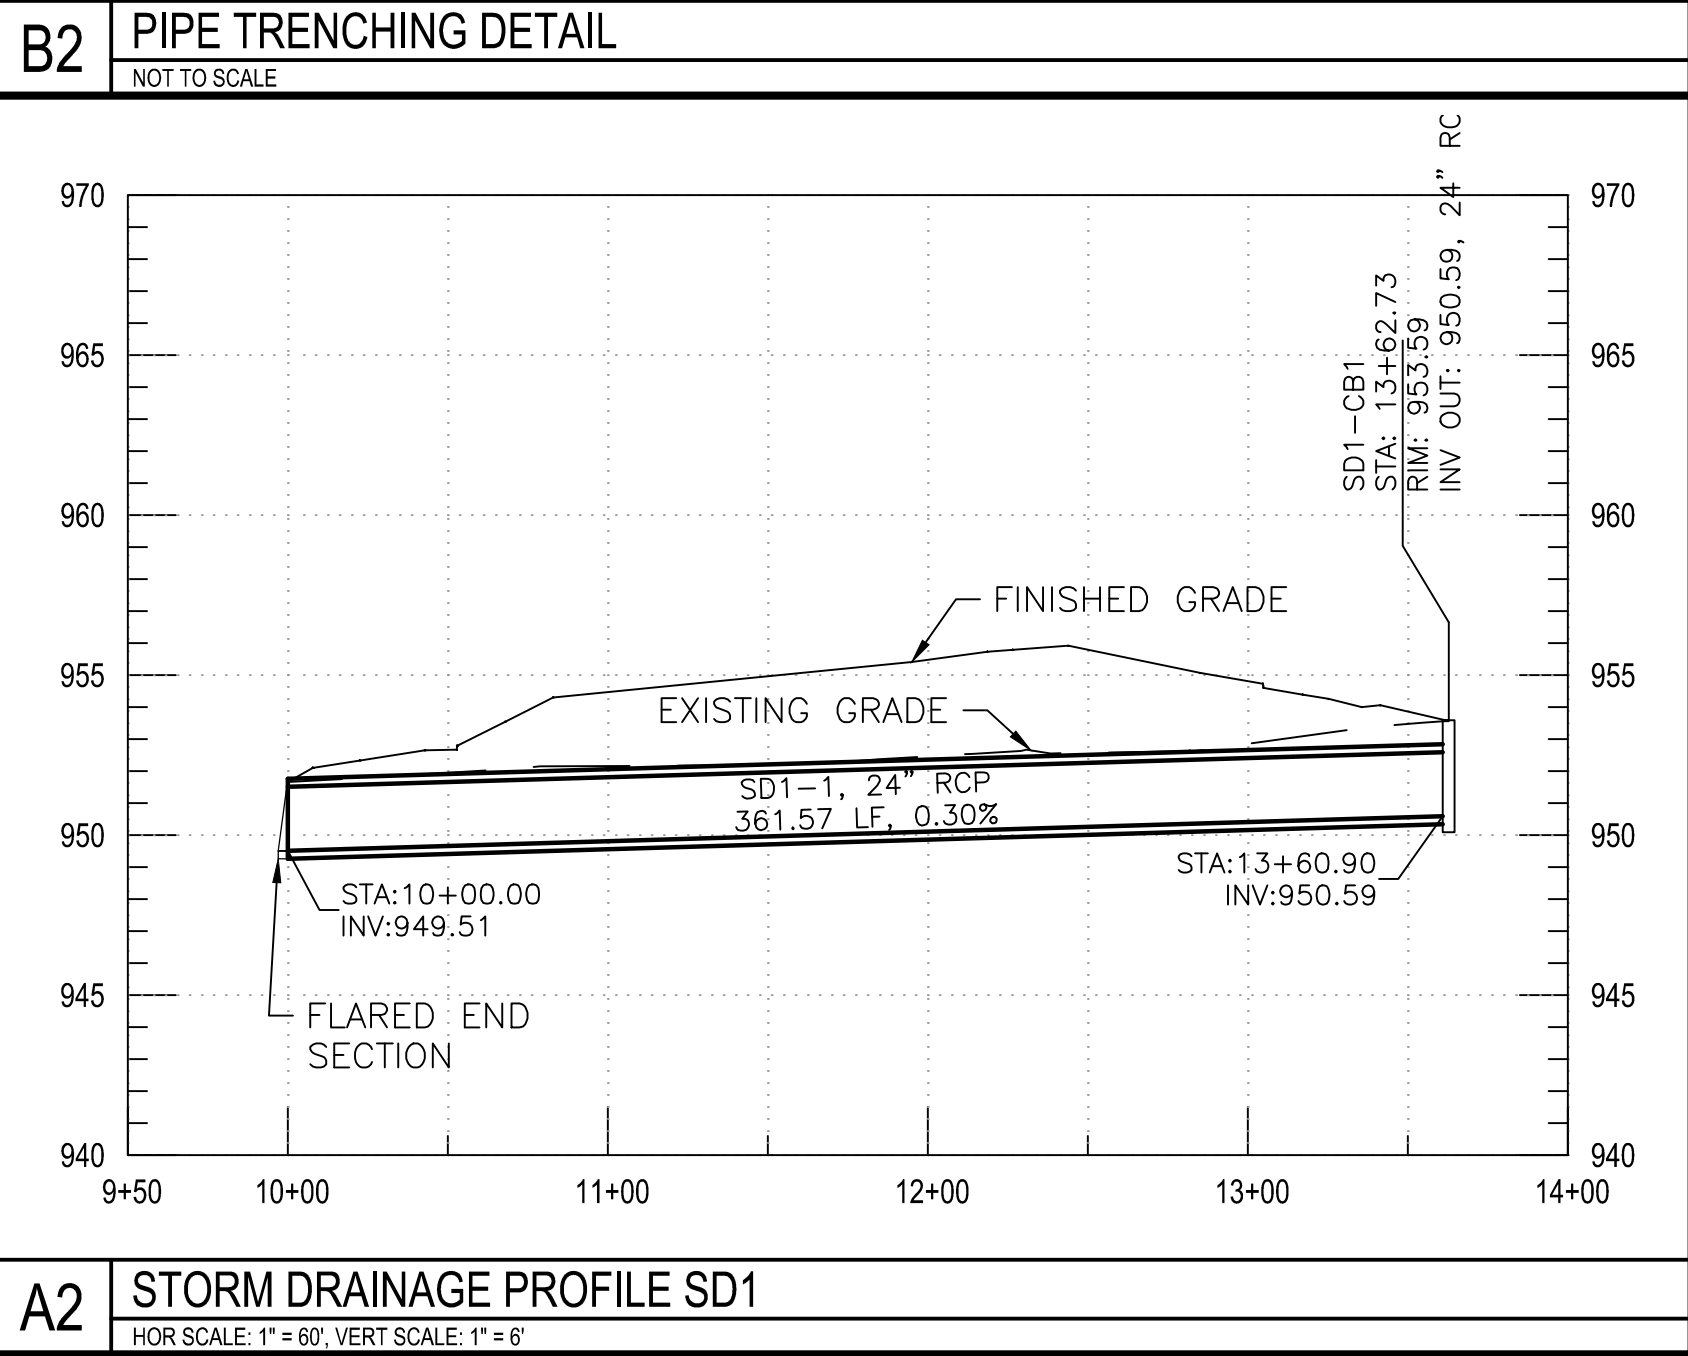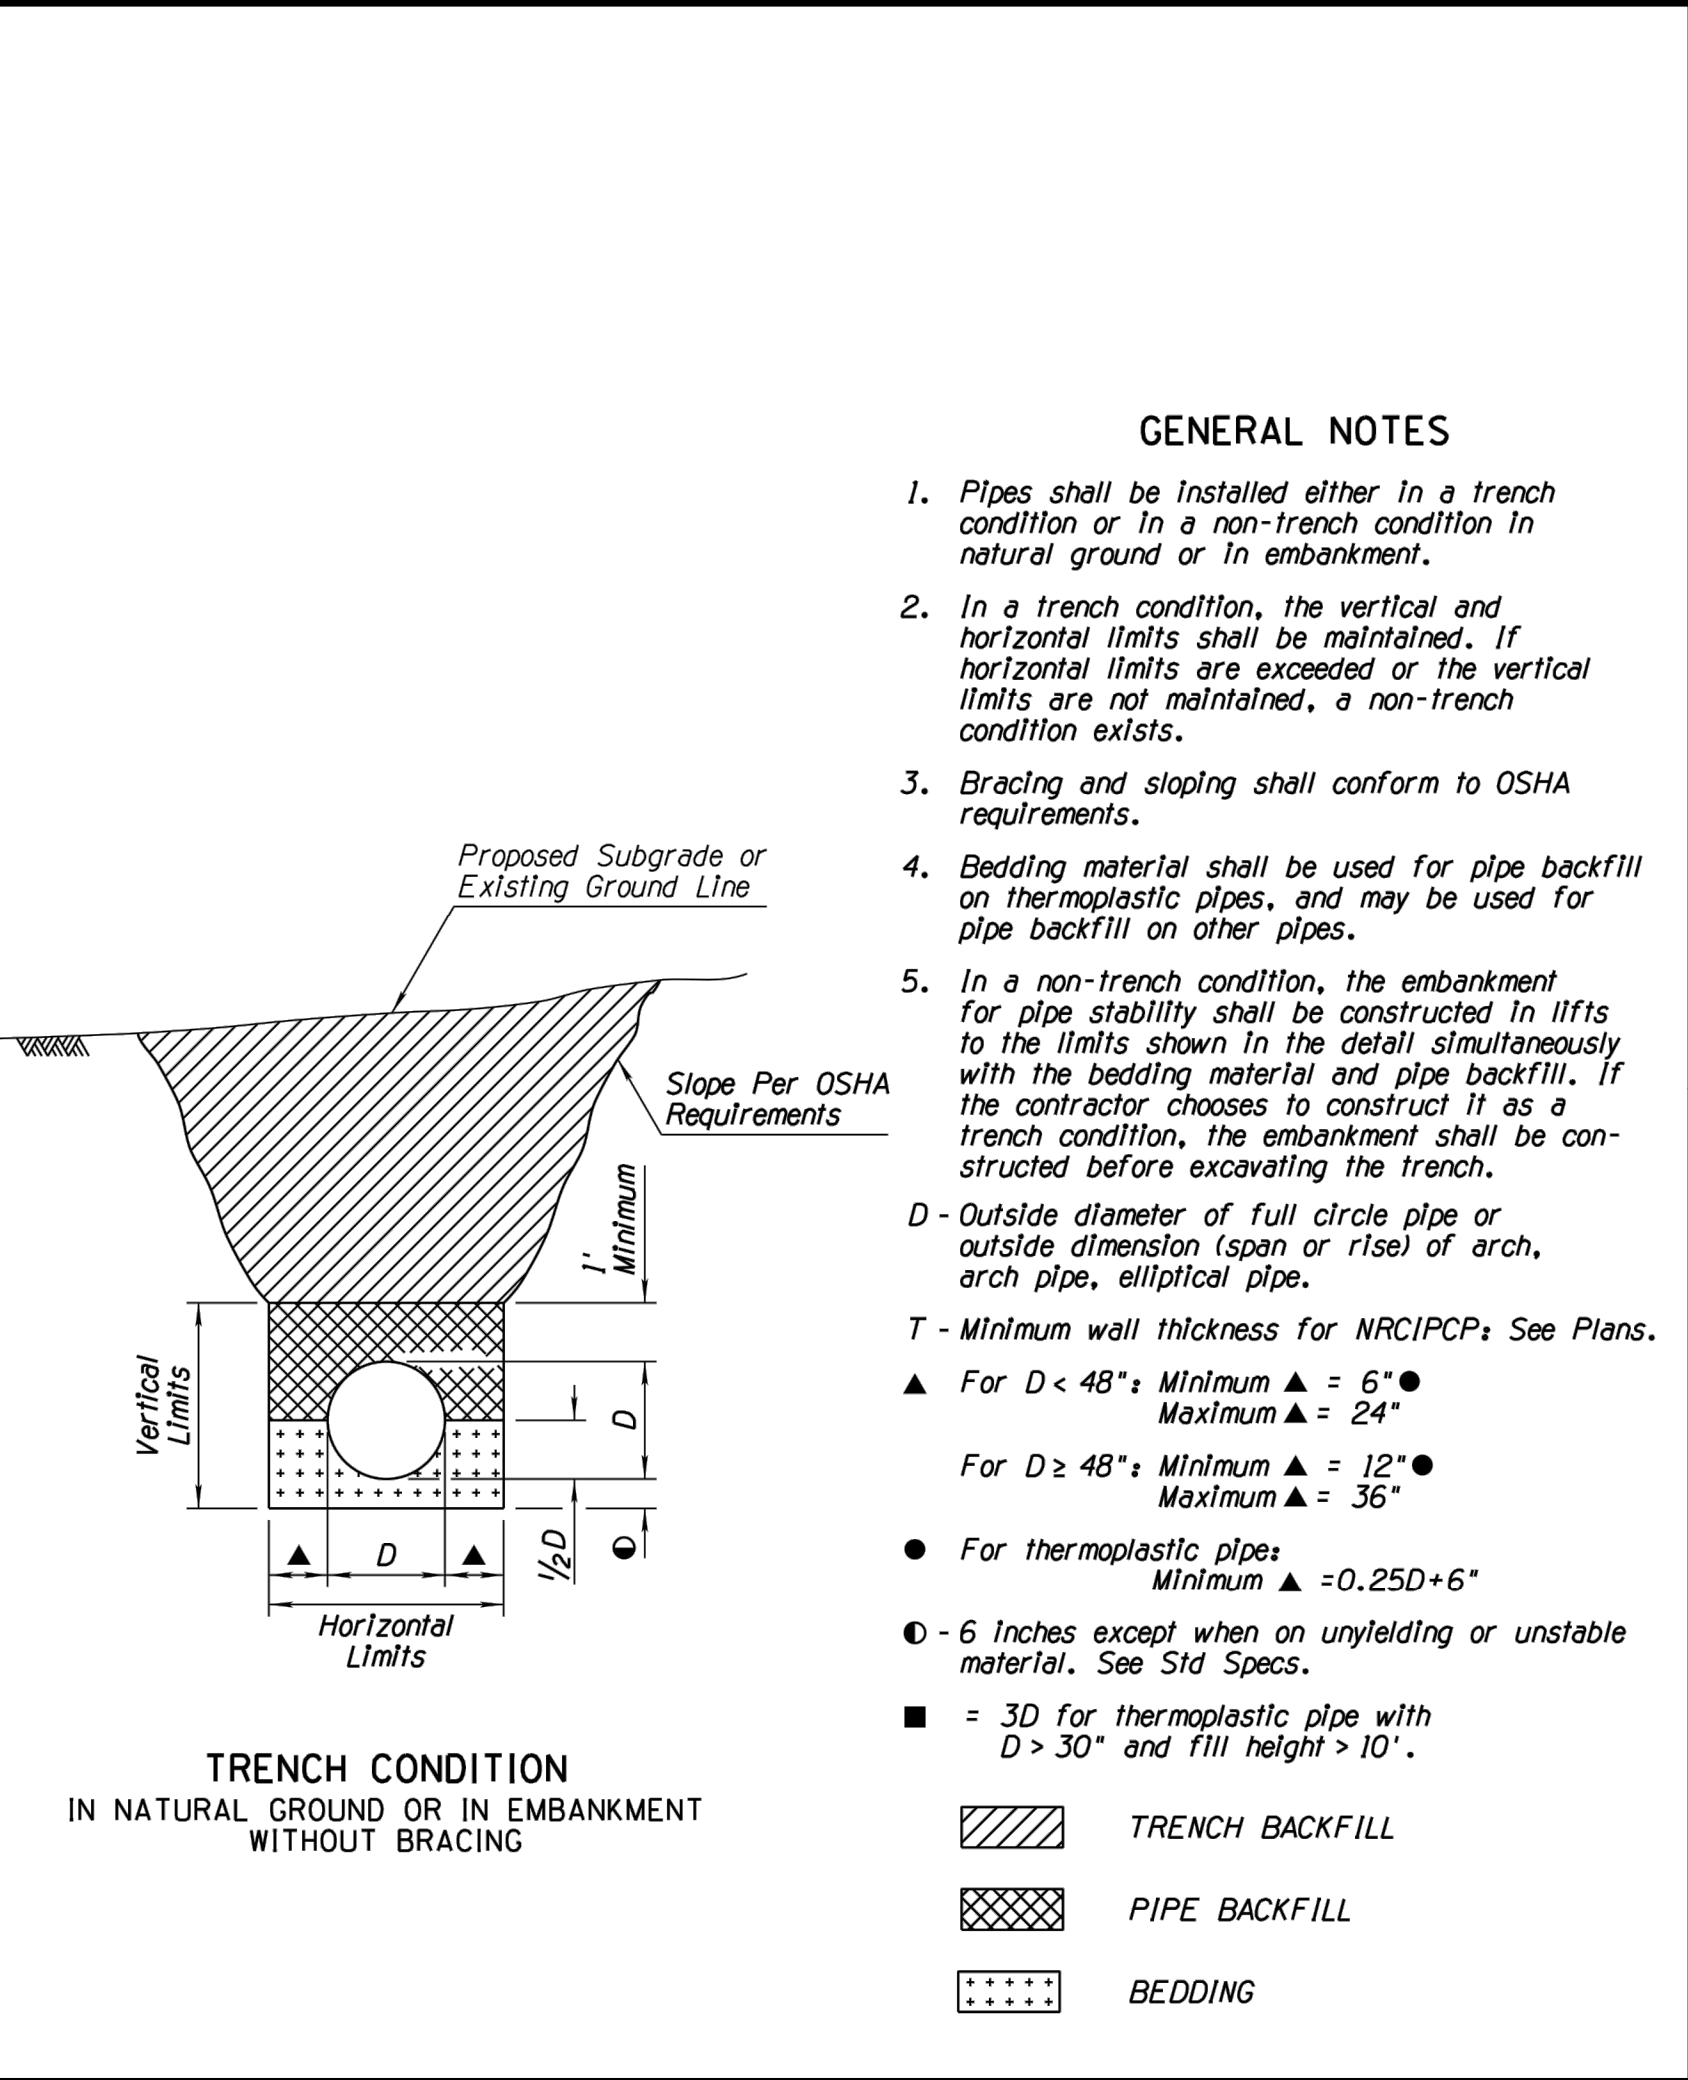

PER CITY OF PHOENIX CODE CHAPTER 2, SECTION 2-28, THESE PLANS ARE FOR OFFICIAL USE ONLY AND MAY NOT BE SHARED WITH OTHERS EXCEPT AS REQUIRED TO FULFILL THE OBLIGATIONS OF CONTRACTOR'S CONTRACT WITH THE CITY OF PHOENIX.

REGISTERED PROFESSIONAL ENGINEER
LANCE R. MCINTOSH
33442
AZ
Expires: 3-31-23

NO.	REVISIONS / SUBMISSIONS	DATE

PHX DVT CYR

CITY OF PHOENIX AVIATION DEPARTMENT

PHOENIX GOODYEAR AIRPORT
NEW APRON AND TAXIWAY CONNECTOR

AV41000077 FAA/ADOT


Designed by: RB	Drawn by: RB	Checked by: LM	Date: February 2023	Dwg. scale: 1"=6'



Sheet Overview Title



GRADING AND DRAINAGE
DETAILS

Sheet Reference Number:
CU501

Sheet 37 of 61

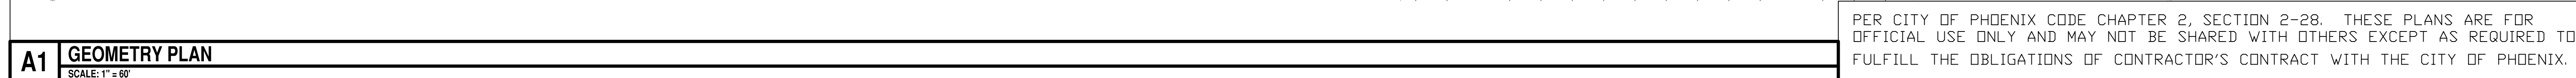

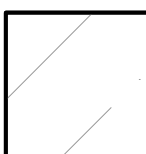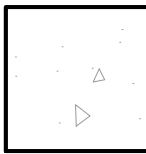
 EXISTING ASPHALTIC CONCRETE PAVEMENT  EXISTING CONCRETE PAVEMENT  PROPOSED FULL STRENGTH AC PAVEMENT STRUCTURAL SECTION  PROPOSED AC SHOULDER PAVEMENT STRUCTURAL SECTION  PROPOSED PCCP PAVEMENT STRUCTURAL SECTION 1 PAINT YELLOW REFLECTORIZED TAXIWAY CENTERLINE MARKING PER DETAIL D4, SHEET CM501 (BASE BID). ITEM P-620. 2 PAINT YELLOW REFLECTORIZED CONTINUOUS DOUBLE TAXIWAY EDGE MARKING PER DETAIL C4, SHEET CM501 (BASE BID). ITEM P-620. 3 PAINT YELLOW REFLECTORIZED NON-MOVEMENT AREA MARKING PER DETAIL A4, SHEET CM501 (BASE BID). ITEM P-620. 4 MATCH EXISTING MARKING. 5 PAINT YELLOW REFLECTORIZED TAXIWAY CENTERLINE MARKING PER DETAIL D4, SHEET CM501 (BASE BID). ITEM P-620. 6 PAINT YELLOW REFLECTORIZED CONTINUOUS DOUBLE TAXIWAY EDGE MARKING PER DETAIL C4, SHEET CM501 (BASE BID). ITEM P-620. 7 PAINT YELLOW REFLECTORIZED NON-MOVEMENT AREA MARKING PER DETAIL A4, SHEET CM501 (BASE BID). ITEM P-620.	D3 LEGEND NOT TO SCALE D4 CONSTRUCTION NOTES NOT TO SCALE
---	---

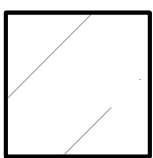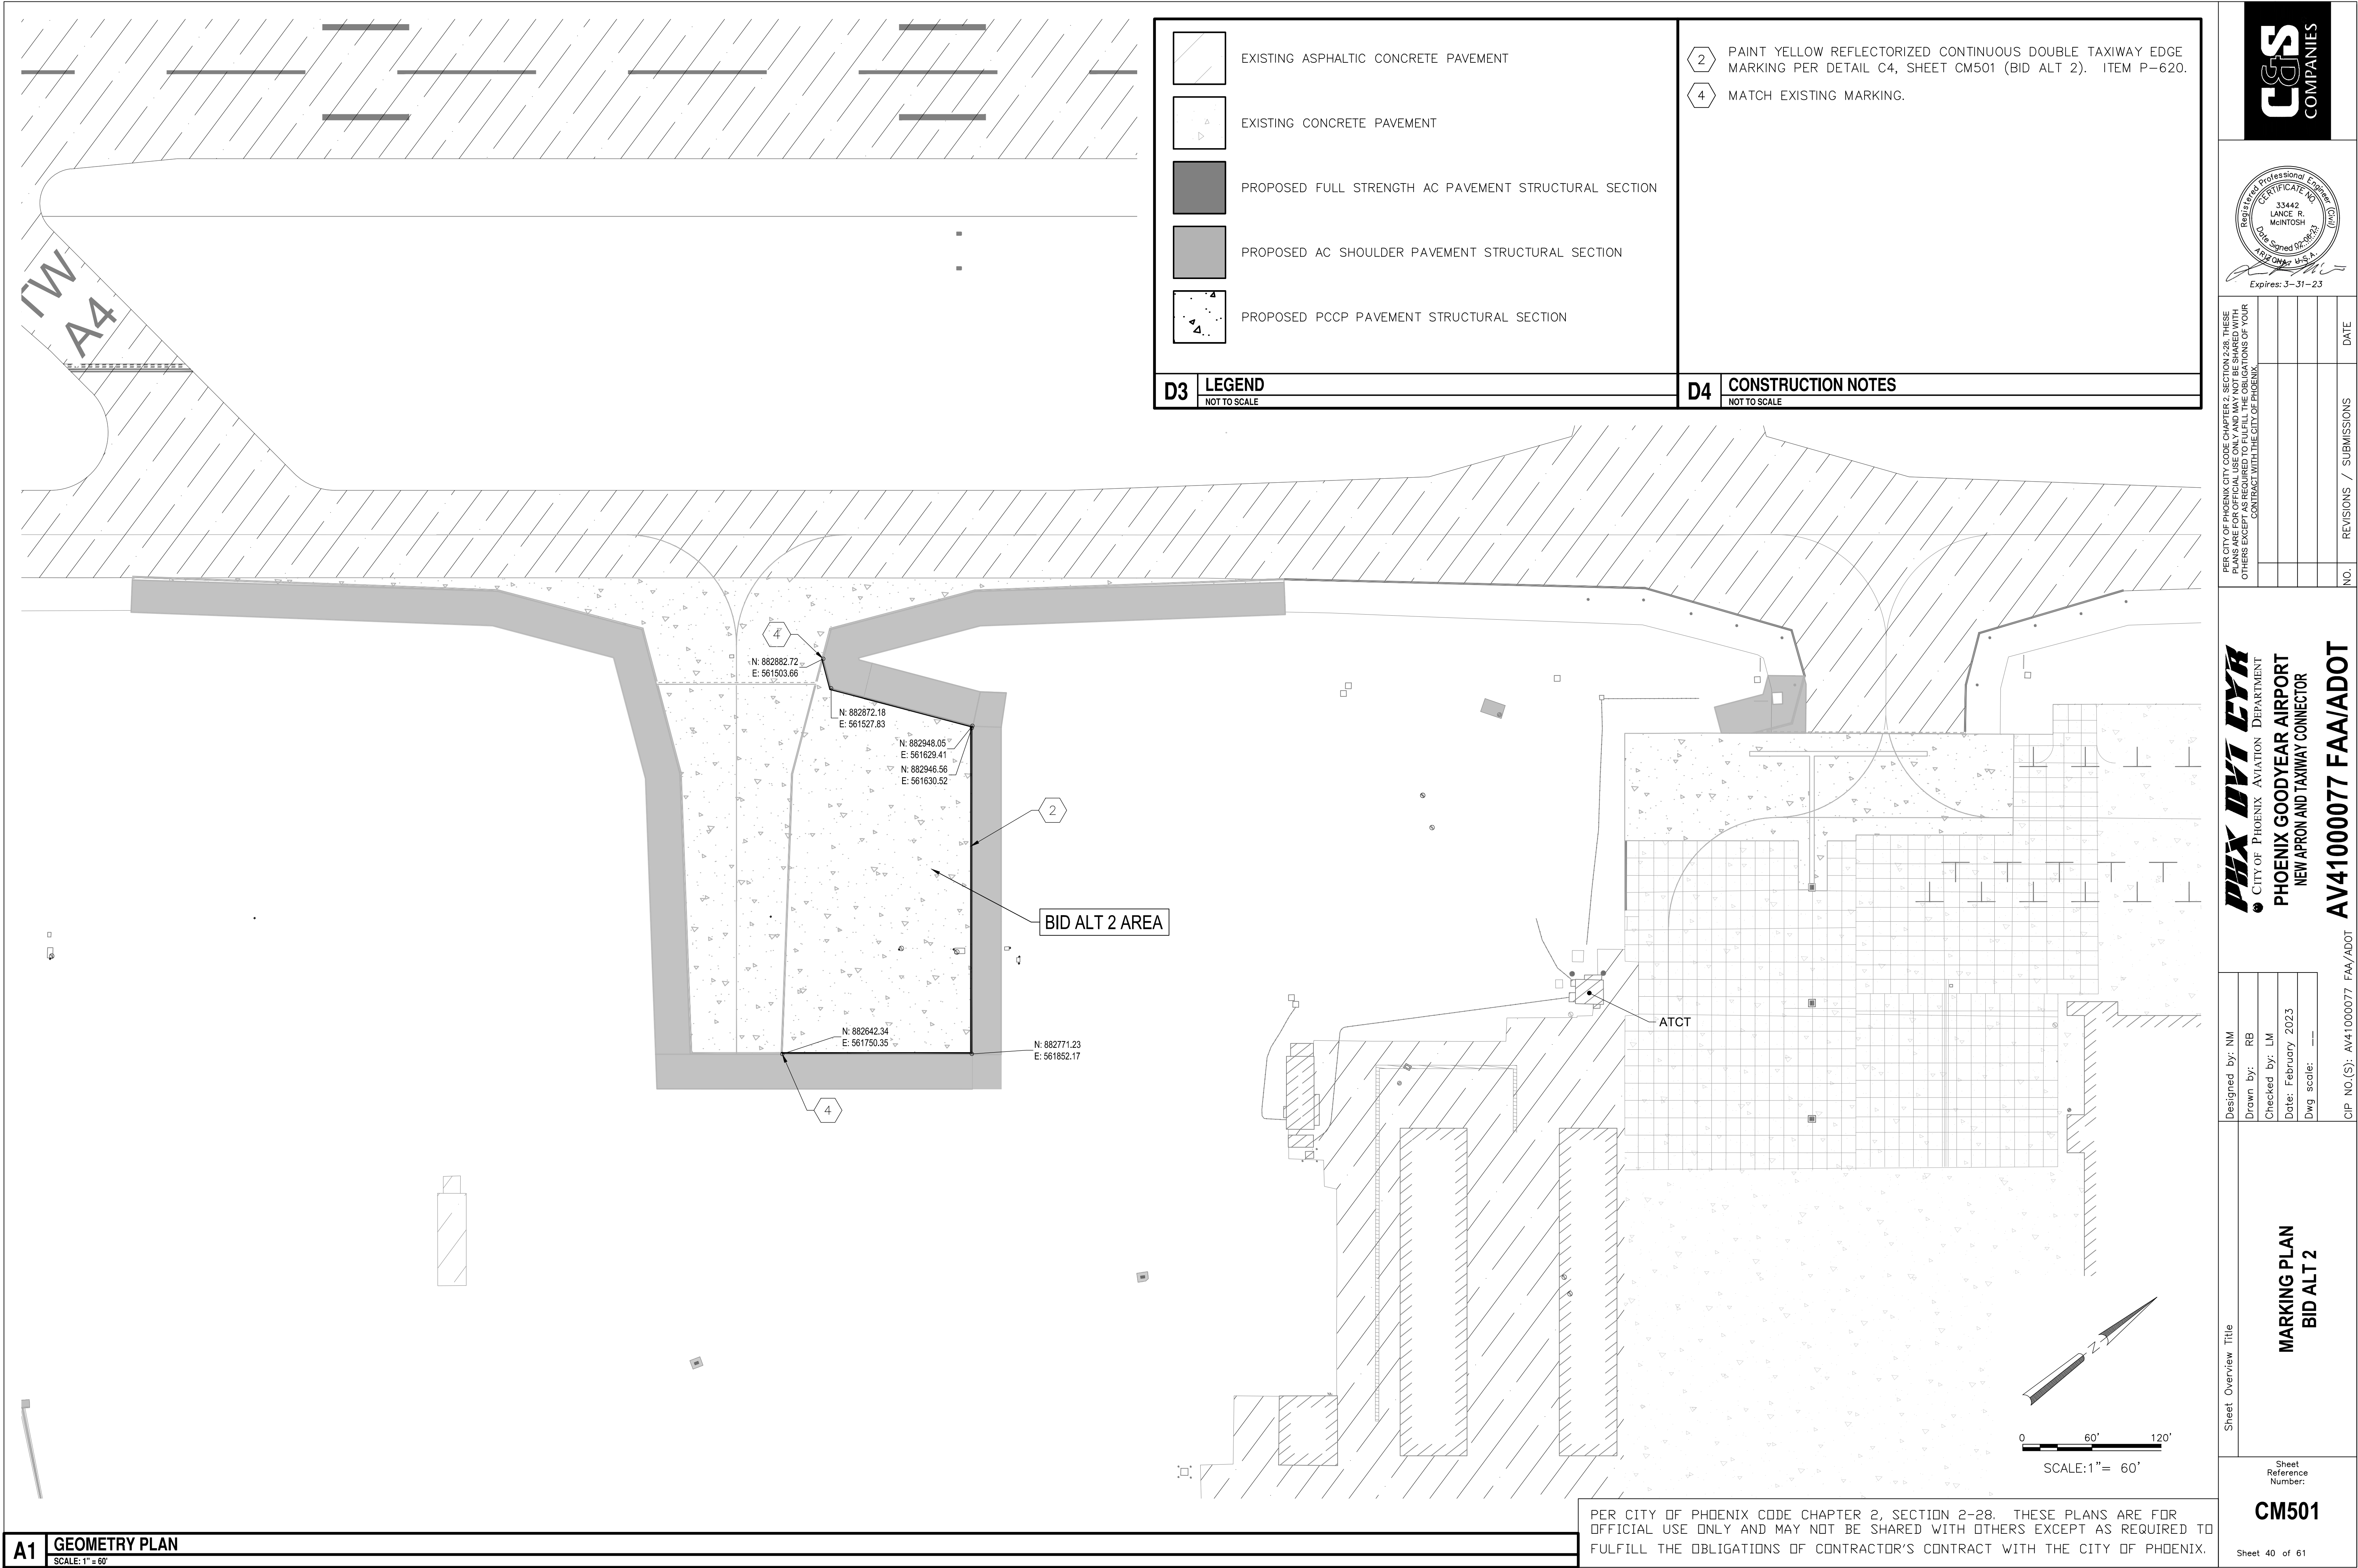


EXISTING ASPHALTIC CONCRETE PAVEMENT



 
EXISTING CONCRETE PAVEMENT



 PROPOSED FULL STRENGTH AC PAVEMENT STRUCTURAL SECTION



PROPOSED AC SHOULDER PAVEMENT STRUCTURAL SECTION

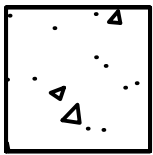

PROPOSED PCCP PAVEMENT STRUCTURAL SECTION

D3

LEGEND

NOT TO SCALE

2

PAINT YELLOW REFLECTORIZED CONTINUOUS DOUBLE TAXIWAY EDGE MARKING PER DETAIL C4, SHEET CM501 (BID ALT 2). ITEM P-620.

4

MATCH EXISTING MARKING.

D4

CONSTRUCTION NOTES

NOT TO SCALE

A1

GEOMETRY PLAN

SCALE: 1" = 60'

PER CITY OF PHOENIX CODE CHAPTER 2, SECTION 2-28. THESE PLANS ARE FOR OFFICIAL USE ONLY AND MAY NOT BE SHARED WITH OTHERS EXCEPT AS REQUIRED TO FULFILL THE OBLIGATIONS OF CONTRACTOR'S CONTRACT WITH THE CITY OF PHOENIX.

PER CITY OF PHOENIX CITY CODE CHAPTER 2, SECTION 2-28. THESE PLANS ARE FOR OFFICIAL USE ONLY AND MAY NOT BE SHARED WITH OTHERS EXCEPT AS REQUIRED TO FULFILL THE OBLIGATIONS OF YOUR CONTRACT WITH THE CITY OF PHOENIX.

NO.	REVISIONS / SUBMISSIONS	DATE



CITY OF PHOENIX AVIATION DEPARTMENT
PHOENIX GOODYEAR AIRPORT
NEW APRON AND TAXIWAY CONNECTOR

AV41000077 FAA/ADOT

Designed by: NM
Drawn by: RB
Checked by: LM
Date: February 2023
Dwg. scale: 1"=60'

Sheet Overview Title
**MARKING PLAN
BID ALT 2**
Sheet Reference Number:
CM501


CIP NO.(S): AV41000077 FAA/ADOT
Sheet 40 of 61

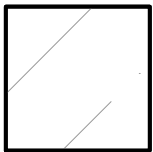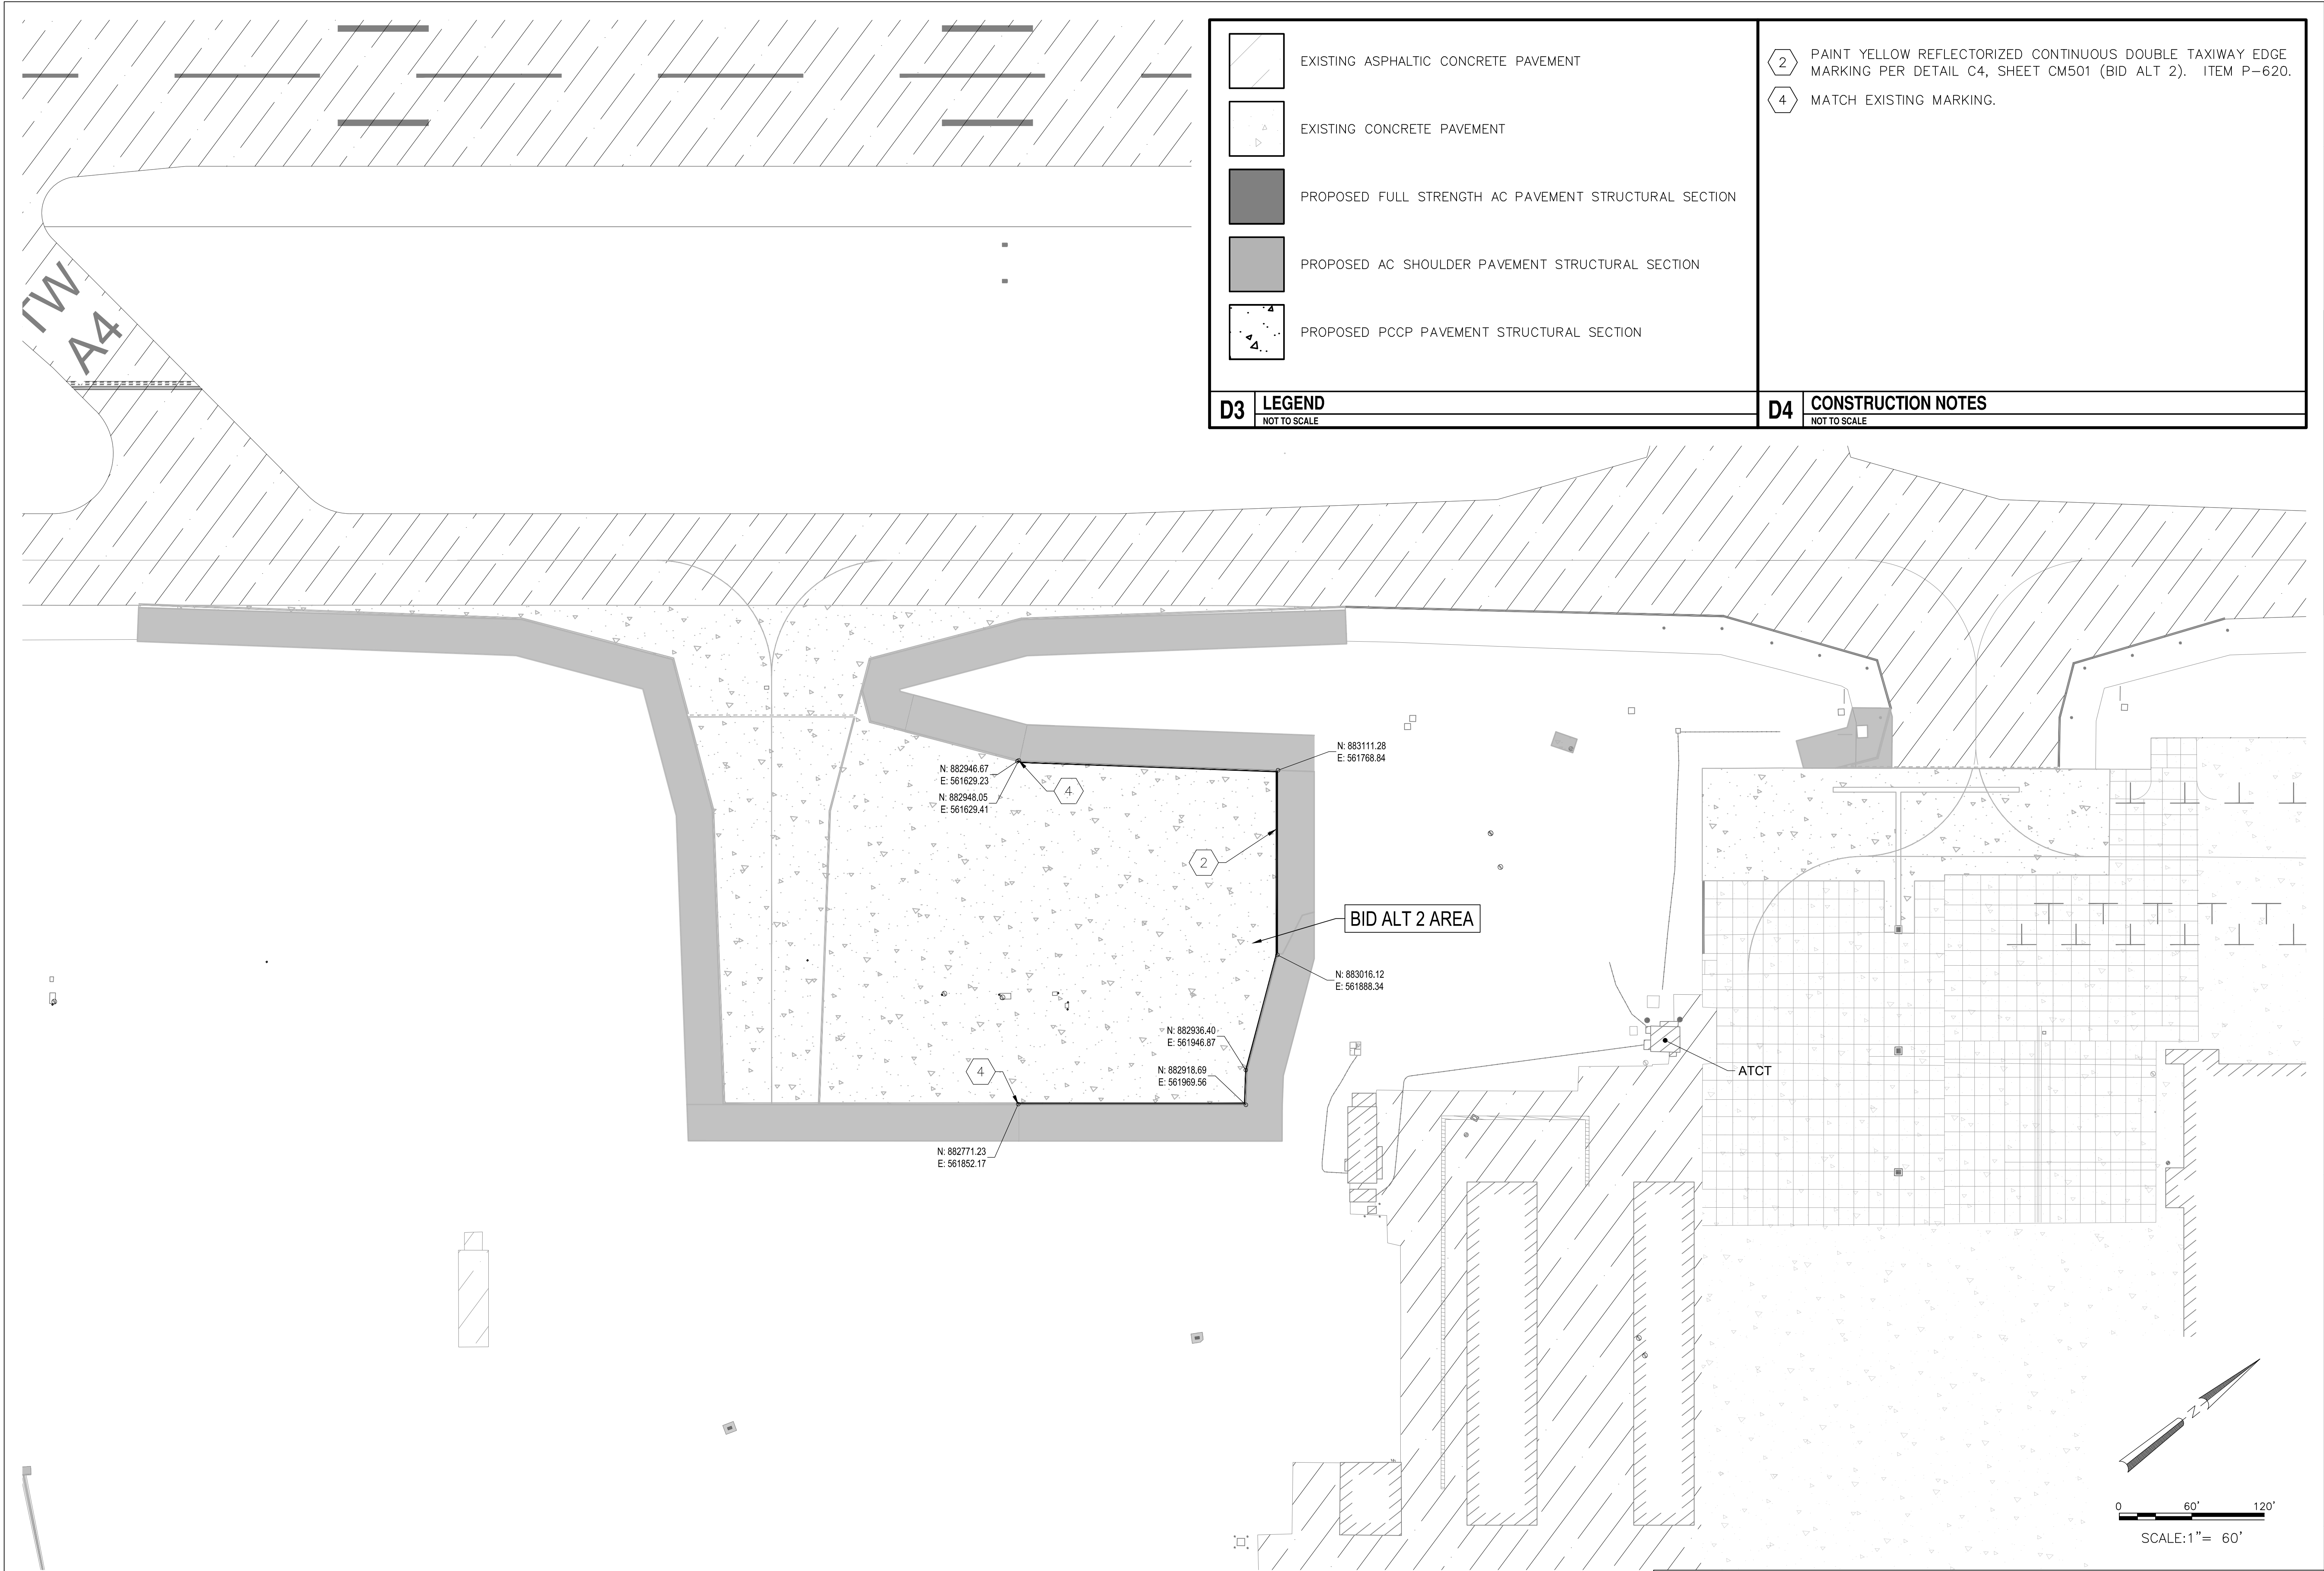


EXISTING ASPHALTIC CONCRETE PAVEMENT




EXISTING CONCRETE PAVEMENT

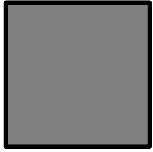

 PROPOSED FULL STRENGTH AC PAVEMENT STRUCTURAL SECTION



PROPOSED AC SHOULDER PAVEMENT STRUCTURAL SECTION

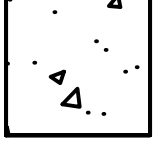

PROPOSED PCCP PAVEMENT STRUCTURAL SECTION

D3

LEGEND

NOT TO SCALE

2

PAINT YELLOW REFLECTORIZED CONTINUOUS DOUBLE TAXIWAY EDGE MARKING PER DETAIL C4, SHEET CM501 (BID ALT 2). ITEM P-620.

4

MATCH EXISTING MARKING.

D4

CONSTRUCTION NOTES


NOT TO SCALE

A1

GEOMETRY PLAN

SCALE: 1" = 60'

PER CITY OF PHOENIX CODE CHAPTER 2, SECTION 2-28. THESE PLANS ARE FOR OFFICIAL USE ONLY AND MAY NOT BE SHARED WITH OTHERS EXCEPT AS REQUIRED TO FULFILL THE OBLIGATIONS OF CONTRACTOR'S CONTRACT WITH THE CITY OF PHOENIX.

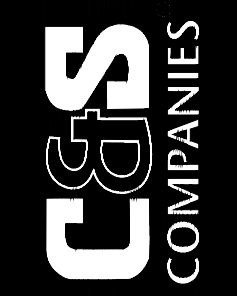

C&S
COMPANIES



Registered Professional Engineer
LANCE R. MCINTOSH
No. 33442
State of Arizona
Expires: 3-31-23

PER CITY OF PHOENIX CITY CODE CHAPTER 2, SECTION 2-28. THESE PLANS ARE FOR OFFICIAL USE ONLY AND MAY NOT BE SHARED WITH OTHERS EXCEPT AS REQUIRED TO FULFILL THE OBLIGATIONS OF YOUR CONTRACT WITH THE CITY OF PHOENIX.

NO.	REVISIONS / SUBMISSIONS	DATE

PHX DOT CYR
CITY OF PHOENIX AVIATION DEPARTMENT

PHOENIX GOODYEAR AIRPORT
NEW APRON AND TAXIWAY CONNECTOR

AV41000077 FAA/ADOT

Designed by: NM
Drawn by: RB
Checked by: LM
Date: February 2023
Dwg. scale: 1" = 60'


Sheet Overview Title


MARKING PLAN
BID ALT 3

Sheet Reference Number:
CM103

CIP NO.(S): AV41000077 FAA/ADOT

Sheet 41 of 61

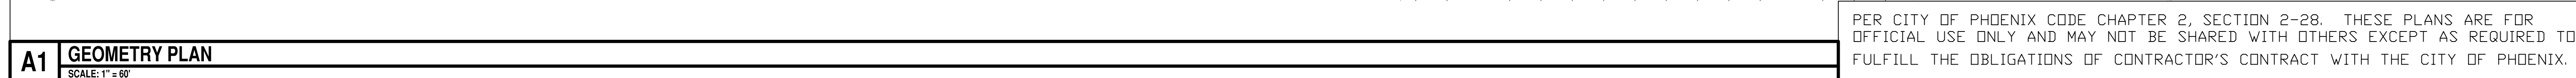[illegible]

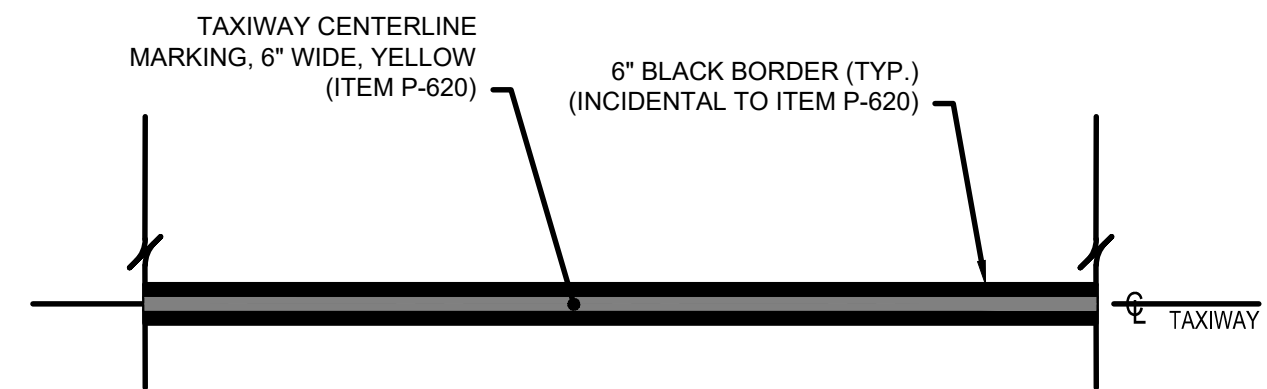


NOTES:

1. TAXIWAY CENTERLINE MARKINGS ARE INTERRUPTED FOR ALL RUNWAY MARKINGS UNLESS OTHERWISE NOTED.

D4	TAXIWAY CENTERLINE MARKING DETAIL
	NOT TO SCALE

NOT TO SCALE

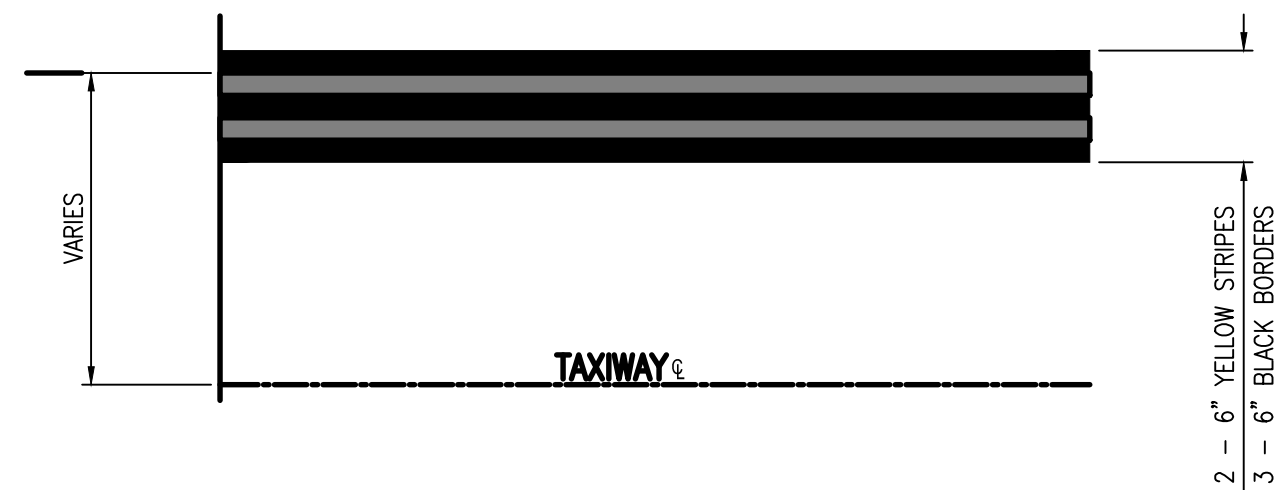


NOTES:

1. THE CONTINUOUS TAXWAY EDGE MARKING SHALL BE INTERRUPTED FOR RUNWAY HOLDING POSITION MARKINGS, INTERMEDIATE HOLDING POSITION MARKINGS, ILS/MLS HOLDING POSITION MARKINGS, AND NON-MOVEMENT AREA MARKINGS.
2. THE CONTINUOUS TAXWAY EDGE MARKINGS SHALL BEGIN AND END AT THE BLACK BORDER ASSOCIATED WITH THE ABOVE MENTIONED MARKINGS.
3. EDGE STRIPES WILL NOT HAVE AN OUTSIDE BORDER IF THERE IS NO PAVED SHOULDER.
4. BLACK NON-REFLECTORIZED BORDER MARKINGS SHALL BE INCIDENTAL TO ITEM P-820.


C4	CONTINUOUS DOUBLE SOLID TAXIWAY EDGE MARKING
----	--

NOT TO SCALE

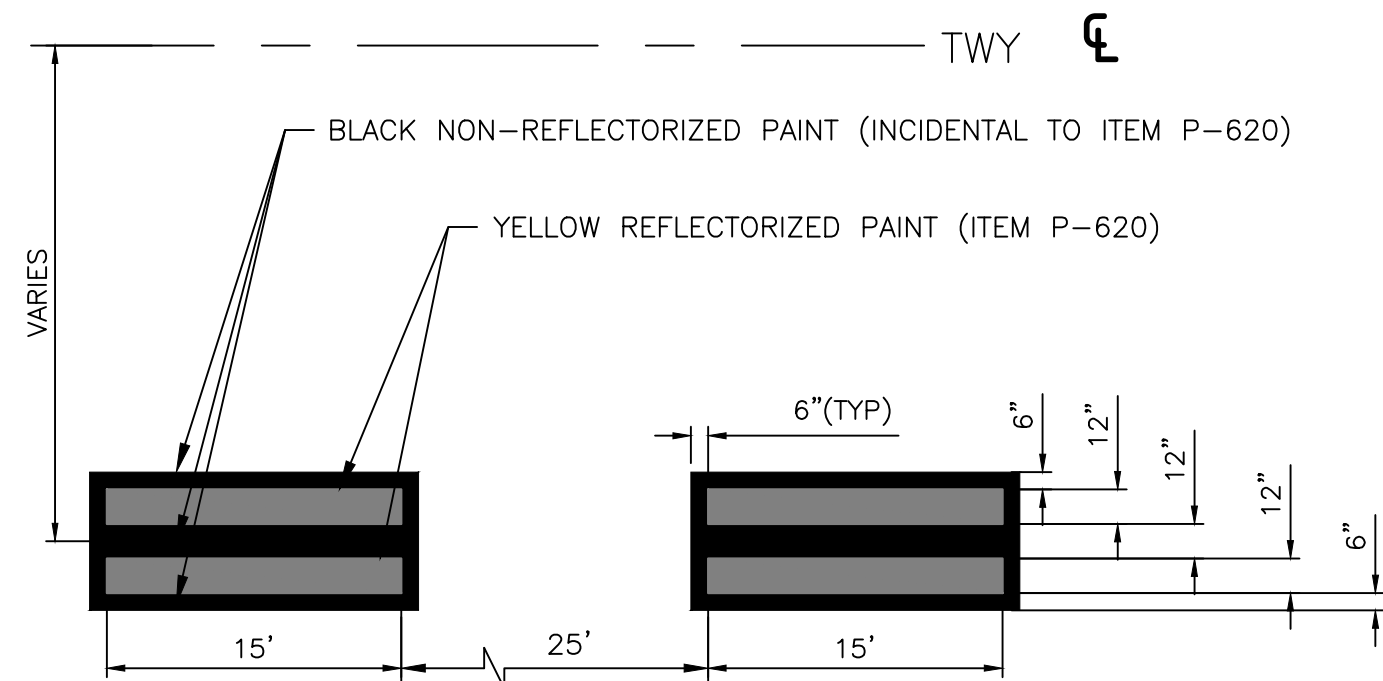

C3	DASHED TAXIWAY EDGE MARKING
----	-----------------------------

NOT TO SCALE

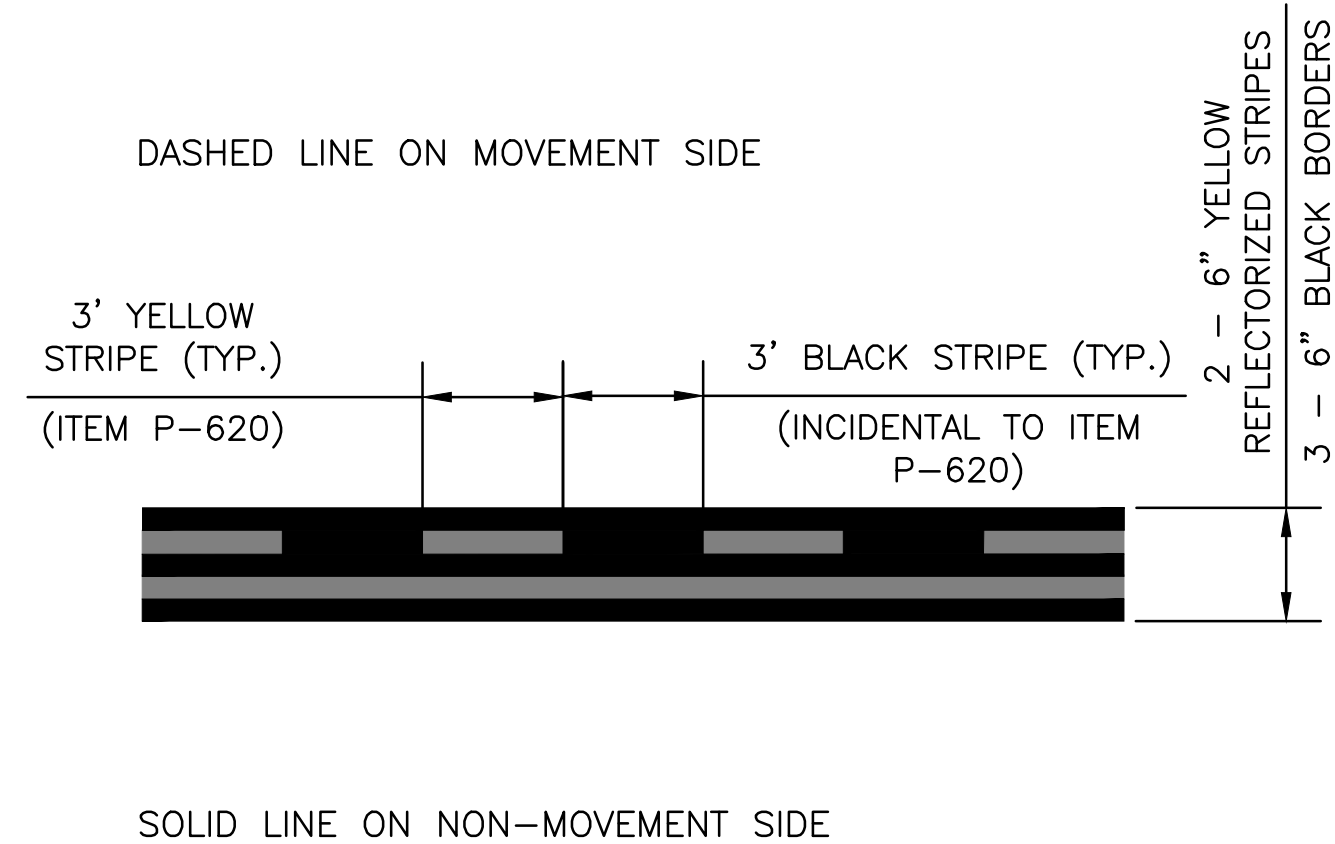

A4	NON MOVEMENT AREA MARKING DETAIL
	NOT TO SCALE

NOT TO SCALE

PER CITY OF PHOENIX CODE CHAPTER 2, SECTION 2-28. THESE PLANS ARE FOR OFFICIAL USE ONLY AND MAY NOT BE SHARED WITH OTHERS EXCEPT AS REQUIRED TO FULFILL THE OBLIGATIONS OF CONTRACTOR'S CONTRACT WITH THE CITY OF PHOENIX.



PER CITY OF PHOENIX CITY CODE CHAPTER 2, SECTION 2-28, THESE PLANS ARE FOR OFFICIAL USE ONLY AND MAY NOT BE SHARED WITH OTHERS EXCEPT AS REQUIRED TO FULFILL THE OBLIGATIONS OF YOUR CONTRACT WITH THE CITY OF PHOENIX.

NO.	REVISIONS / SUBMISSIONS	DATE

PHILIP LEE

PHOENIX GOODYEAR AIRPORT
NEW APRON AND TAXIWAY CONNECTOR

AV41000077 FAA/ADOT

CIP NO.(S): AV41000077 FAA/ADOT

Designed by: NM
Drawn by: RB
Checked by: LM
Date: February 2023
Dwg scale: 1:1

Sheet	Overview	Title
-------	----------	-------

MARKING DETAILS

Sheet
Reference
Number:


CM501

ELECTRICAL ABBREVIATIONS:

2/C	TWO CONDUCTORS
ATCT	AIR TRAFFIC CONTROL TOWER
BCC	BARE COPPER GROUND
CE	CONCRETE ENCASED
CKT	CIRCUIT
COMM	COMMUNICATIONS
DIA	DIAMETER
FAA	FEDERAL AVIATION ADMINISTRATION
FMC	FLEXIBLE METAL CONDUIT
GRS	GALVANIZED RIGID STEEL
LED	LIGHT EMITTING DIODE
LF	LINEAR FEET
NPI	NON PAY ITEM
OFA	OBJECT FREE AREA
PAPI	PRECISION APPROACH PATH INDICATOR
PVC	POLY-VINYL CHLORIDE
REIL	RUNWAY END INDICATOR LIGHT
RGL	RUNWAY GUARD LIGHT
RSA	RUNWAY SAFETY AREA
SE	SLURRY ENCASED
SES	SERVICE ENTRANCE SECTION
SGN	SIGN
SWS	SURFACE WEATHER OBSERVATION STATION
TSA	TAXIWAY SAFETY AREA
TYP	TYPICAL

ELECTRICAL LEGEND:

(UNLESS OTHERWISE NOTED ON PLANS)

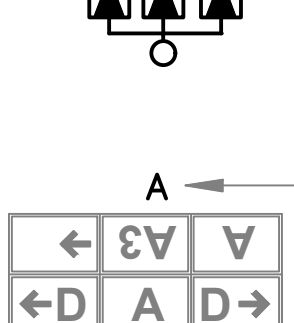	PVC W/#8-5KV L-824 TYPE "C" CABLE PER INDICATED LIGHTING CIRCUIT. (QUANTITY AND SIZE AS INDICATED ON PLAN SHEETS)
	EXISTING ELECTRICAL CONDUIT AND CONDUCTOR
	EXISTING SPARE CONDUCT DUCTBANKS EXTENDED FIVE (5) FEET BEYOND EDGE OF NEW TAXIWAY SHOULDER AND CAPPED
	EXISTING AIRFIELD GUIDANCE SIGN
	EXISTING TAXIWAY EDGE LIGHT
	EXISTING HANDHOLE
	NEW HANDHOLE
	NEW L-858(L) LED AIRFIELD GUIDANCE SIGN
	NEW L-861T(LED) ELEVATED TAXIWAY EDGE LIGHT ON NEW L-867 BASE
	NEW APRON LIGHT
	A ← SIGN FACE ← D ← A ← V ← X ← SIGN NUMBER B ← SIGN FACE
	NEW PULLBOX

AIRFIELD CIRCUITS:


PPN	PAPI NORTH	RW	RUNWAY
PPS	PAPI SOUTH	SG	SIGN
RGL	RUNWAY GUARD LIGHT	TWN	TAXIWAY NORTH
RLN	REIL NORTH	TWS	TAXIWAY SOUTH
RLS	REIL SOUTH		

SHEET INDEX

E-101	ELECTRICAL LEGEND AND NOTES
E-102	ELECTRICAL NOTES
ED101	AIRFIELD ELECTRICAL DEMOLITION PLAN
EA101 – EA104	AIRFIELD ELECTRICAL INSTALLATION PLAN
EA401	APRON LIGHT PHOTOMETRICS (BID ALT #1)
EA501	ELECTRICAL DUCTBANK DETAILS
EA502	GROUNDING DETAILS
EA503	HANDHOLE DETAILS
EA504	2'X2'X3' HANDHOLE AND JUNCTION BOX DETAILS
EA505	ELEVATED TAXIWAY EDGE LIGHT AND APRON LIGHT DETAILS
EA506	AIRFIELD GUIDANCE SIGN BASE DETAILS
EA507	AIRFIELD GUIDANCE SIGN DETAILS
EA601	SIGN SCHEDULE AND EQUIPMENT DATA TABLES
EA602	SINGLE LINE DIAGRAM AND LOAD CALCULATIONS
EA603	PANEL SCHEDULE AND LIGHTING CONTROL SCHEMATIC



ADVISORY CIRCULARS FOR AIRPORT PROJECTS (USE LATEST VERSION):

150/5340-18	STANDARDS FOR AIRPORT SIGN SYSTEMS
150/5340-30	DESIGN AND INSTALLATION DETAILS FOR AIRPORT VISUAL AIDS
150/5345-7	SPECIFICATION FOR L-824 UNDERGROUND ELECTRICAL CABLE FOR AIRPORT LIGHTING CIRCUITS
150/5345-26	SPECIFICATION FOR L-823 PLUG AND RECEPTACLE, CABLE CONNECTORS
150/5345-42	SPECIFICATION FOR AIRPORT LIGHT BASES, TRANSFORMER HOUSINGS, JUNCTION BOXES, AND ACCESSORIES
150/5345-44	SPECIFICATION FOR RUNWAY AND TAXIWAY SIGNS
150/5345-46	SPECIFICATION FOR RUNWAY AND TAXIWAY LIGHT FIXTURES
150/5345-47	SPECIFICATION FOR SERIES TO SERIES ISOLATION TRANSFORMERS FOR AIRPORT LIGHTING SYSTEMS
150/5345-53	AIRPORT LIGHTING EQUIPMENT CERTIFICATION PROGRAM
150/5370-2	OPERATIONAL SAFETY ON AIRPORTS DURING CONSTRUCTION
150/5370-10	STANDARDS FOR SPECIFYING CONSTRUCTION OF AIRPORTS
ADDENDUM	AIRPORT LIGHTING EQUIPMENT CERTIFICATION PROGRAM (PUBLISHED MONTHLY AND LISTING APPROVED SUPPLIERS)

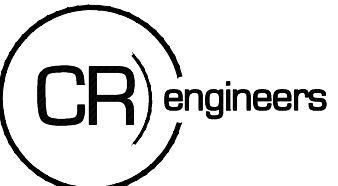

16719 East Palisades Blvd., Suite 202
Fountain Hills, AZ 85268
Phone: (480) 816-5541
Fax: (480) 816-5540

PER CITY OF PHOENIX CODE CHAPTER 2, SECTION 2-28. THESE PLANS ARE FOR OFFICIAL USE ONLY AND MAY NOT BE SHARED WITH OTHERS EXCEPT AS REQUIRED TO FULFILL THE OBLIGATIONS OF CONTRACTOR'S CONTRACT WITH THE CITY OF PHOENIX.

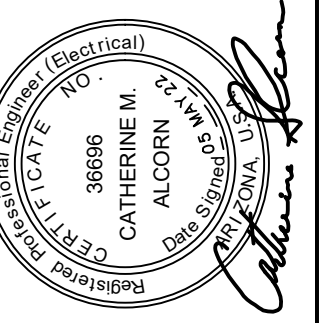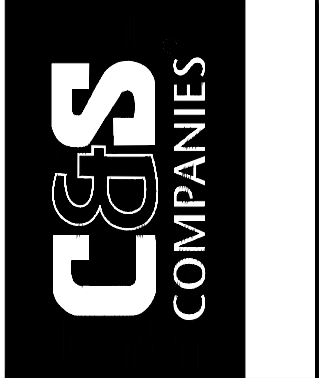

PER CITY OF PHOENIX CITY CODE CHAPTER 2, SECTION 2-28, THESE PLANS ARE FOR OFFICIAL USE ONLY AND MAY NOT BE SHARED WITH OTHERS EXCEPT AS REQUIRED TO FULFILL THE OBLIGATIONS OF YOUR CONTRACT WITH THE CITY OF PHOENIX.			
NO.	REVISIONS /	SUBMISSIONS	DATE



CITY OF PHOENIX AVIATION DEPARTMENT
PHOENIX GOODYEAR AIRPORT
NEW APRON AND TAXIWAY CONNECTOR

AV41000077 FAA/ADOT

Designed by: SW	JCA
Drawn by:	CA
Checked by:	May 2022
Date:	Dwg scale:

Sheet Overview Title

ELECTRICAL LEGEND AND NOTES

Sheet Reference Number:

E-101

Sheet 44 of 61

ELECTRICAL DEMOLITION GENERAL NOTES

1.

WITHIN AREAS OF DEMOLITION AND AS OTHERWISE SHOWN, REMOVE IDENTIFIED SIGN BASES, ISOLATION TRANSFORMERS AND OTHER INDICATED ITEMS.
2.

CABLE REMOVAL

A. DIRECT BURIAL: REMOVE FROM WITHIN MANHOLES AND HANDHOLES AND REMOVE IN AREAS WHERE EXCAVATION REQUIRES DISTURBING, ABANDON ELSEWHERE.

B. IN CONDUIT: REMOVE COMPLETELY BETWEEN NEAREST BASES, HANDHOLES OR MANHOLES.
3.

AT INDICATED DEVICES TO BE REMOVED OR IN DEMOLITION AREAS INDICATED, REMOVE ALL CONDUCTORS BACK TO NEAREST MANHOLE OR HANDHOLE OUTSIDE DEMOLITION AREA.
4.

SIGNS AND/OR SIGN BASES, CABLES, CONDUITS, DUCTS, ETC. WHICH ARE NOT SPECIFICALLY INDICATED TO BE REMOVED (OR WHICH ARE SHOWN TO REMAIN WITHIN AREAS OF GENERAL DEMOLITION) SHALL REMAIN IN-PLACE AND FUNCTIONAL.
5.

CONTRACTOR SHALL VERIFY EQUIPMENT AND CABLE DESIGNATIONS AND STATUS PRIOR TO REMOVAL OR DISCONNECTING.
6.

UNLESS OTHERWISE NOTED, ALL REMOVED MATERIAL SHALL BECOME THE PROPERTY OF THE CONTRACTOR AND SHALL BE REMOVED FROM THE SITE AND DISPOSED OF IN ACCORDANCE WITH APPLICABLE LOCAL ORDINANCES. REMOVED LIGHT FIXTURE AND SIGNS NOT DESIGNATED FOR RE-INSTALLATION SHALL BE OFFERED TO AIRPORT FOR RETURN UNLESS OTHERWISE NOTED.
7.

DRAWINGS MAY NOT DETAIL ALL EXISTING FACILITIES IN AREAS OF DEMOLITION. CONTRACTOR SHALL REVIEW THE SITE AND RECORD DRAWINGS TO VERIFY THE DEMOLITION EFFORT INVOLVED.
8.

EXISTING SIGNS MUST REMAIN OPERATIONAL DURING CONSTRUCTION. TEMPORARY CONNECTIONS TO EXISTING SIGNS REQUIRED DURING RELOCATION. TEMPORARY MOUNTING OF EXISTING SIGNS REQUIRED WHERE NEW LOCATION CONFLICTS WITH EXISTING LOCATION.
9.

CONTRACTOR SHALL BE REQUIRED TO HAVE A PRIVATE ON-SITE UTILITY LOCATING COMPANY AND POTHOLE EXISTING UTILITY LINES AS NEEDED.

AIRFIELD LIGHT LOCKOUT/TAGOUT POLICY

THE PURPOSE OF THIS POLICY IS TO STANDARDIZE THE LOCKOUT/TAGOUT PROCEDURES BETWEEN ELECTRICAL CONTRACTORS, GOODYEAR AIRPORT ELECTRICIANS, OPERATIONS AND AIR TRAFFIC CONTROL TOWER (ATCT).

1.

GOODYEAR AIRPORT ELECTRICIANS RESPONDING TO A LOCK-OUT/TAG-OUT REQUEST WILL COORDINATE WITH THE ATCT THROUGH OPERATIONS.
2.

AFTER OPERATIONS NOTIFIES ELECTRICIANS OF CLOSURES, THE GOODYEAR AIRPORT ELECTRICIANS WILL TURN OFF THE CLOSED RUNWAYS/TAXIWAYS USING THE AIRFIELD COMPUTER SYSTEM.
3.

THE CONTRACTOR WILL SUPPLY AN APPROVED BREAKER-LOCKING DEVICE AND LOCK, THEN LOCK OF THE INDIVIDUAL BREAKERS FOR THE CIRCUITS TO BE LOCKED OUT. THESE ITEMS WILL REMAIN IN THE VAULTS IN A LOCK BOX PROVIDED BY GOODYEAR AIRPORT ELECTRICAL SECTION.
4.

GOODYEAR AIRPORT ELECTRIC SECTION WILL LOCK THE PANEL DOORS SHUT WITH A HASP AND AN ELECTRICAL SECTION LOCK.
5.

THE S-1 CUTOUTS WILL BE PULLED, LOCKED AND PLACED ON THE CORRESPONDING REGULATOR BY THE ELECTRICAL CONTRACTOR.
6.

THE ELECTRICAL CONTRACTOR AND GOODYEAR AIRPORT ELECTRICIANS MUST FILL OUT LOCK-OUT FORMS BEFORE LEAVING THE VAULT.
7.

UPON COMPLETION OF THE LOCKOUT, THE CONTRACTOR WILL REMOVE ALL LOCKS AND INSTALL THE S-1 CUTOUTS. ALL CIRCUITS MUST BE VERIFIED OPERATIONAL IN THE MANUAL MODE ON THE REGULATOR. OPERATIONS WILL PERFORM A COMPLETE CHECK OF THE LIGHTS IN THE FIELD, TO VERIFY ACTUAL OPERATION.
8.

WHEN THAT HAS BEEN COMPLETED, GOODYEAR AIRPORT ELECTRICIANS WILL NOTIFY OPERATIONS WHEN LOCK-IN IS COMPLETE AND REGULATORS ARE IN REMOTE CONTROL; OPERATIONS WILL NOTIFY THE ATCT THAT HAVE CONTROL OF THE AIRFIELD LIGHTING.
9.

COMPLETE LOCK-OUT/LOCK-IN FORMS.

THIS PROCEDURAL CHECKLIST MUST BE FOLLOWED TO THE LETTER

ELECTRICAL CONSTRUCTION PHASING NOTES

1.

CONTRACTOR SHALL COORDINATE ALL WORK WITH AIRPORT MAINTENANCE, AIRPORT OPERATIONS, AND THE ENGINEER AS NECESSARY.
2.

CONTRACTOR SHALL GIVE 72 HOURS NOTICE PRIOR TO WORKING ON OR AROUND ANY DUCTBANKS, HANDHOLES, ETC.
3.

CONTRACTOR SHALL MAINTAIN OR HAVE SUFFICIENT MATERIAL/ EQUIPMENT REQUIRED TO PROVIDE TEMPORARY LIGHTING AND CIRCUIT EXTENSIONS. THIS INCLUDES, BUT IS NOT LIMITED TO FIXTURES, TRANSFORMERS, BASES, CONDUIT, L-824 CABLE & L-823 SPLICE KITS. THESE ITEMS WILL NOT BE AVAILABLE FROM THE GOODYEAR MAINTENANCE SHOP.
4.

THE CONTRACTOR SHALL MAINTAIN QUALIFIED PERSONNEL WITH THE APPROPRIATE EQUIPMENT, FOR THE INSTALLATION AND SPLICING OF AIRFIELD LIGHTING. SUCH PERSONNEL SHALL BE CAPABLE OF 60 MINUTE RESPONSE TIME IF THEY ARE NOT ALREADY PRESENT ON THE AIRFIELD.
5.

TURN OFF AND COVER EXISTING SIGNAGE THAT MAY POTENTIALLY MISDIRECT AIRCRAFT MOVEMENT INTO CLOSED AREAS BARRICADED FOR CONSTRUCTION. SIGNAGE REQUIRING PARTIAL COVERAGE WITH TAXIWAY LOCATION PANELS REMAINING VISIBLE SHALL REMAIN ON WITH ONLY DIRECTIONAL PORTIONS COVERED WITH SECTIONS OF DARK COLORED TARP OR DOUBLE-LAYERED BURLAP THAT DOES NOT PERMIT VISIBILITY OF COVERED PORTION OF ARRAY DAY OR NIGHT. COVERS SHALL BE SECURELY HELD IN PLACE BY RATCHETING LASHING STRAPS, NO TAPE OR ADHESIVES WILL BE PERMITTED. SEE PHASING PLANS FOR PLACEMENT OF SIGN COVERS.
6.

COVER EXISTING ELEVATED EDGE LIGHT FIXTURES IN CLOSED AREA BARRICADED FOR CONSTRUCTION WITH 4" PVC PIPE. COVER SHALL EXTEND 2" MIN. ABOVE TOP OF FIXTURE.
7.

PROVIDE ANY TEMPORARY AIRFIELD CIRCUIT JUMPERS REQUIRED TO MAINTAIN OPERATION OF ALL CIRCUITS AFFECTED BY CONSTRUCTION PRIOR TO START OF DEMOLITION. TEMPORARY CIRCUIT JUMPERS SHALL BE SLEEVED IN 2" CONDUIT, SANDBAGGED OR SECURED TO LOW-LEVEL BARRICADES. TEMPORARY CIRCUIT JUMPERS MAY BE ROUTED THROUGH NEW TAXIWAY CROSSINGS OR EXISTING SPARE CONDUITS AS REQUIRED AND SHALL BE COMPLETELY REMOVED WHEN NO LONGER REQUIRED FOR OPERATION. TEMPORARY JUMPER PLACEMENT SHALL NOT AFFECT AIRCRAFT MOVEMENT OR AIRPORT OPERATIONS.
8.

UNCOVER SIGNS AND EDGE LIGHT FIXTURES, REMOVE TEMPORARY JUMPERS, AND VERIFY OPERATION AT THE END OF PROJECT.


ELECTRICAL GENERAL NOTES

1.

GROUND'S RODS AND COUNTERPOISE WIRE ARE CONSIDERED INCIDENTAL TO FIXTURE AND CONDUIT INSTALLATION.
2.

ELECTRICAL CONTRACTOR SHALL COORDINATE ALL DEMOLITION AND CONSTRUCTION WITH CIVIL CONTRACTOR TO REDUCE CONFLICTS THAT AFFECT CONSTRUCTION PHASING AND SCHEDULING.
3.

CONTRACTOR SHALL FIELD VERIFY ALL FIXTURE STATION AND OFFSETS AND CONFIRM ALL LOCATIONS ARE WITHIN SPECIFICATION TOLERANCES.

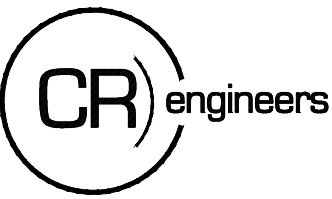

16719 East Palisades Blvd., Suite 202
Fountain Hills, AZ 85208
Phone: (480) 816-5541
Fax: (480) 816-5540

PER CITY OF PHOENIX CODE CHAPTER 2, SECTION 2-28. THESE PLANS ARE FOR OFFICIAL USE ONLY AND MAY NOT BE SHARED WITH OTHERS EXCEPT AS REQUIRED TO FULFILL THE OBLIGATIONS OF CONTRACTOR'S CONTRACT WITH THE CITY OF PHOENIX.



PER CITY OF PHOENIX CITY CODE CHAPTER 2, SECTION 2-28, THESE PLANS ARE FOR OFFICIAL USE ONLY AND MAY NOT BE SHARED WITH OTHERS EXCEPT AS REQUIRED TO FULFILL THE OBLIGATIONS OF YOUR CONTRACT WITH THE CITY OF PHOENIX.			
			DATE
			REVISIONS / SUBMISSIONS
			NO.



CITY OF PHOENIX AVIATION DEPARTMENT
PHOENIX GOODYEAR AIRPORT
NEW APRON AND TAXIWAY CONNECTOR

AV41000077 FAA/ADOT

Designed by: SW
Drawn by: JCA
Checked by: CA
Date: May 2022
Dwg scale:


CIP NO.(S): AV41000077 FAA/ADOT

Sheet Overview Title
ELECTRICAL NOTES

Sheet Reference Number:

E-102


Sheet 45 of 61

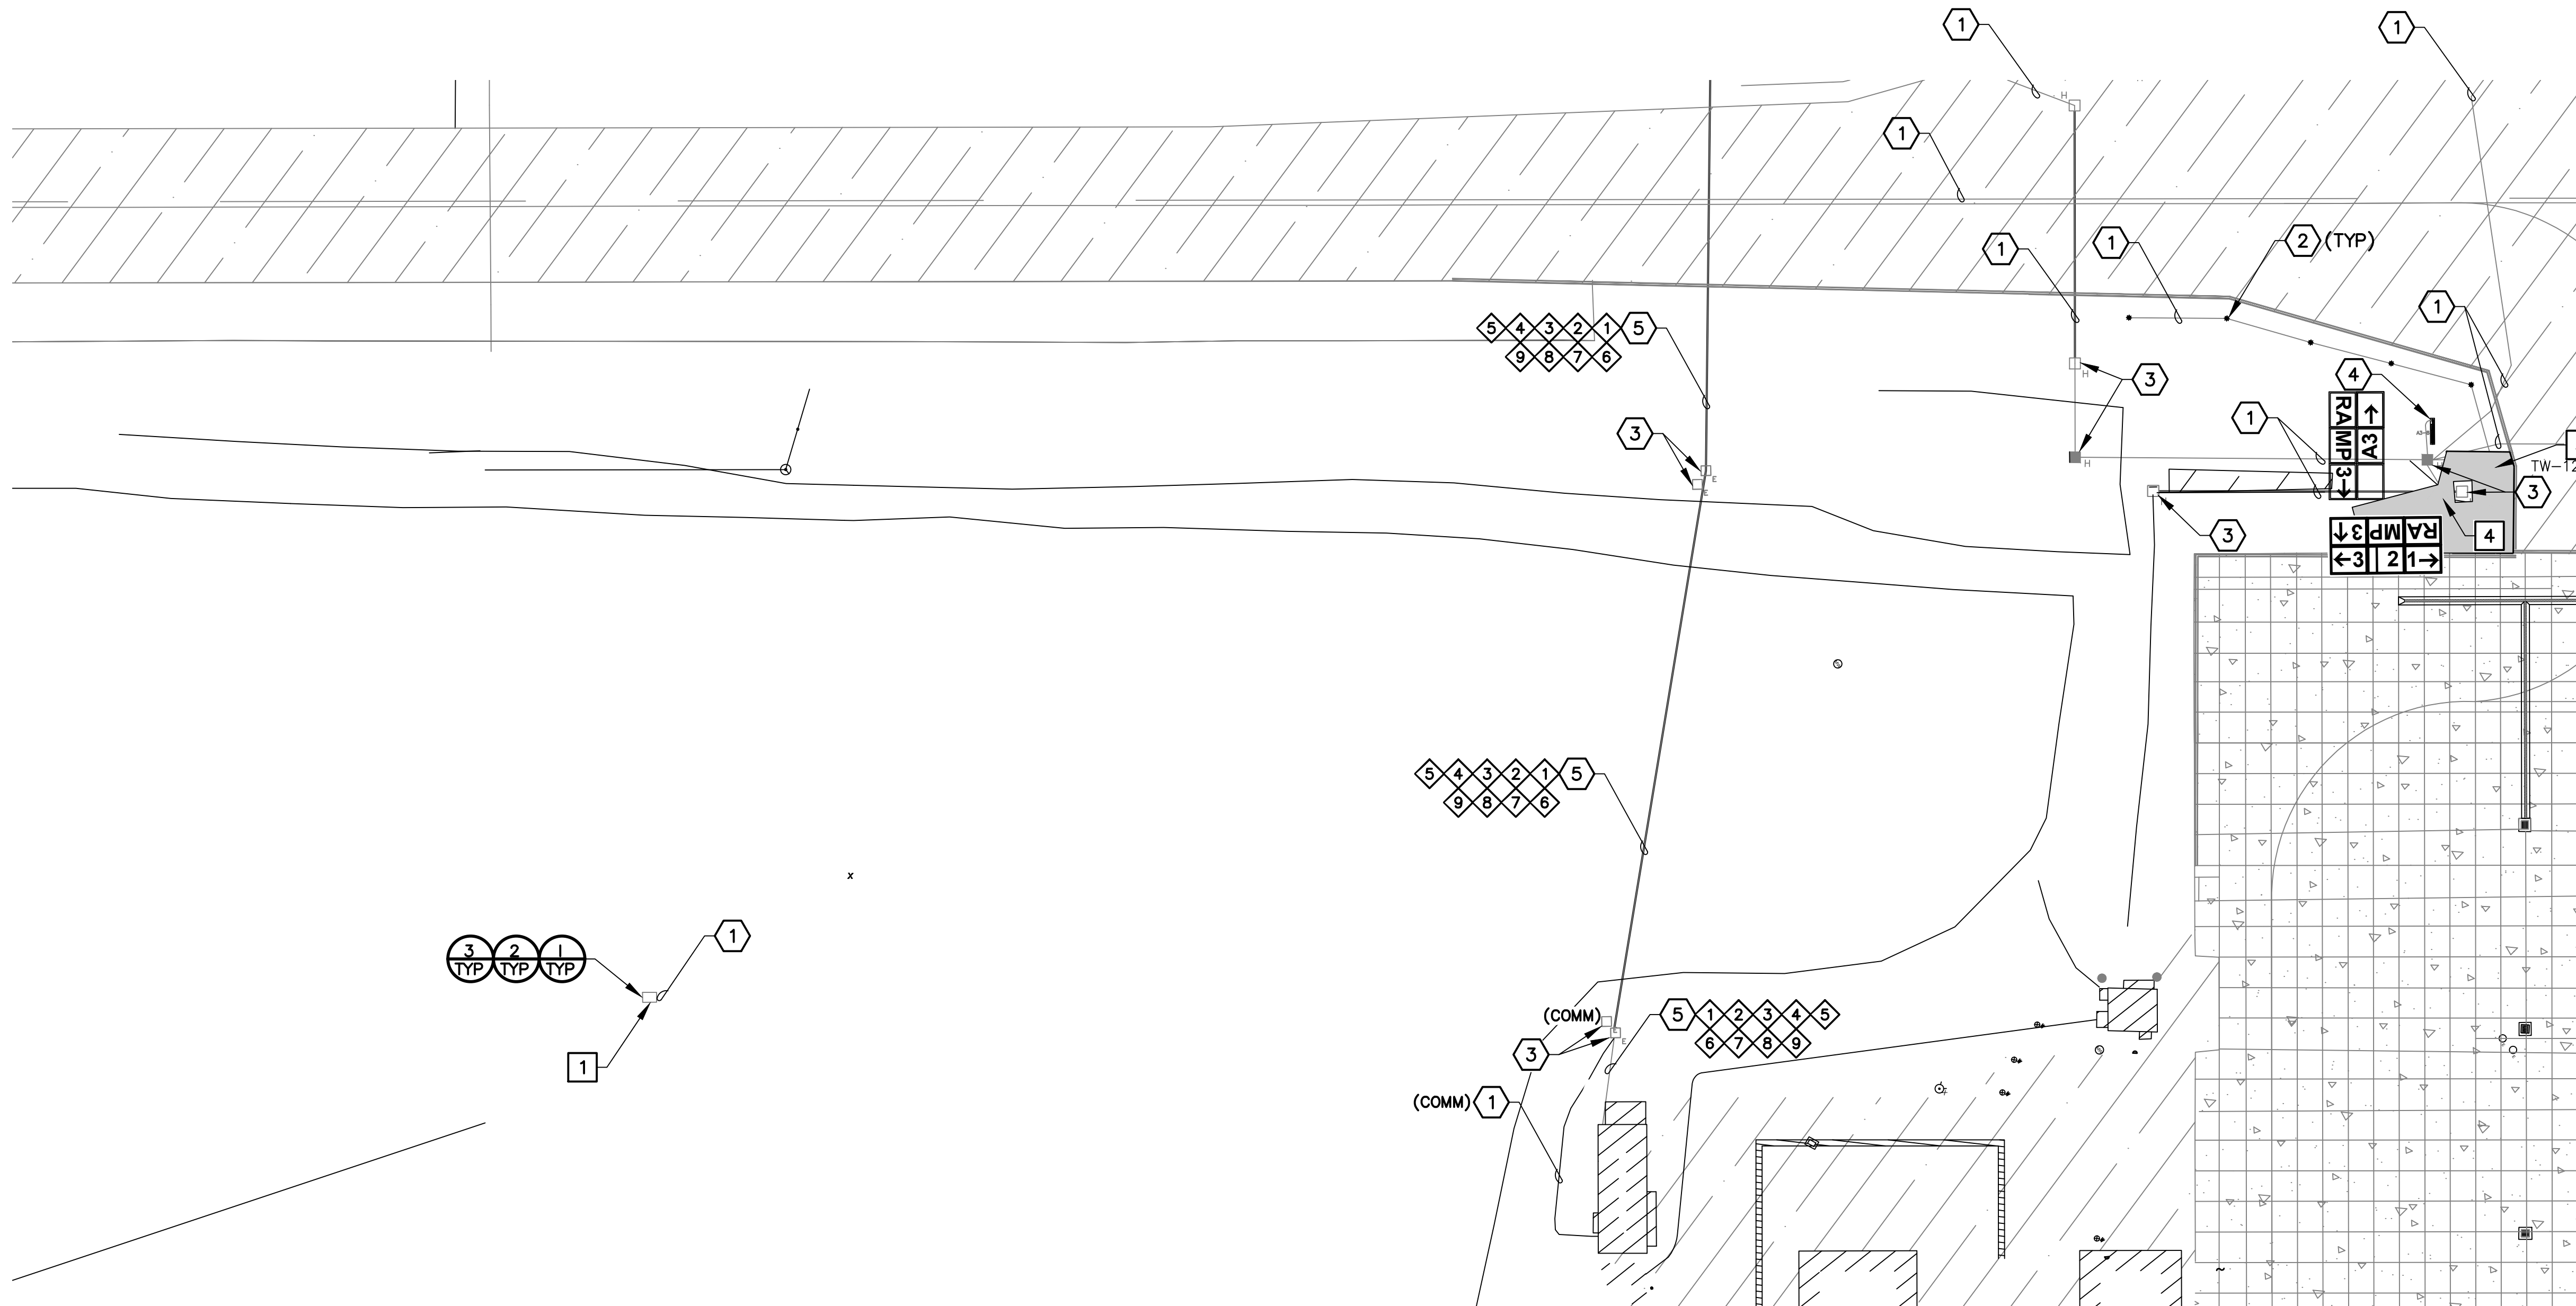

1
TYP
EXISTING SWS EQUIPMENT
FACING NORTH WEST




2
TYP
EXISTING SWS EQUIPMENT
FACING NORTH EAST

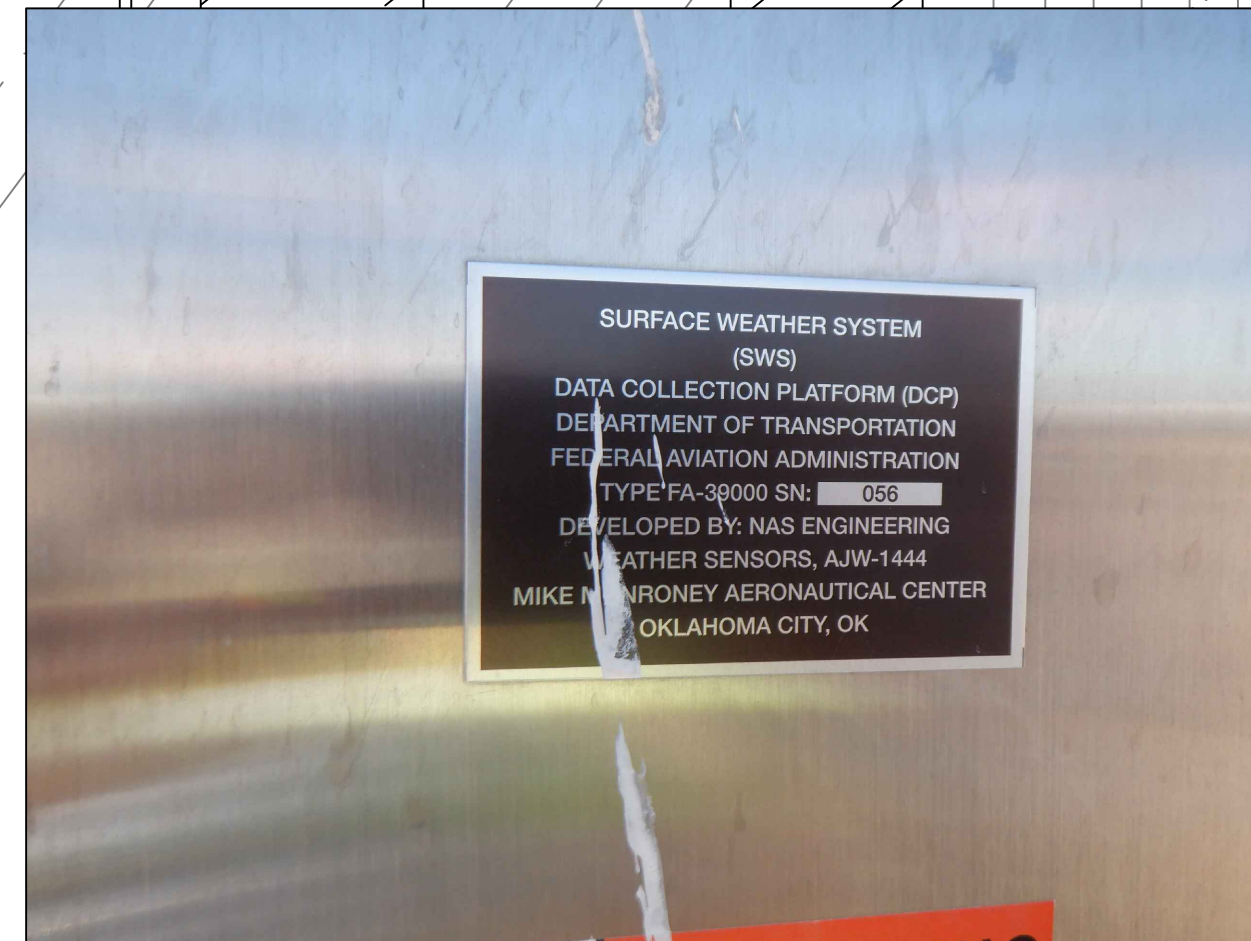

3
TYP
EXISTING SWS NAMEPLATE

0 50' 100'
SCALE: 1"=50'

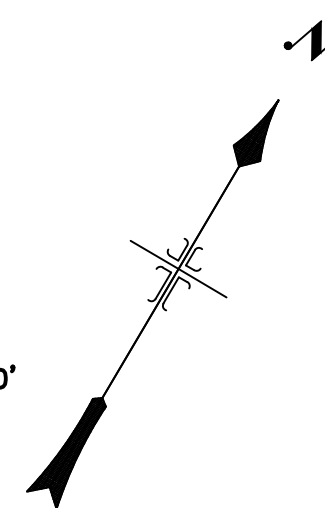

PER CITY OF PHOENIX CODE CHAPTER 2, SECTION 2-28. THESE PLANS ARE FOR OFFICIAL USE ONLY AND MAY NOT BE SHARED WITH OTHERS EXCEPT AS REQUIRED TO FULFILL THE OBLIGATIONS OF CONTRACTOR'S CONTRACT WITH THE CITY OF PHOENIX.

- REMOVAL NOTES

1

REMOVE AND SALVAGE EXISTING FAA SWS EQUIPMENT FOR RECONNECTION. DEMOLISH 4' THICK CONCRETE FOUNDATION. REMOVE CABLE BACK TO SWS SHELTER PANEL. SCHEDULED OUTAGES OF SWS SYSTEM MUST BE COORDINATED THRU AIRPORT AND FAA. (1 LUMP SUM)

3

REMOVE AND SALVAGE EXISTING ELEVATED EDGE LIGHT FOR RE-INSTALLATION. INSTALL NEW BLANK COVER AND GASKET ON EXISTING L-867 BASE CAN. (1 TOTAL)

4

REMOVE, TEMPORARILY MOUNT AND POWER AIRFIELD GUIDANCE SIGN AND ISOLATION TRANSFORMER. DEMO BASE CAN. (1 TOTAL)
- REFERENCE NOTES

1

EXISTING CONDUIT AND CONDUCTOR TO REMAIN FOR RECONNECTION - PROTECT IN PLACE.

2

EXISTING TAXIWAY EDGE LIGHT AND ISOLATION TRANSFORMER TO REMAIN - PROTECT IN PLACE.

3

EXISTING HANDHOLE TO REMAIN - PROTECT IN PLACE

4

EXISTING AIRFIELD GUIDANCE SIGN TO REMAIN - PROTECT IN PLACE.

5

EXISTING 24-2" AIRFIELD LIGHTING DUCTBANK AND CABLES TO REMAIN - PROTECT IN PLACE.

- CIRCUIT IDENTIFICATION

(5 KV)

1

RW 3-21

2

RGL

3

SIGNS (SG)

4

TWA NORTH (TAN)

5

TWA SOUTH (TAS)

(480V NAVAIDS)

6

NORTH PAPI (21)

7

NORTH REIL (21)

8

SOUTH PAPI (3)

9

SOUTH REIL (3)

CS COMPANIES

CERTIFICATE OF AUTHORITY
STATE OF ARIZONA
38686
CATHERINE M. ALCON
ELECTRICAL ENGINEER
EXPIRATION DATE: 12/31/2024

PER CITY OF PHOENIX CITY CODE CHAPTER 2, SECTION 2-28, THESE PLANS ARE FOR OFFICIAL USE ONLY AND MAY NOT BE SHARED WITH OTHERS EXCEPT AS REQUIRED TO FULFILL THE OBLIGATIONS OF YOUR CONTRACT WITH THE CITY OF PHOENIX.

NO.	REVISIONS / SUBMISSIONS	DATE

PHX DVT CYR
CITY OF PHOENIX AVIATION DEPARTMENT
PHOENIX GOODYEAR AIRPORT
NEW APRON AND TAXIWAY CONNECTOR
AV41000077 FAA/ADOT

Designed by: SW
Drawn by: JBW
Checked by: CA
Date: May 2022
Dwg scale:

SHEET OVERVIEW TITLE
AIRFIELD ELECTRICAL
DEMOLITION SITE PLAN
ED-101

SHEET REFERENCE
NUMBER:
ED-101

Sheet 46 of 61



1
TYP SWS EQUIPMENT



2
TYP SWS EQUIPMENT





3
TYP SWS COMMUNICATIONS BOX




4
TYP OVERALL SWS



5
TYP SWS EQUIPMENT

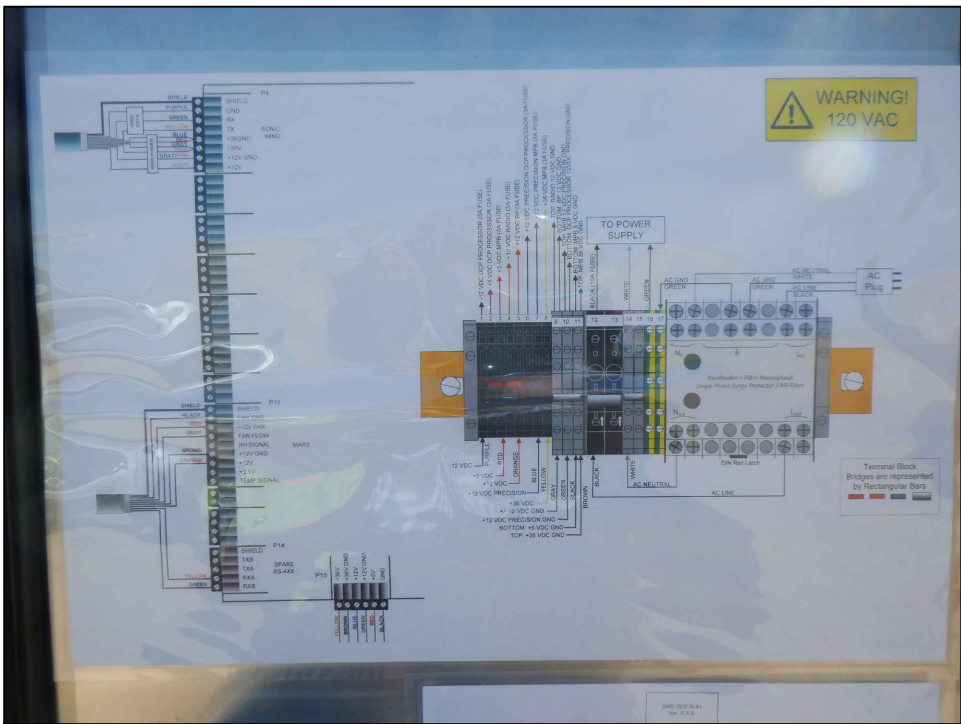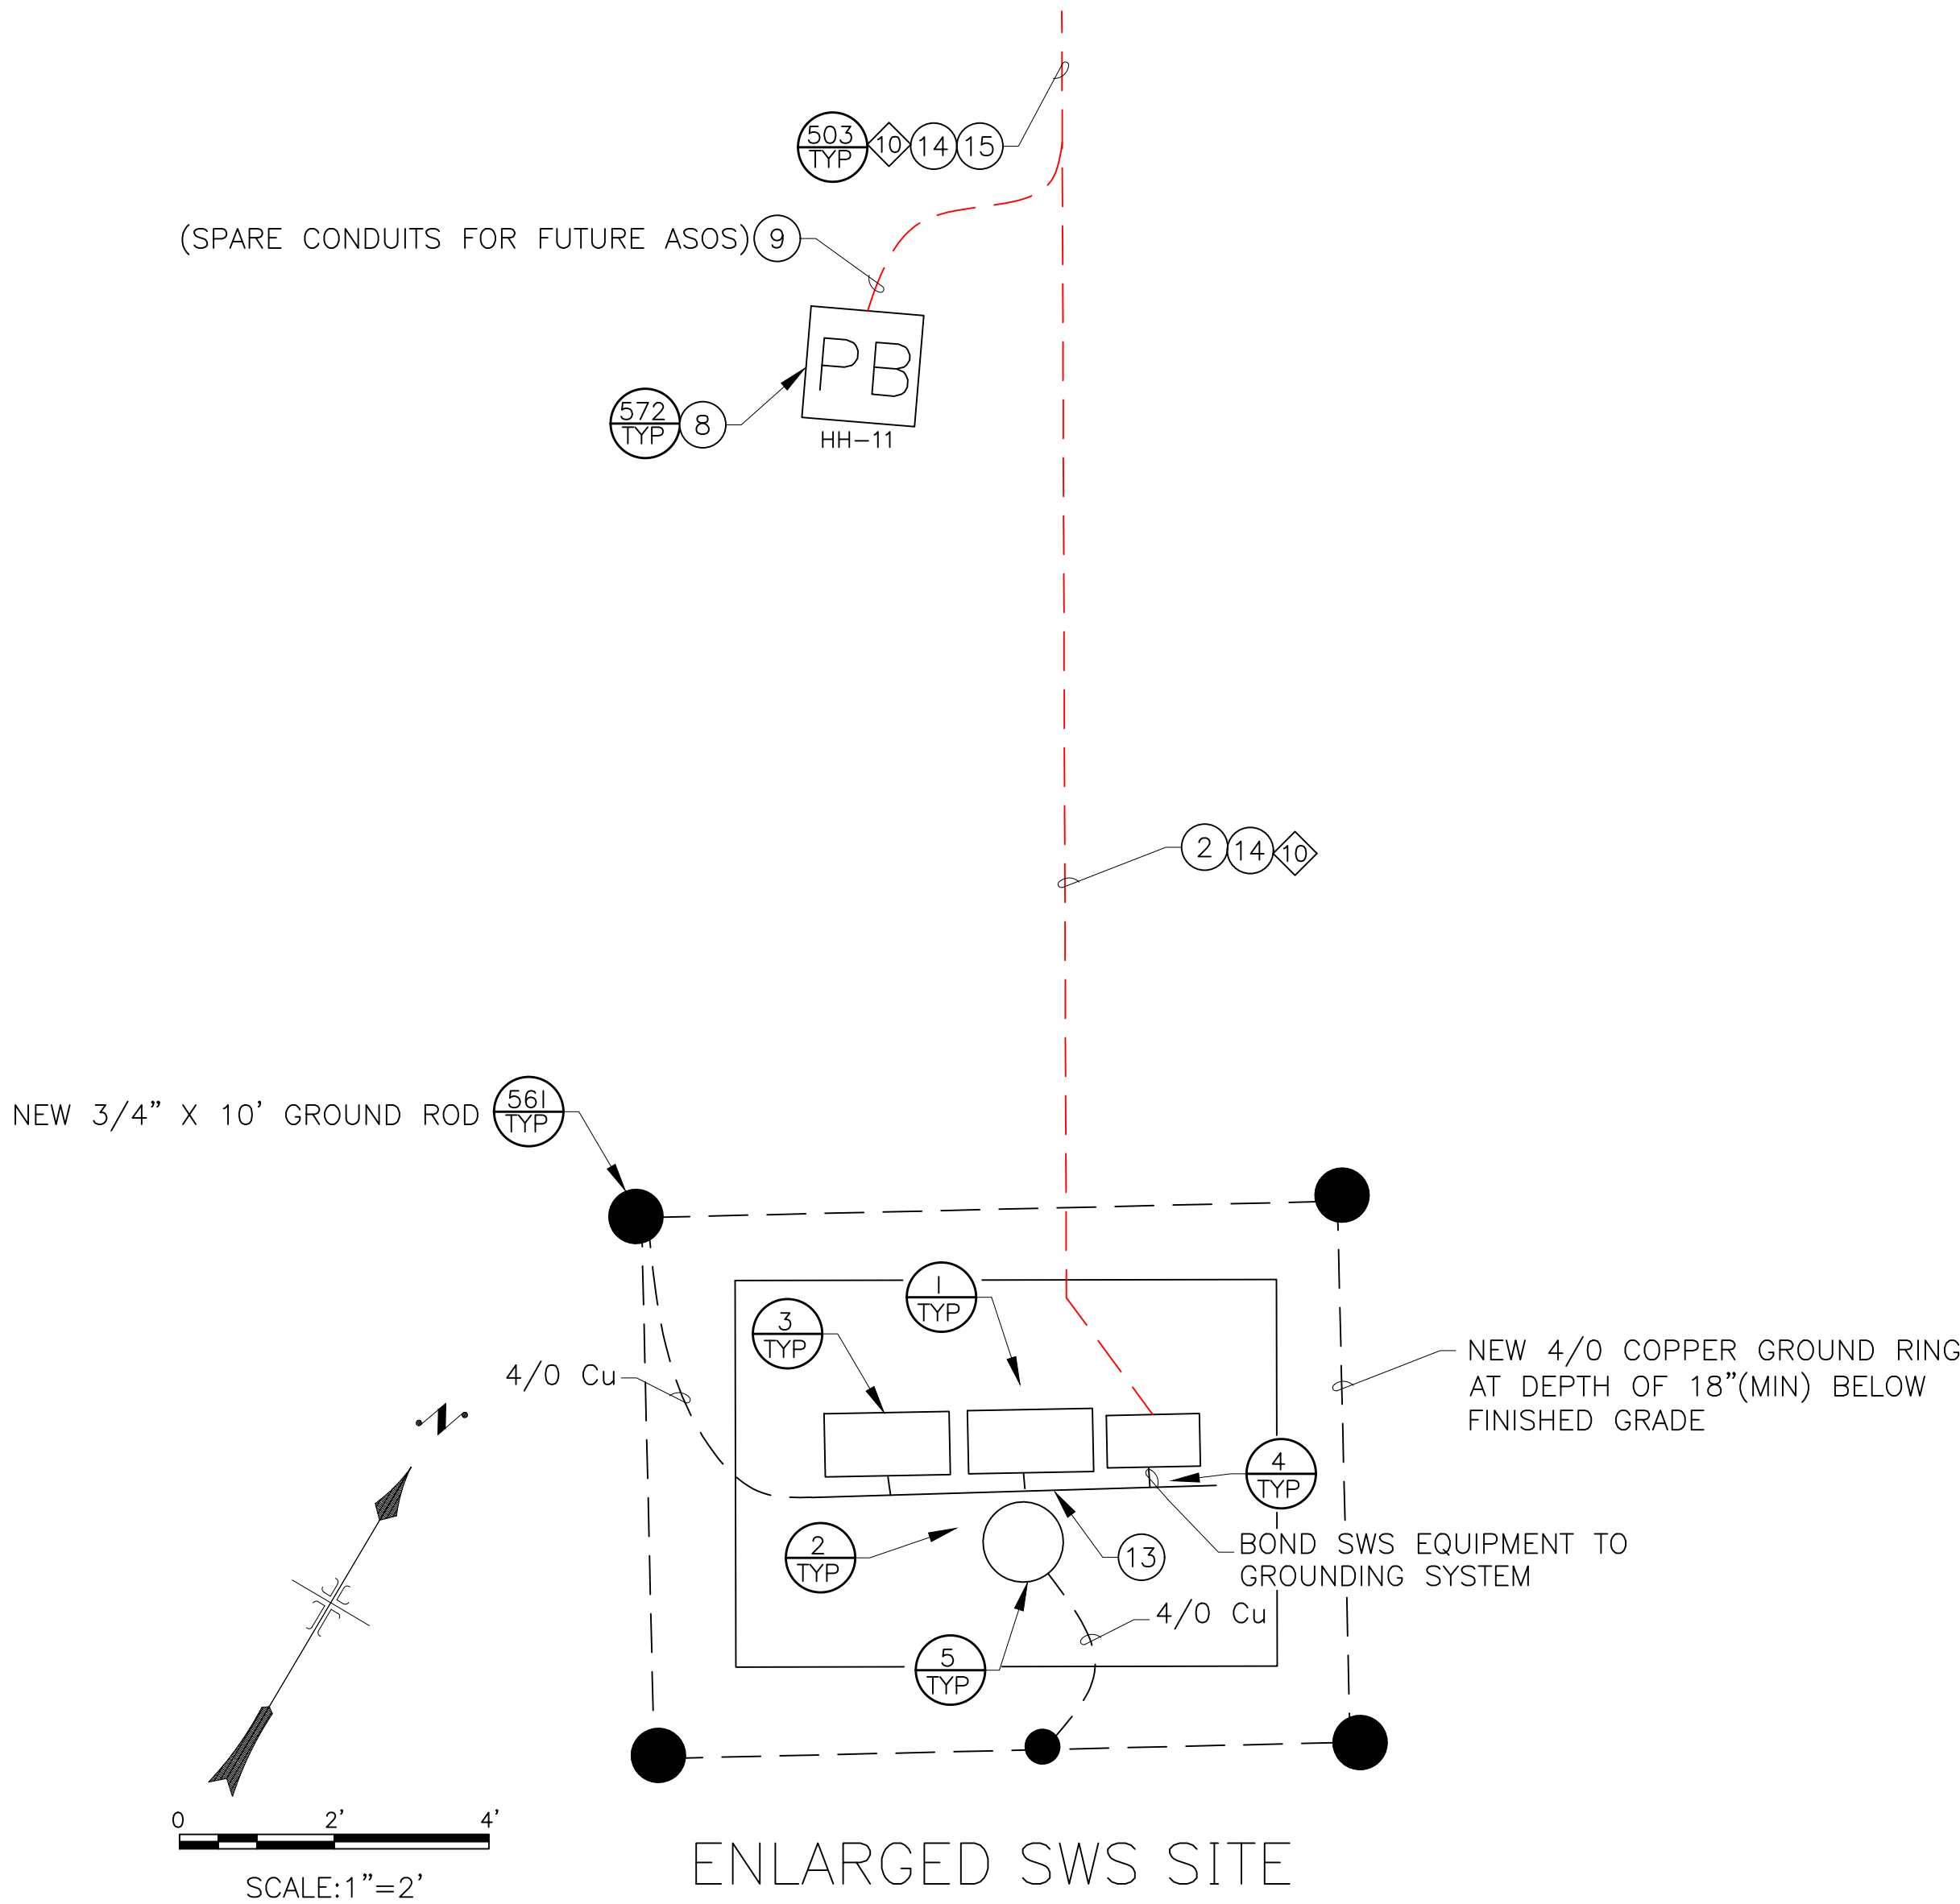

7
TYP SWS EQUIPMENT

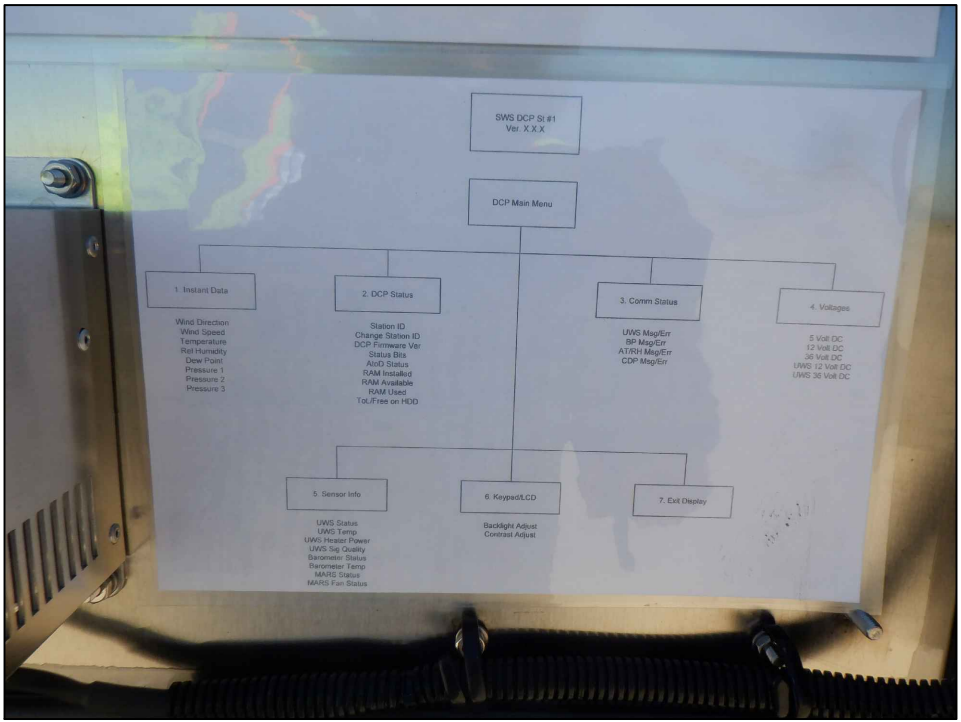

6
TYP SWS EQUIPMENT

NOTE:
CONTRACTOR SHALL RELOCATE EXISTING SWS EQUIPMENT AND REINSTALL ON NEW 4' THICK CONCRETE FOUNDATION TO MATCH EXISTING SWS CONFIGURATION AND CONNECTIONS. PROVIDE GROUNDING AND BONDING OF SWS EQUIPMENT AS REQUIRED BY FAA.


PER CITY OF PHOENIX CODE CHAPTER 2, SECTION 2-28. THESE PLANS ARE FOR OFFICIAL USE ONLY AND MAY NOT BE SHARED WITH OTHERS EXCEPT AS REQUIRED TO FULFILL THE OBLIGATIONS OF CONTRACTOR'S CONTRACT WITH THE CITY OF PHOENIX.

○ CONSTRUCTION NOTES ○	
② 1-2"C SE	(15 LF)
⑧ NEW SIZE 5 JUNCTION BOX FOR TERMINATING FUTURE ASOS AND SPARE CONDUITS	(1 TOTAL)
⑨ 4-2"C SE	(15 LF)
⑬ INSTALL SALVAGED FAA SWS EQUIPMENT ON NEW 4' THICK CONCRETE FOUNDATION WITH GROUNDING AND BONDING AS REQUIRED BY FAA. EXISTING ANTENNA SHALL BE MOUNTED AT HIGHER LOCATION ON TOWER TO BE DETERMINED BY FAA.	(1 LUMP SUM)
⑭ 3 - 4/0, 4/0 GND	(60 LF)
⑮ 5-2"C SE	(5 LF)
◇ REFERENCE NOTES ◇	
◇ CIRCUIT IDENTIFICATION ◇	
⑩ CKT SWS-9,11	

16719 East Palisades Blvd., Suite 202
Fountain Hills, AZ 85208
Phone: (480) 816-5541
Fax: (480) 816-5540

DESIGNED BY: SW	PHX DVT LVR CITY OF PHOENIX AVIATION DEPARTMENT PHOENIX GOODYEAR AIRPORT NEW APRON AND TAXIWAY CONNECTOR AV41000077 FAA/ADOT
DRAWN BY: JBW	
CHECKED BY: CA	
DATE: May 2022	
DWG. SCALE:	
CIP NO.(S): AV41000077 FAA/ADOT	

SHEET OVERVIEW TITLE	AIRFIELD ELECTRICAL INSTALLATION SITE PLAN
SHEET REFERENCE NUMBER:	EA-101
SHEET 47 OF 61	

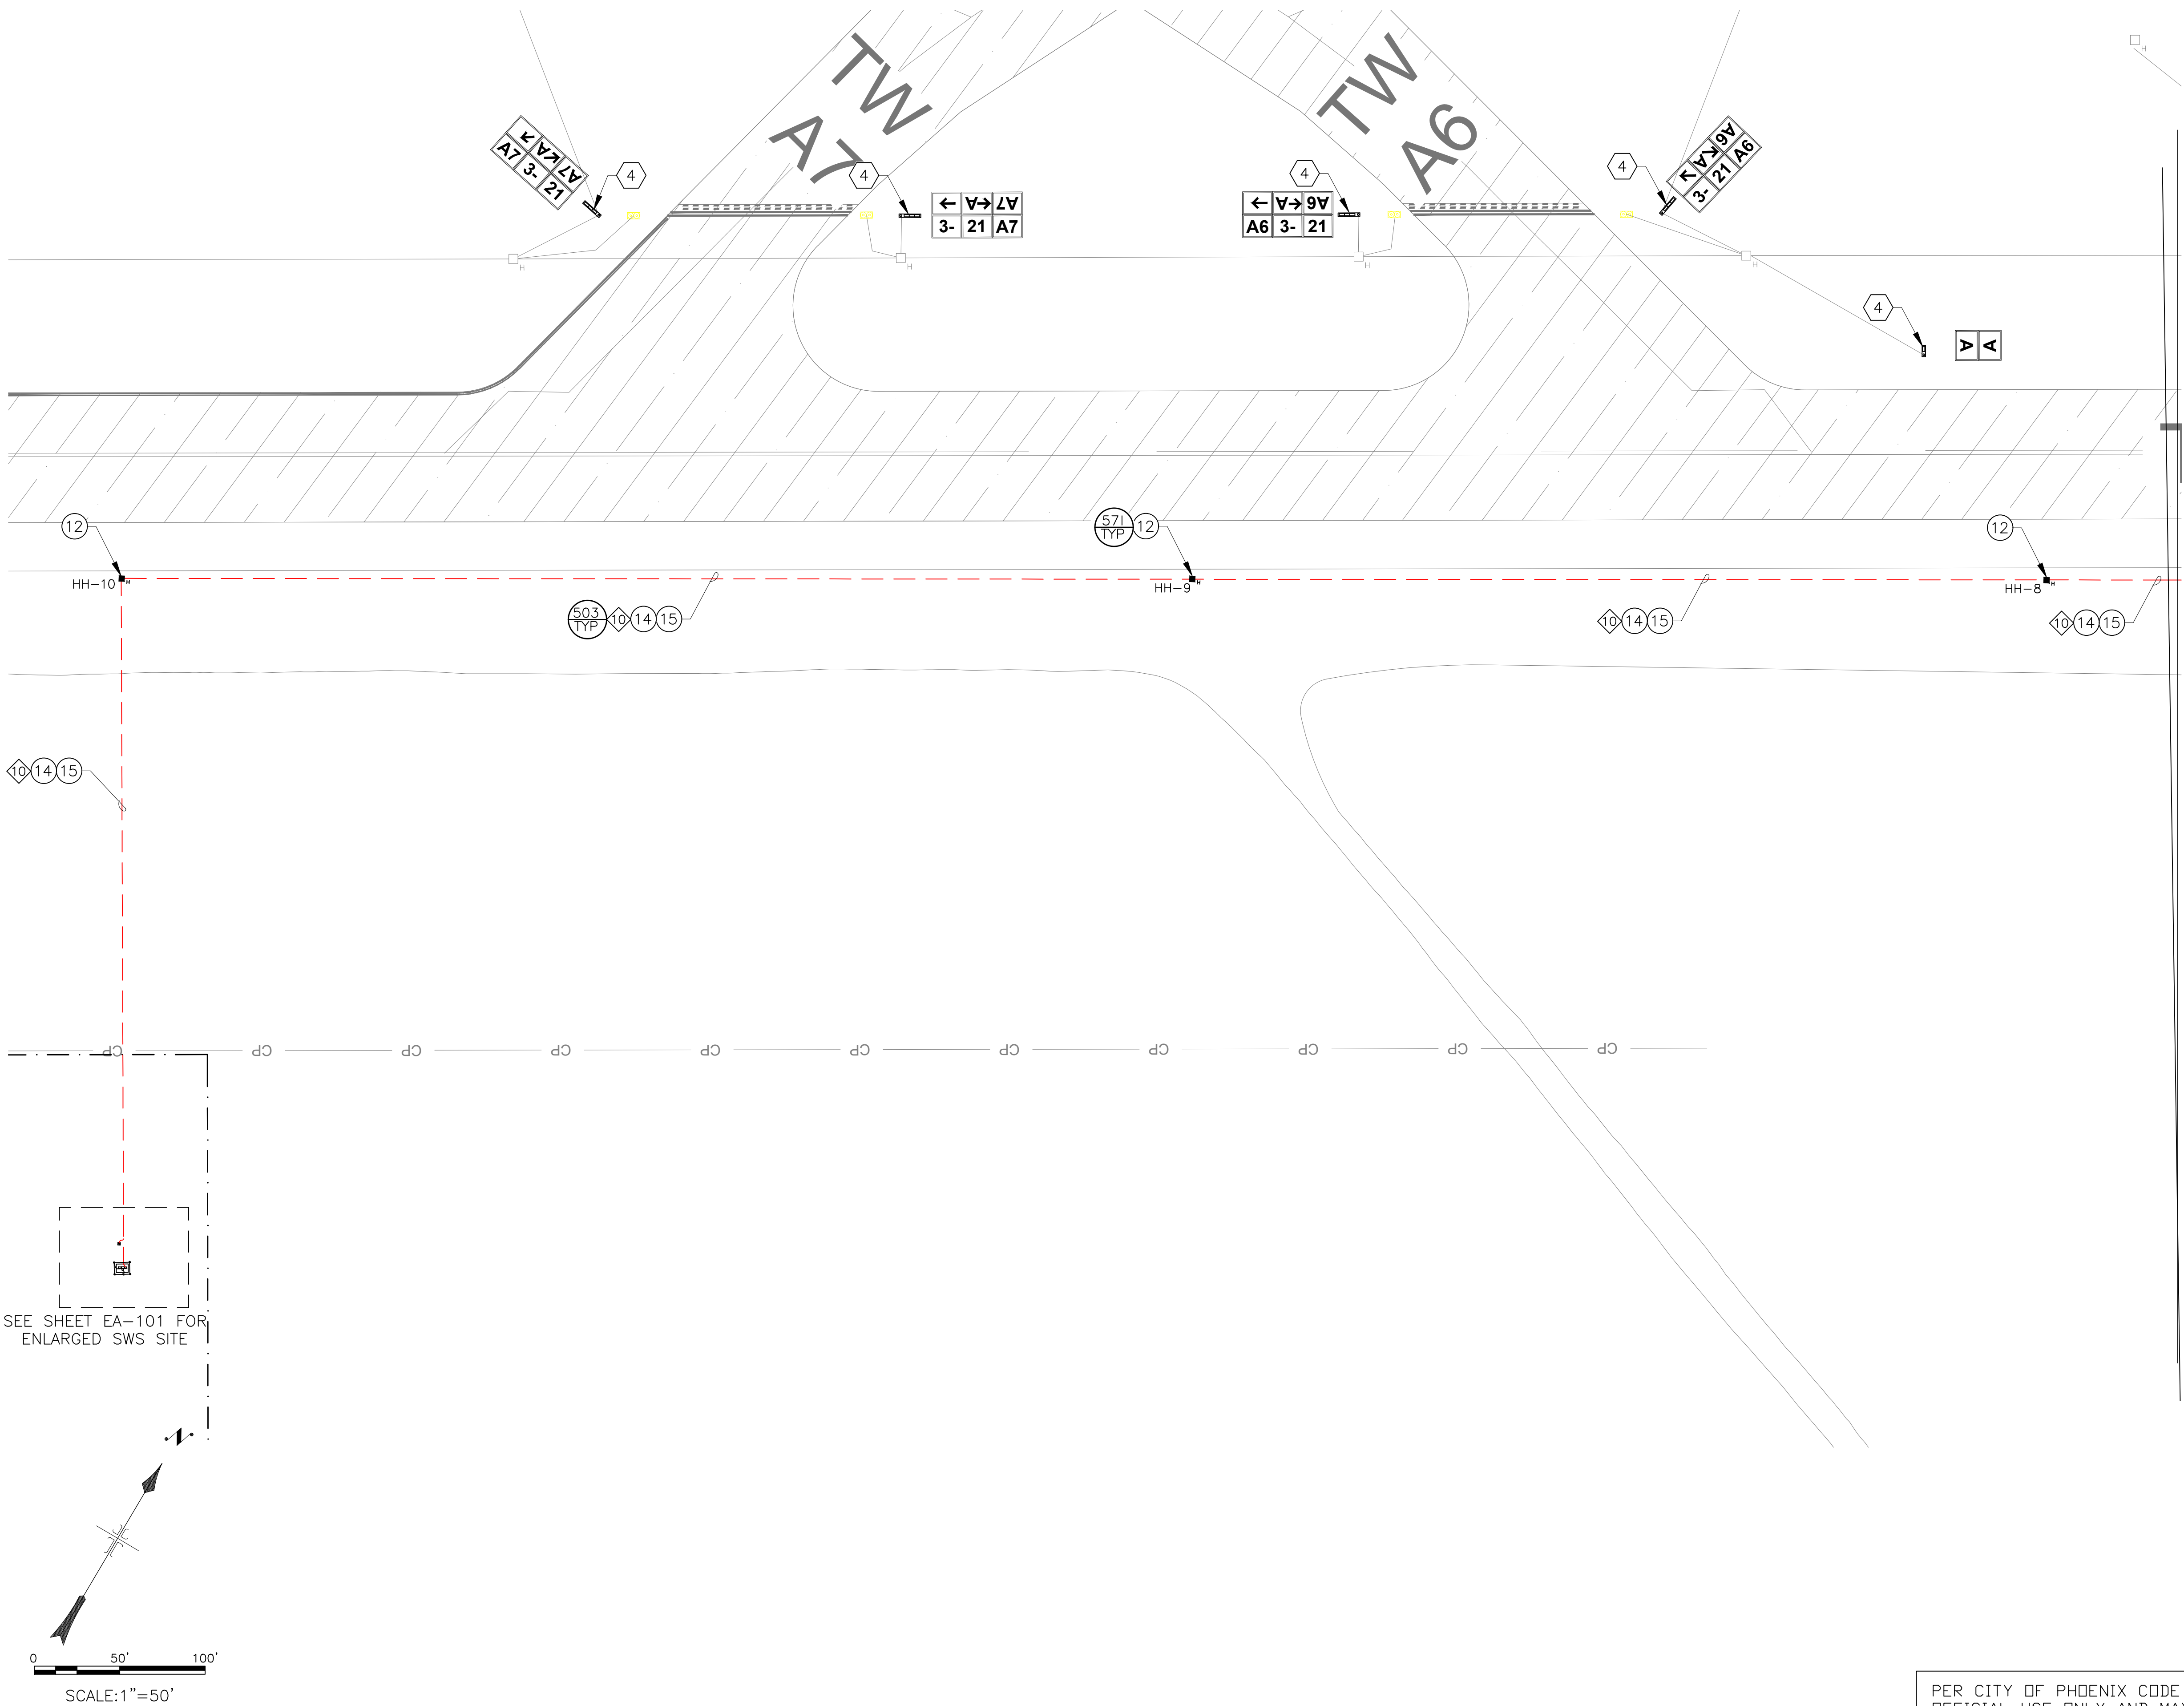

SEE SHEET EA-101 FOR
ENLARGED SWS SITE

MATCHLINE – SEE SHEET EA-103



PER CITY OF PHOENIX CODE CHAPTER 2, SECTION 2-28. THESE PLANS ARE FOR OFFICIAL USE ONLY AND MAY NOT BE SHARED WITH OTHERS EXCEPT AS REQUIRED TO FULFILL THE OBLIGATIONS OF CONTRACTOR'S CONTRACT WITH THE CITY OF PHOENIX.

CONSTRUCTION NOTES



- 12 NEW 2' X 2' X 3' HANDHOLE, TYPE 1, AIRCRAFT RATED. (3 TOTAL)
- 14 3 - 4/0, 4/0 GND (1650 LF)
- 15 5-2"C SE (1595 LF)

REFERENCE NOTES

- 4 EXISTING AIRFIELD GUIDANCE SIGN

CIRCUIT IDENTIFICATION

- 10 CKT SWS-9,11

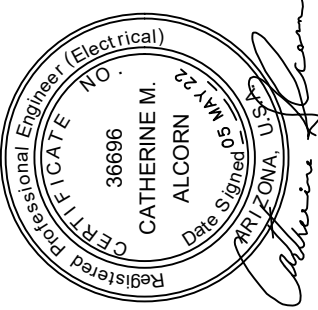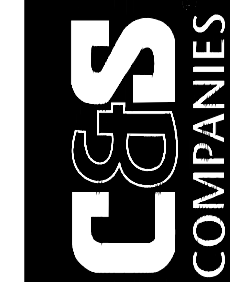

PER CITY OF PHOENIX CITY CODE CHAPTER 2, SECTION 2-28, THESE PLANS ARE FOR OFFICIAL USE ONLY AND MAY NOT BE SHARED WITH OTHERS EXCEPT AS REQUIRED TO FULFILL THE OBLIGATIONS OF YOUR CONTRACT WITH THE CITY OF PHOENIX.				NO.	REVISIONS / SUBMISSIONS	DATE

PHX DVT CYR
CITY OF PHOENIX AVIATION DEPARTMENT
PHOENIX GOODYEAR AIRPORT
NEW APRON AND TAXIWAY CONNECTOR
AV41000077 FAA/ADOT

Designed by: SW
Drawn by: JBW
Checked by: CA
Date: May 2022
Dwg. scale:

**AIRFIELD ELECTRICAL
INSTALLATION SITE PLAN**

Sheet
Reference
Number:


EA-102

MATCHLINE – SEE SHEET EA-102

TAXIWAY A

TW
A5

TW
A4

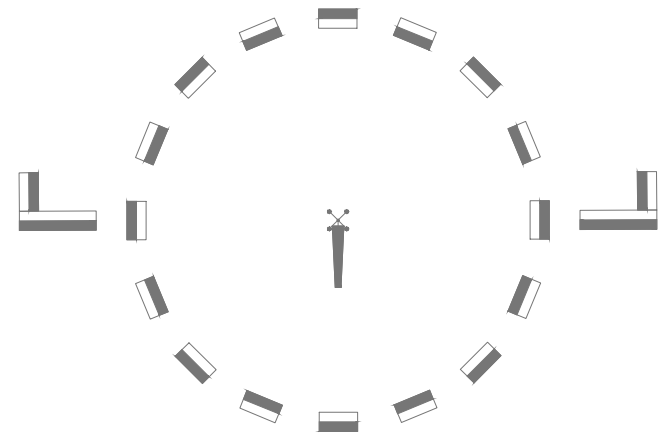

10 14 15

571
TYP

HH-7

503
TYP

10 14 15

12

HH-6

10 14 15

A5
3- 21
A5



A5
3- 21
A5

A4
3- 21
A4

A4
3- 21
A4

MATCHLINE – SEE SHEET EA-104

0 50' 100'
SCALE:1"=50'

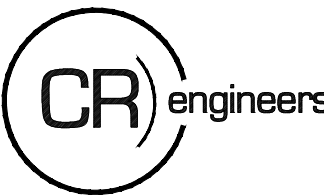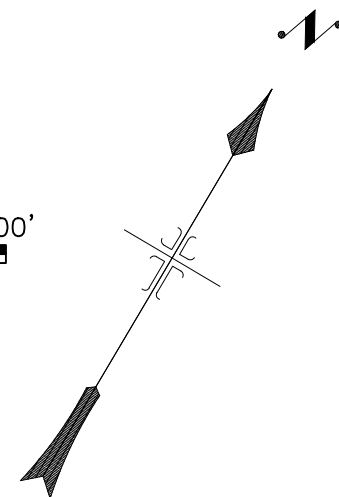

16719 East Palisades Blvd., Suite 202
Fountain Hills, AZ 85268
Phone: (480) 816-5541
Fax: (480) 816-5540

PER CITY OF PHOENIX CODE CHAPTER 2, SECTION 2-28. THESE PLANS ARE FOR OFFICIAL USE ONLY AND MAY NOT BE SHARED WITH OTHERS EXCEPT AS REQUIRED TO FULFILL THE OBLIGATIONS OF CONTRACTOR'S CONTRACT WITH THE CITY OF PHOENIX.

○ CONSTRUCTION NOTES ○



- 12 NEW 2' X 2' X 3' HANDHOLE, TYPE 1, AIRCRAFT RATED. (2 TOTAL)
- 14 3 - 4/0, 4/0 GND (1320 LF)
- 15 5-2"C SE (1280 LF)

○ REFERENCE NOTES ○

- 4 EXISTING AIRFIELD GUIDANCE SIGN

◇ CIRCUIT IDENTIFICATION ◇

- 10 CKT SWS-9,11

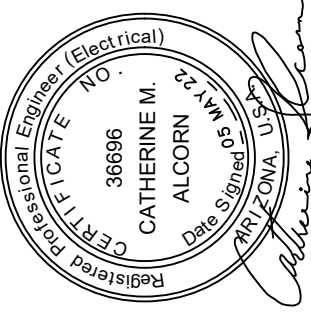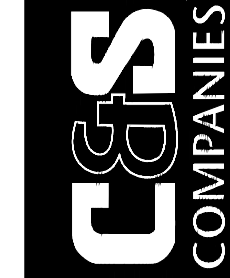

PER CITY OF PHOENIX CITY CODE CHAPTER 2, SECTION 2-28, THESE PLANS ARE FOR OFFICIAL USE ONLY AND MAY NOT BE SHARED WITH OTHERS EXCEPT AS REQUIRED TO FULFILL THE OBLIGATIONS OF YOUR CONTRACT WITH THE CITY OF PHOENIX.

PHX DVT CYR
CITY OF PHOENIX AVIATION DEPARTMENT

PHOENIX GOODYEAR AIRPORT
NEW APRON AND TAXIWAY CONNECTOR

AV41000077 FAA/ADOT

Designed by: SW
Drawn by: JBW
Checked by: CA
Date: May 2022
Dwg. scale:

Sheet Overview Title


AIRFIELD ELECTRICAL
INSTALLATION SITE PLAN

Sheet
Reference
Number:

EA-103

Sheet 49 of 61

MATCHLINE — SEE SHEET EA-103

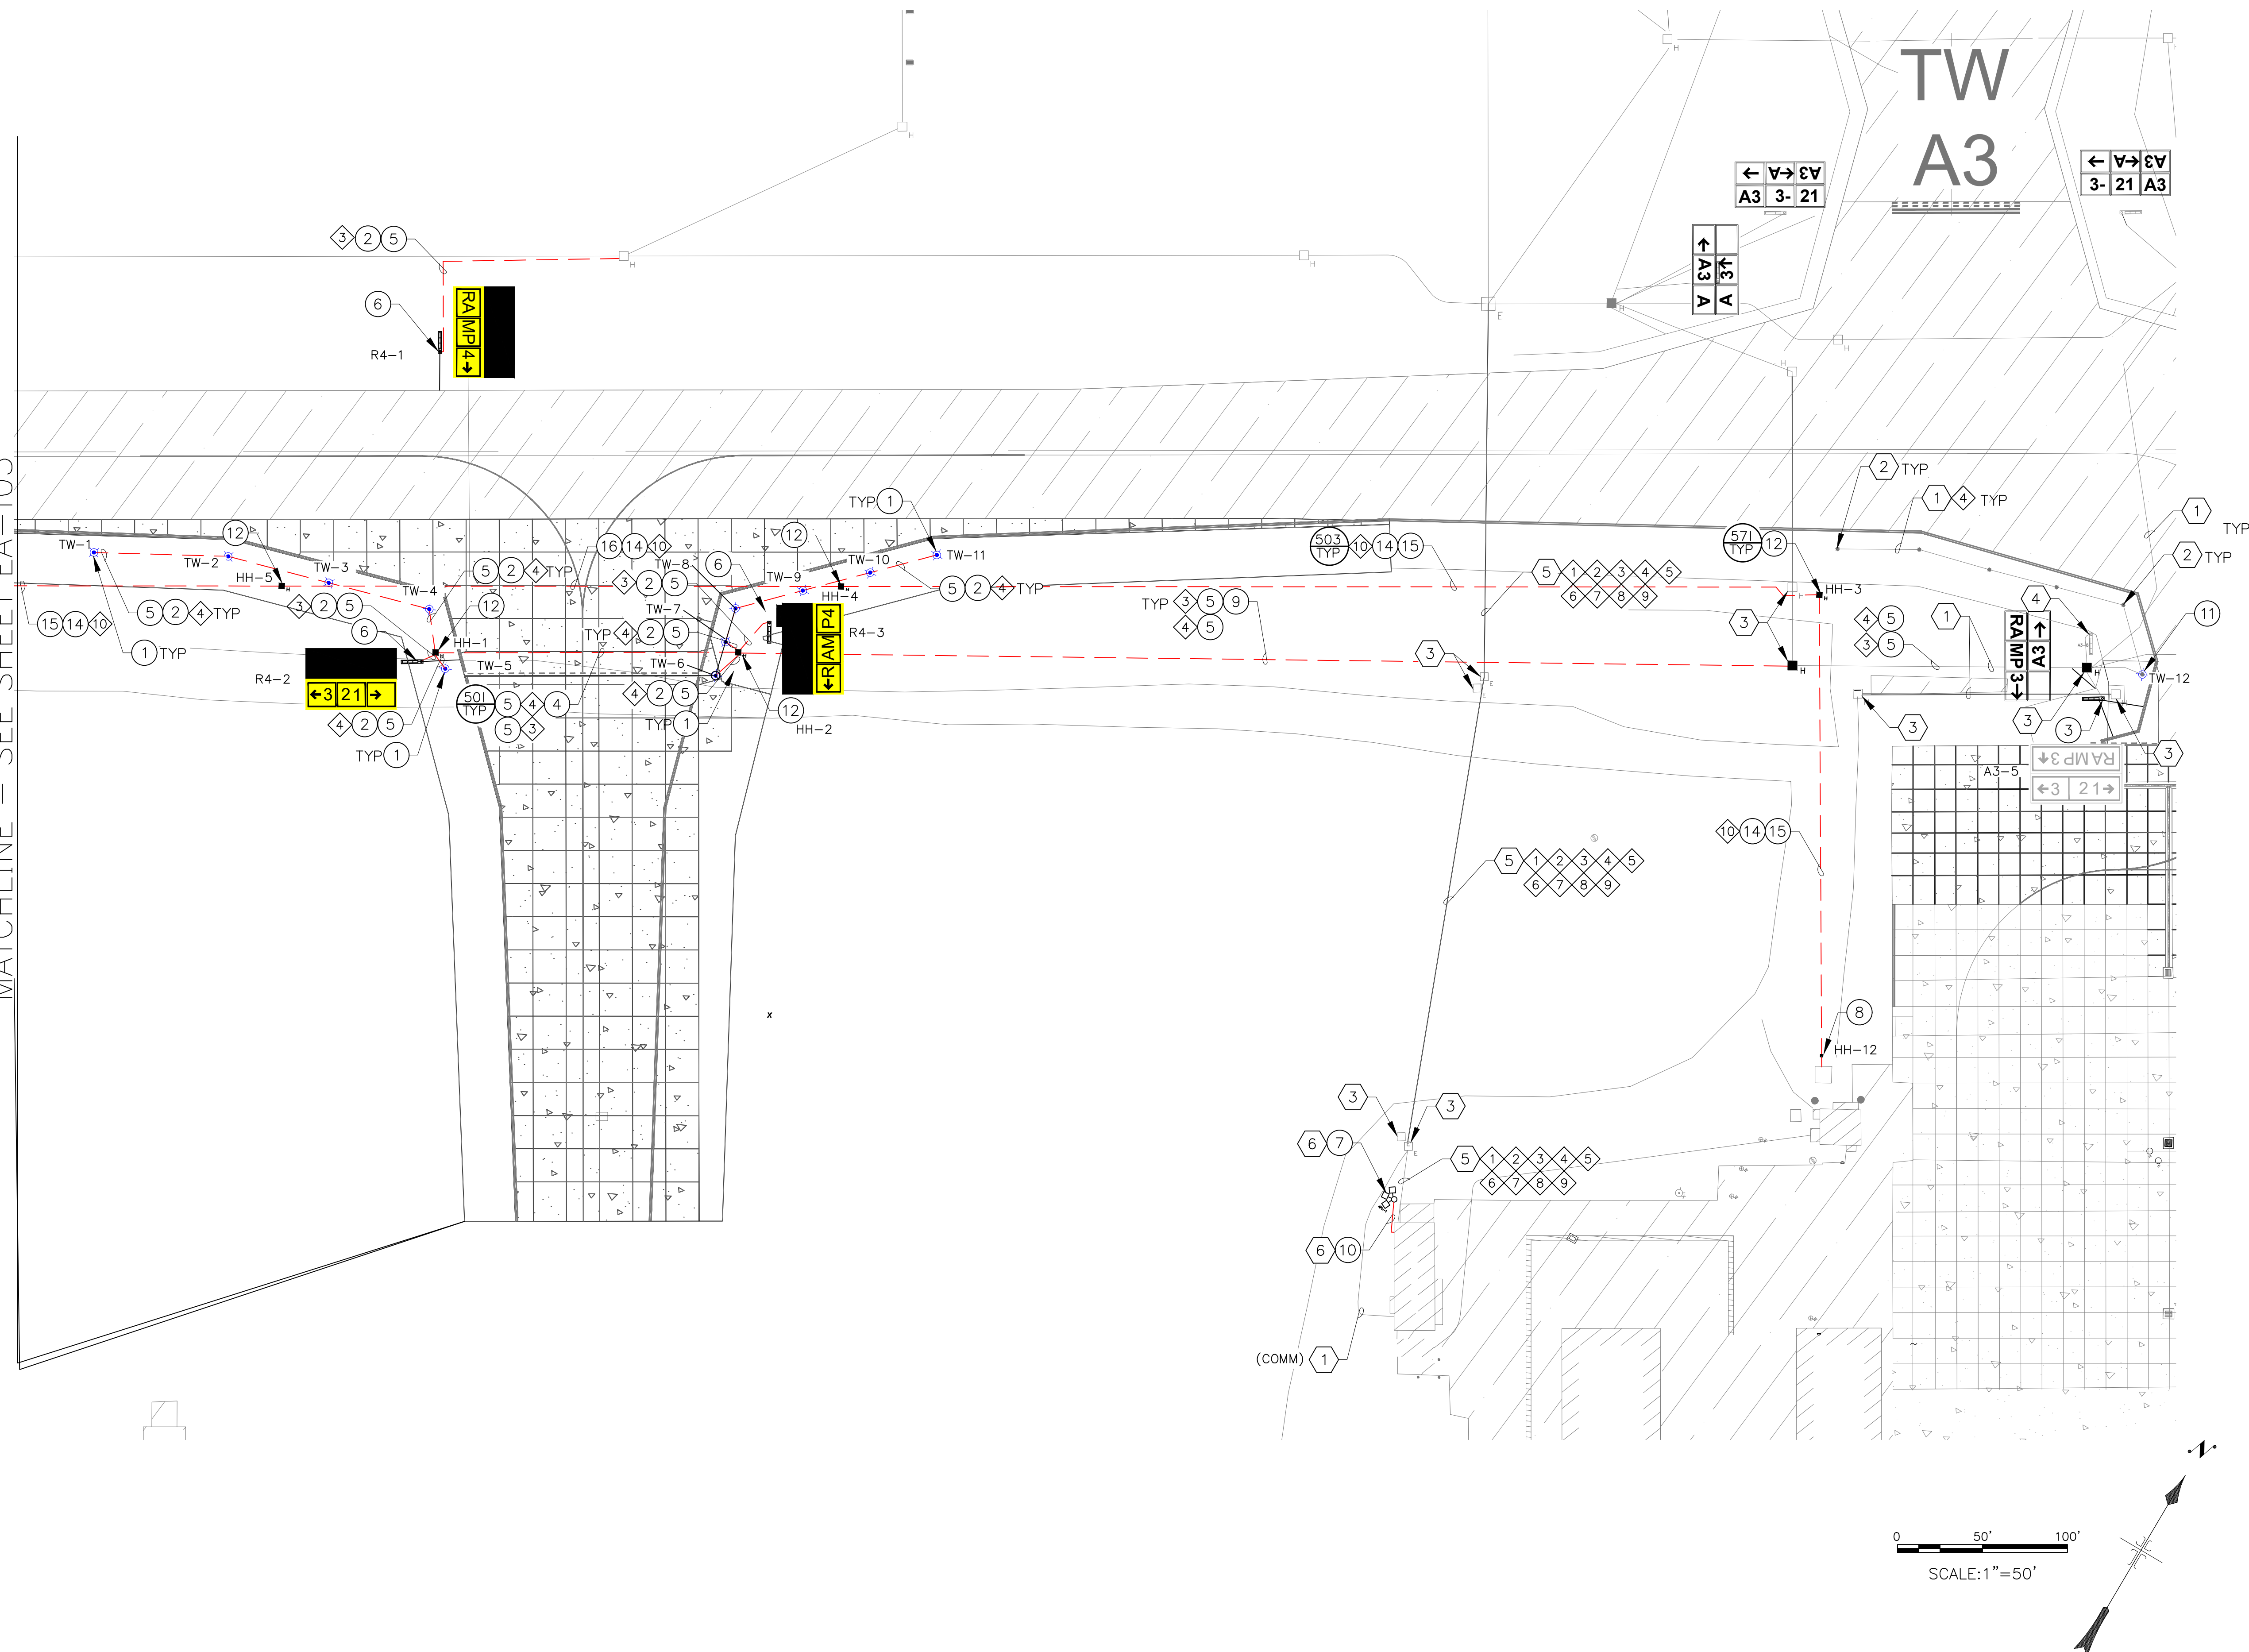

0 50' 100'
SCALE: 1"=50'

CONSTRUCTION NOTES

1

INSTALL NEW ELEVATED LED L-861T(L) TAXIWAY EDGE LIGHT AND ISOLATION TRANSFORMER ON NEW L-867 BASE CAN.
(11 TOTAL)

2

1-2"C SE
(665 LF)

3

INSTALL SALVAGED 3 MODULE AIRFIELD GUIDANCE SIGN ON NEW SIGN BASE.
(1 TOTAL)

4

4-2"C CE
(205 LF)

5

NEW 2/C, #8 5KV L-824, TYPE "C" AIRFIELD LIGHTING CABLE.
(2880 LF)

6

NEW L-858(L) LED SIZE 2, 3 MODULE AIRFIELD GUIDANCE SIGN AND ISOLATION TRANSFORMER ON NEW SIGN BASE.
(3 TOTAL)

7

NEW 70' APRON LIGHTING POLE WITH 3-900W FIXTURES AND OBSTRUCTION LIGHT ON CONCRETE FOUNDATION. BID ALT #1
(1 TOTAL)

8

NEW SIZE 5 JUNCTION BOX FOR TERMINATING FUTURE ASOS AND SPARE CONDUITS
(1 TOTAL)

9

4-2"C SE
(645 LF)

10

2-#10, #10 NEUTRAL, #10 GND, 1"C (CKT A-40,42 - APRON LIGHT) BID ALT #1
(50 LF)

11

REMOVE BASE CAN PLATE AND INSTALL SALVAGED ELEVATED TAXIWAY EDGE LIGHT ON EXISTING BASE CAN.
(1 TOTAL)

12

NEW 2' X 2' X 3' HANDHOLE, TYPE 1, AIRCRAFT RATED.
(5 TOTAL)

14

3 - 4/0, 4/0 GND
(1142 LF)

15

5-2"C SE
(1055 LF)

16

5-2"C CE
(325 LF)

REFERENCE NOTES

1

EXISTING CONDUIT AND CONDUCTOR

2

EXISTING TAXIWAY EDGE LIGHT AND ISOLATION TRANSFORMER

3

EXISTING HANDHOLE

4

EXISTING AIRFIELD GUIDANCE SIGN

5

EXISTING 24-2" AIRFIELD LIGHTING DUCTBANK AND CABLES TO REMAIN - PROTECT IN PLACE.

6

BID ALT #1

CIRCUIT IDENTIFICATION

(5 KV)

1

RW 3-21

2

RGL

3

SIGNS (SG)

4

TWA NORTH (TAN)

5

TWA SOUTH (TAS)

(480V NAVAIDS)

6

NORTH PAPI (21)

7

NORTH REIL (21)

8

SOUTH PAPI (3)

9

SOUTH REIL (3)

10

CKT SWS - 9,11

CRengineers

16719 East Palisades Blvd., Suite 202
Fountain Hills, AZ 85268
Phone: (480) 816-5541
Fax: (480) 816-5540

CCS
COMPANIES

Professional Engineer (Electrical)
Catherine M. Alcorn
No. 38686
State of Arizona
Exp. 12/31/2024

PER CITY OF PHOENIX CITY CODE CHAPTER 2, SECTION 2-28, THESE PLANS ARE FOR OFFICIAL USE ONLY AND MAY NOT BE SHARED WITH OTHERS EXCEPT AS REQUIRED BY THE CITY OF PHOENIX CONTRACT WITH THE CITY OF PHOENIX.

NO.

REVISIONS / SUBMISSIONS

DATE

PHX DOT LVR
CITY OF PHOENIX AVIATION DEPARTMENT
PHOENIX GOODYEAR AIRPORT
NEW APRON AND TAXIWAY CONNECTOR

AV41000077 FAA/ADOT

Designed by: SW

Drawn by: JWB

Checked by: CA

Date: May 2022

Dwg. scale:


Sheet Overview Title

AIRFIELD ELECTRICAL
INSTALLATION SITE PLAN

Sheet
Reference
Number:

EA-104


Sheet 50 of 61

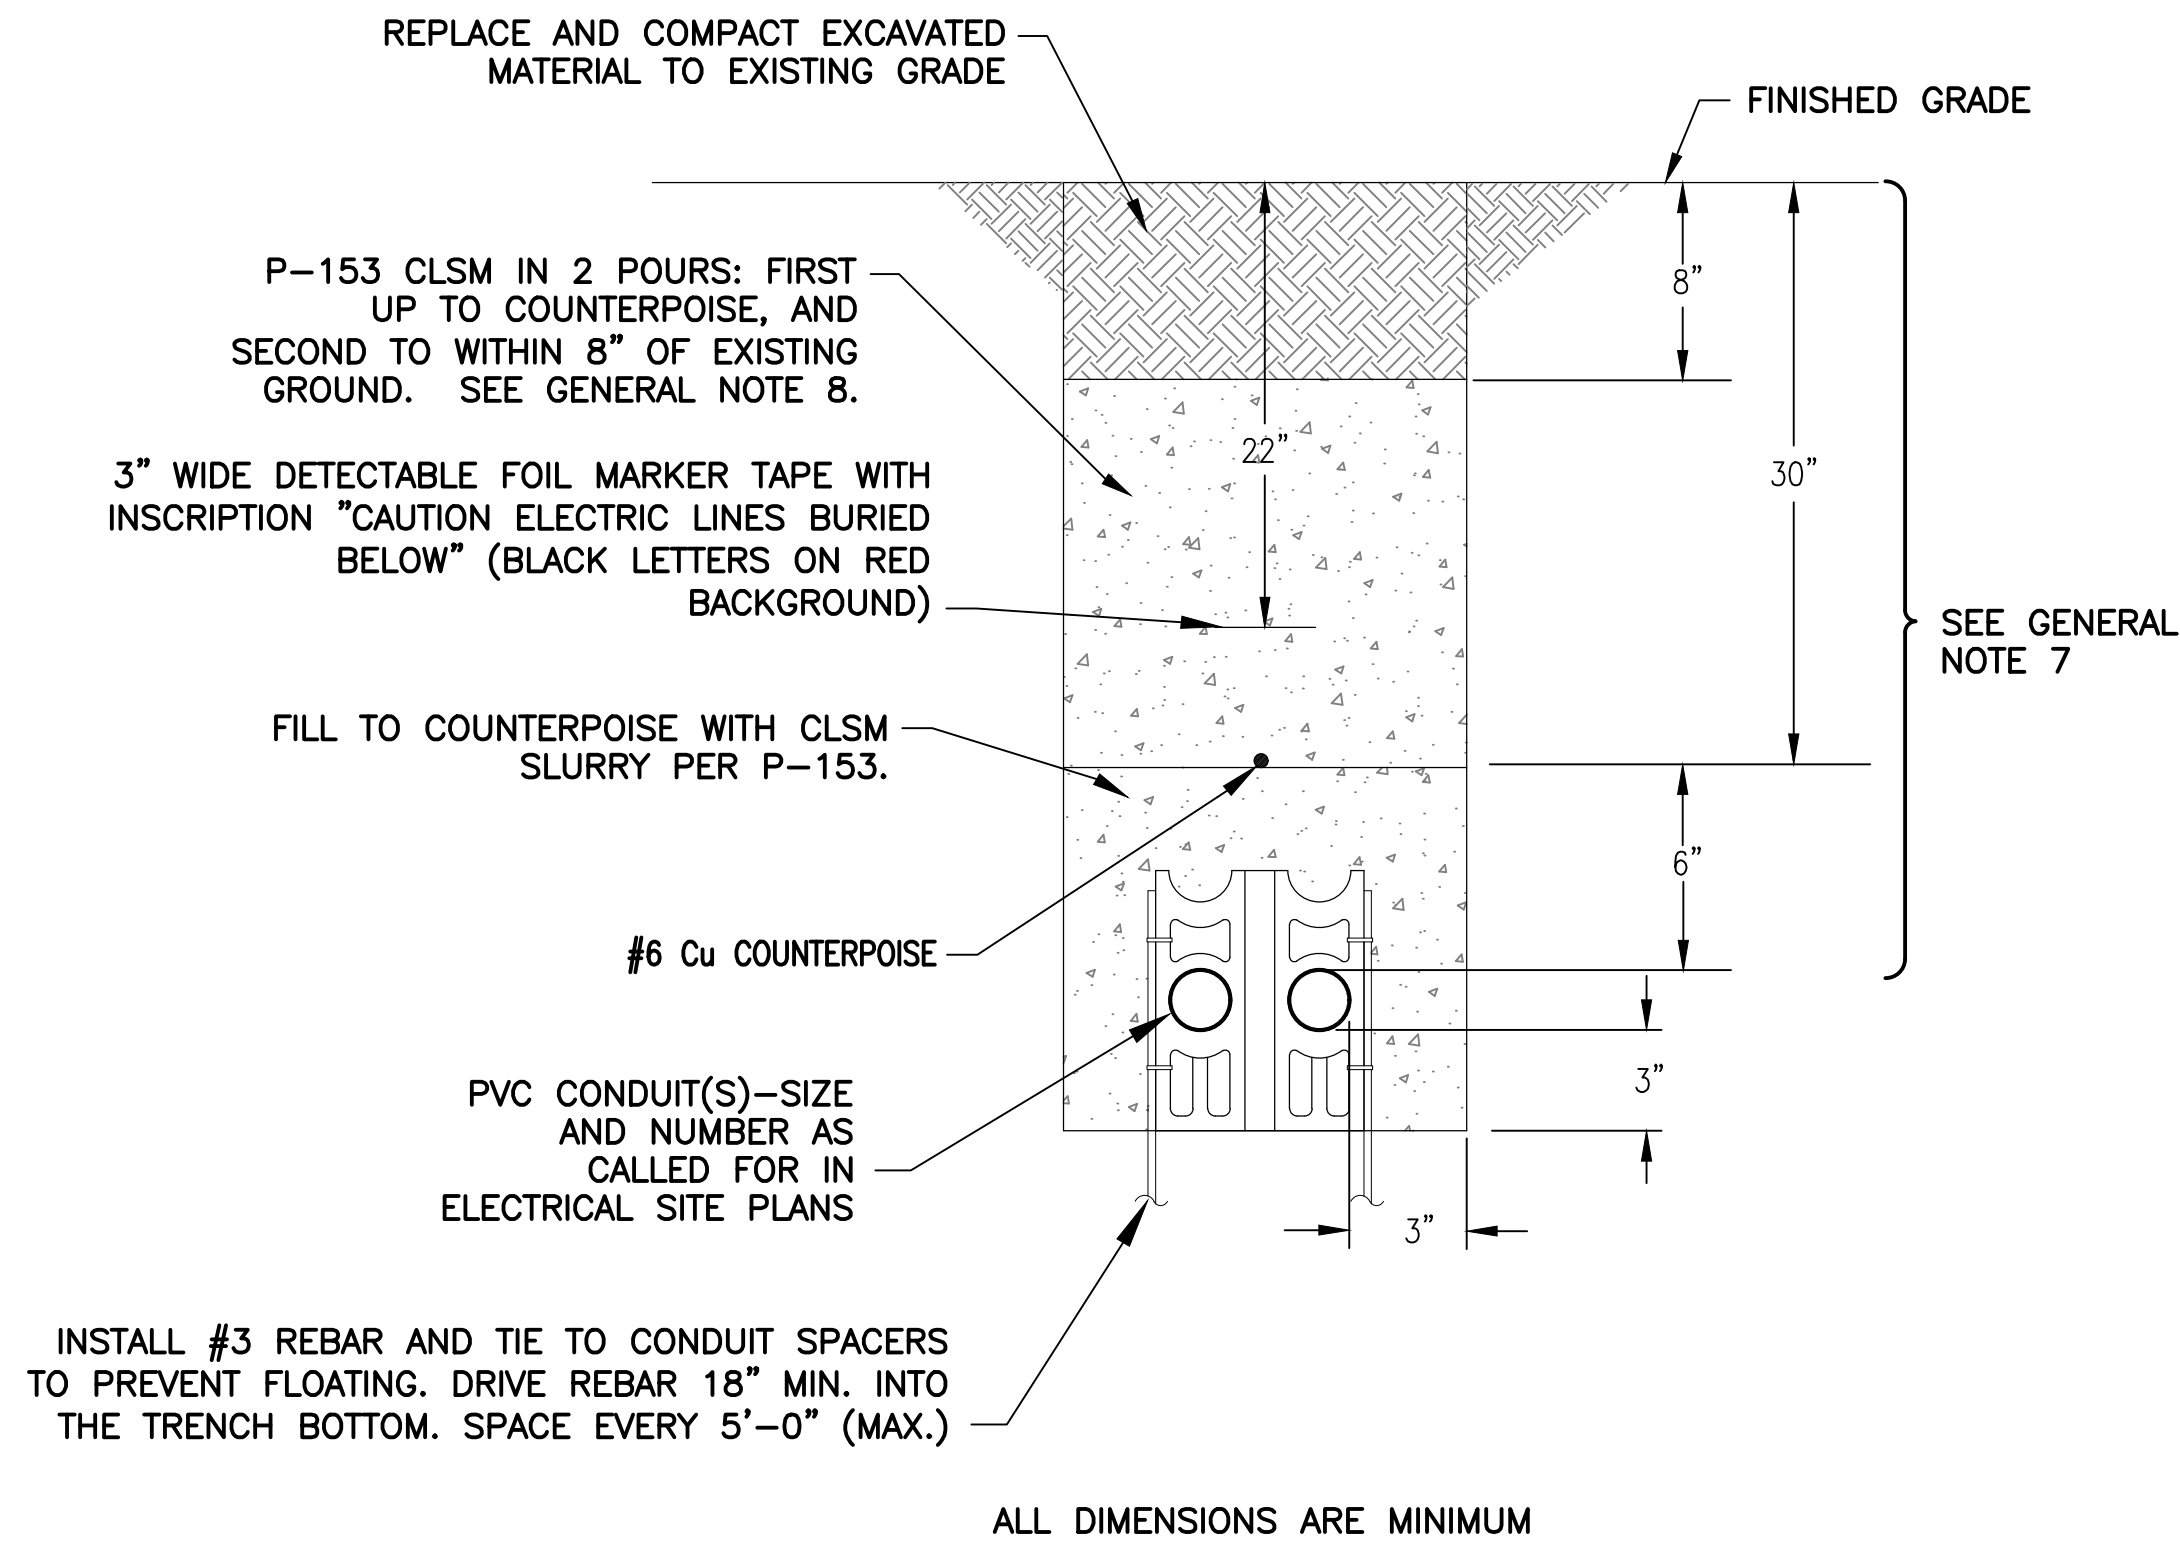


503 TYP SLURRY ENCASED (SE) CONDUIT DUCTBANK

GENERAL NOTES FOR CONDUIT INSTALLATION

1. PROVIDE PULL STRING IN ALL (NEW) UNUSED CONDUITS. PLUG ENDS IN HANDHOLES.
2. P-610 CONCRETE ENCASE UNDER PAVEMENT AND AS OTHERWISE INDICATED ON PLANS.
3. INSTALL A #6 BARE COPPER (Cu) COUNTERPOISE IN EACH DUCT ASSEMBLY FROM HANDHOLE-TO-HANDHOLE AND EXOTHERMICALLY WELD TO GROUND RODS AT EACH HANDHOLE.
4. INSTALL LIGHTING SERIES CIRCUITS AS FOLLOWS:
 - A. ONE CIRCUIT (1 OR 2 CONDUCTORS) PER 2"C. LIMIT 4"C TO NO MORE THAN (8) CONDUCTORS.
 - B. START INSTALLATION IN BOTTOM CONDUITS OF DUCT ARRAY, LEAVING THE UPPER CONDUITS EMPTY.
5. ALL UNDERGROUND CONDUITS SHALL MAINTAIN A 12" (MIN.) SEPARATION FROM ALL OTHER (EXISTING OR NEW) UNDERGROUND FACILITIES (i.e. water, sewer, and gas lines, including both public and private), UNLESS NOTED OTHERWISE ON DRAWINGS
6. CONDUIT IN DUCTBANK(S) ARE TO BE STACKED NO MORE THAN TWO (2) CONDUITS. IF MORE CONDUITS ARE NEEDED, THE WIDTH OF THE TRENCH IS TO BE INCREASED.
7. ADJUST DEPTH TO 18-24" TOTAL FOR CONDUIT INSTALLATION BETWEEN OR INTO L-867/L-868 BASE CAN. INSTALL COUNTERPOISE AT 12" BELOW GRADE FOR THESE SECTIONS.
8. BENEATH PAVE SURFACES, CONDUIT SHALL BE INCASED WITH P-610 STRUCTURAL PORTLAND CEMENT CONCRETE. TRENCHES SHALL BE BACKFILLED WITH P-153 CLSM UP TO THE BOTTOM OF THE P-401 OR P-501 PAVEMENT LAYER. REFER TO CIVIL SHEET C-501 FOR PROPOSED PAVEMENT SECTION THICKNESSES. BENEATH INFIELD AREAS, CONDUIT SHALL BE ENCASED WITH P-153 CLSM AND THE TRENCH BACKFILLED WITH CLSM UP TO THE LAST EIGHT (8) INCHES. THE TOP EIGHT (8) INCHES OF MATERIAL SHALL BE COMPACTED NATIVE SOIL.

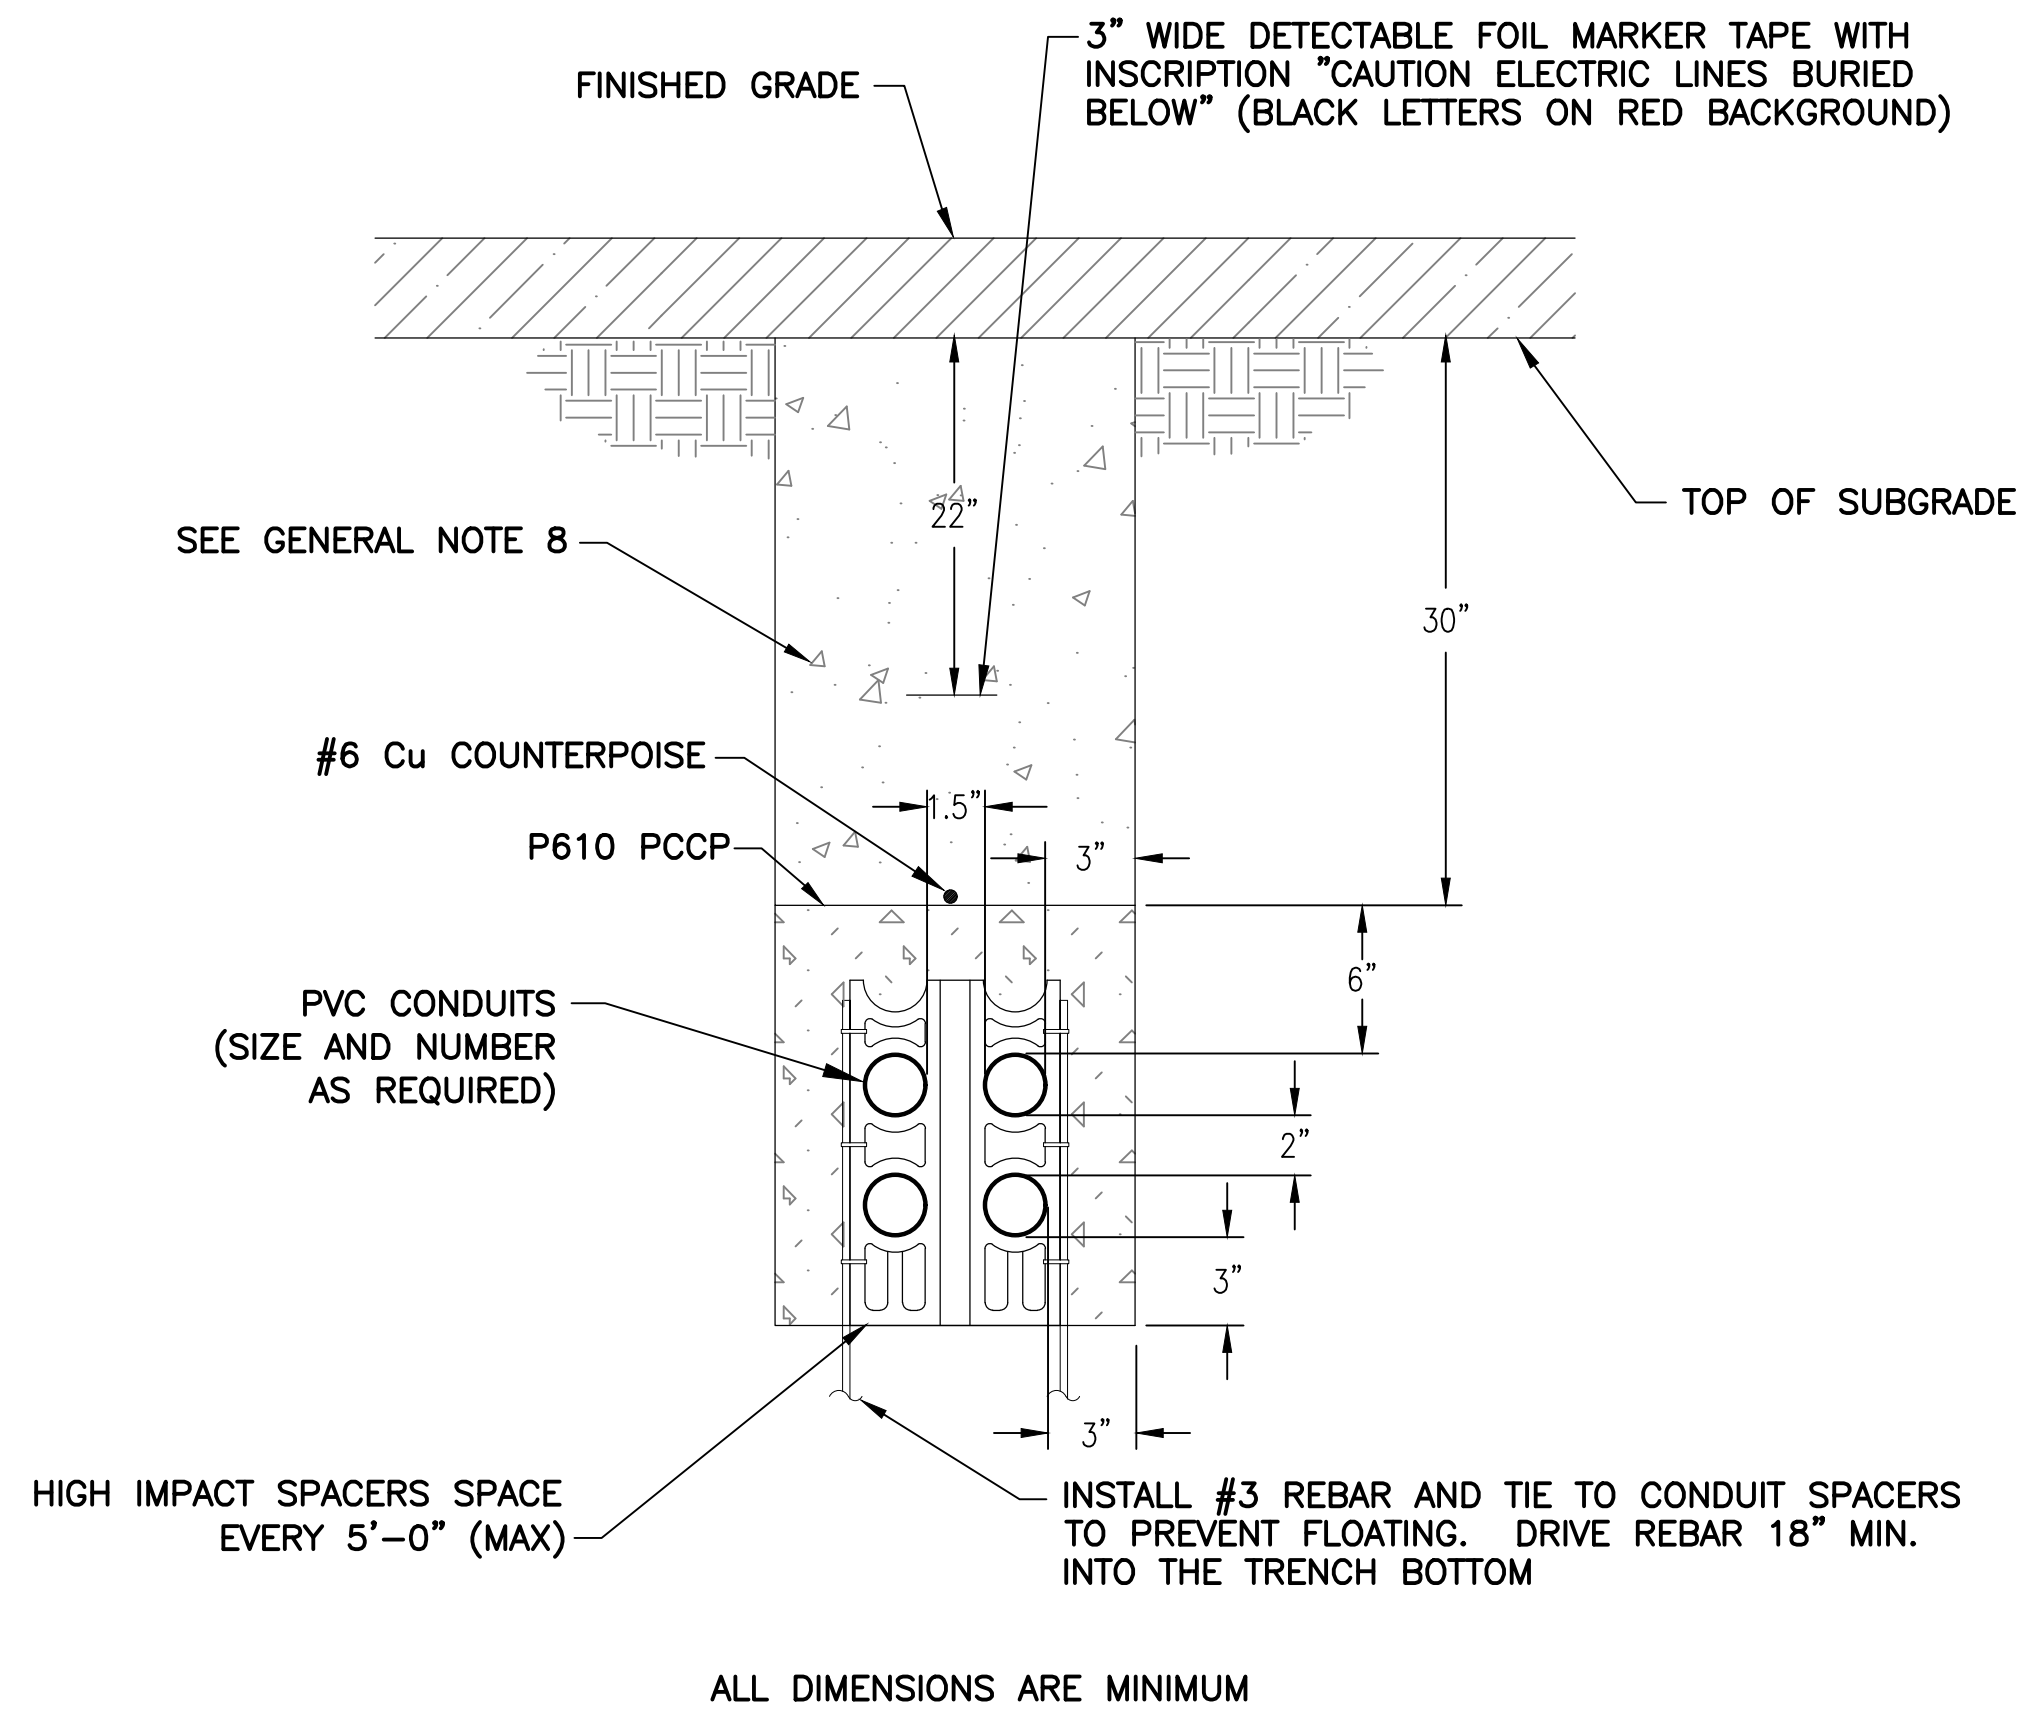


501 TYP CONCRETE ENCASED (CE) CONDUIT DUCTBANK

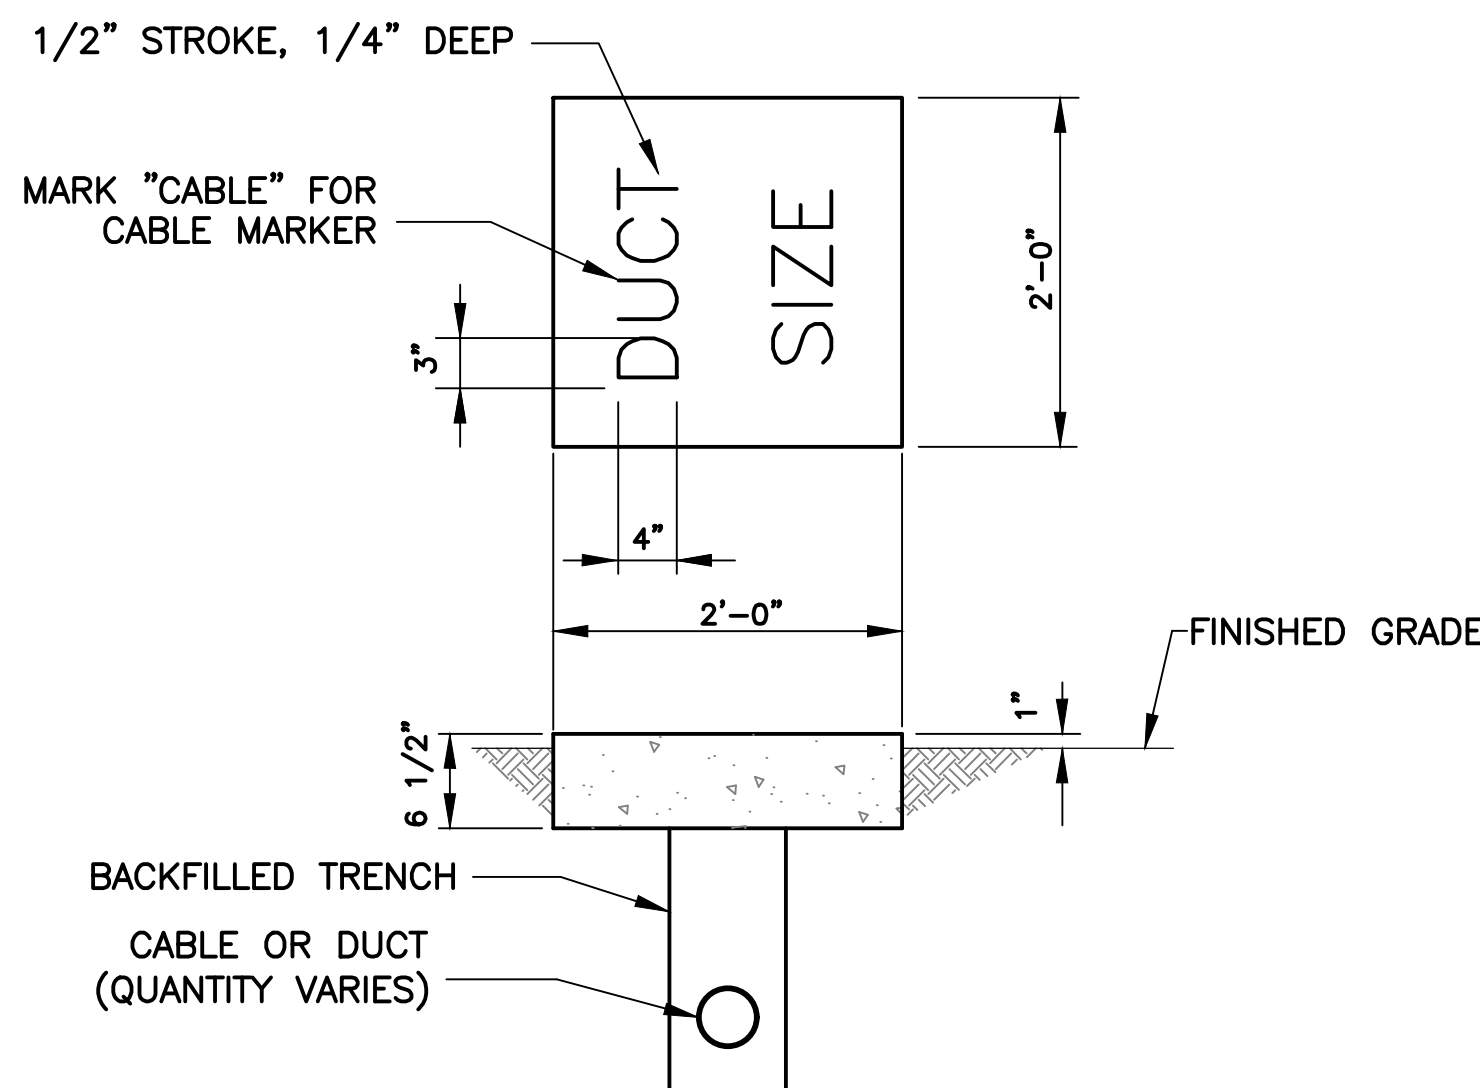

663 TYP CABLE/DUCT MARKER

NOTES

1. LOCATE THE MARKERS ABOVE THE ENDS OF ALL DUCTS OR DUCT BANKS, EXCEPT WHERE DUCTS TERMINATE IN THE HANDHOLE, MANHOLE, OR BUILDING. THE WORD "DUCT" MUST BE IMPRESSED ON EACH MARKER SLAB, AS WELL AS THE NUMBER AND SIZE OF DUCTS BENEATH THE MARKER.
2. COST OF CONCRETE MARKERS IS INCIDENTAL TO THE ASSOCIATED ITEMS OF DUCTS

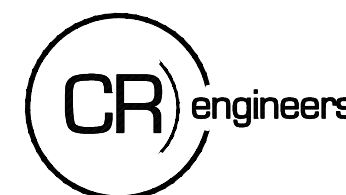

16719 East Palisades Blvd., Suite 202
Fountain Hills, AZ 85268
Phone: (480) 816-5541
Fax: (480) 816-5540

PER CITY OF PHOENIX CODE CHAPTER 2, SECTION 2-28. THESE PLANS ARE FOR OFFICIAL USE ONLY AND MAY NOT BE SHARED WITH OTHERS EXCEPT AS REQUIRED TO FULFILL THE OBLIGATIONS OF CONTRACTOR'S CONTRACT WITH THE CITY OF PHOENIX.


NO.	REVISIONS / SUBMISSIONS	DATE

PHX DVT EYR
CITY OF PHOENIX AVIATION DEPARTMENT
PHOENIX GOODYEAR AIRPORT
NEW APRON AND TAXIWAY CONNECTOR
AV41000077 FAA/ADOT

Designed by: SW	Drawn by: JBW
Checked by: CA	Date: May 2022
Dwg scale:	



Sheet Overview Title
ELECTRICAL DUCTBANK DETAILS

Sheet Reference Number:
EA-501
Sheet 52 of 61

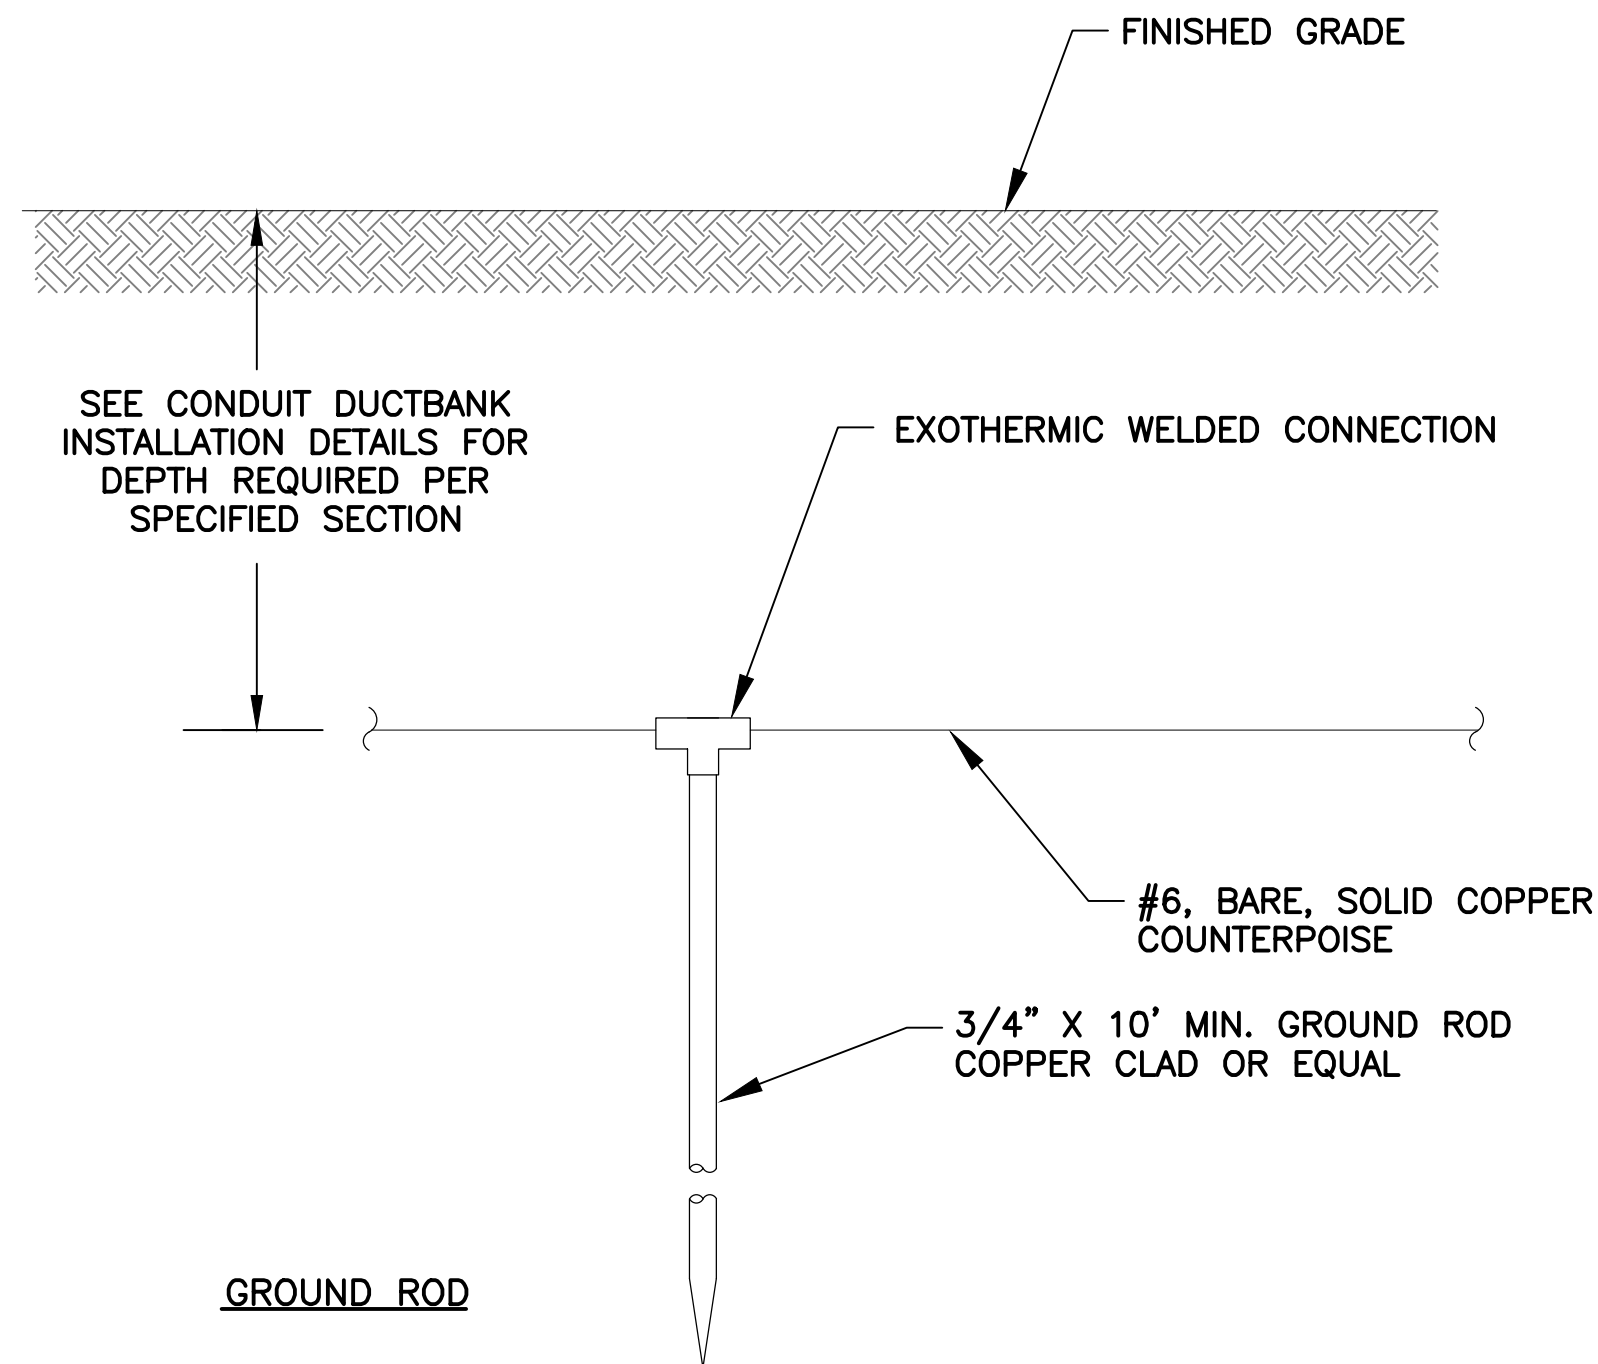


- NOTES

1. COST OF GROUND RODS SHALL BE INCIDENTAL TO THE ASSOCIATED ITEMS REQUIRING GROUNDING UNLESS OTHERWISE SPECIFIED.
2. WHERE POSSIBLE, NEW COUNTERPOISE SYSTEM SHALL BE CONNECTED TO ANY EXISTING COUNTERPOISE SYSTEM ENCOUNTERED.
3. GROUNDING ELECTRODES INSTALLED AS PART OF THE COUNTERPOISE SYSTEM SHALL BE SPACED AT DISTANCES NO GREATER THAN 500 FT. (MAX).
4. REFER TO DETAILS 501, SHEET EA-501, FOR CONCRETE ENCASED CONDUITS. REFER TO DETAIL 503, SHEET EA-501 FOR SLURRY ENCASED CONDUITS.
5. MAINTAIN SIX INCH (MINIMUM) VERTICAL SEPARATION BETWEEN COUNTERPOISE AND TYPE "C" CABLE IN 2" CONDUIT.
6. PROVIDE GROUND ROD FOR EXOTHERMICALLY WELDING TO COUNTERPOISE AT END OF SINGLE CONDUITS TERMINATING AT FIXTURE OR SIGN BASES IF DISTANCE IS GREATER THAN 100' FROM HANDHOLE OR LAST INSTALLED COUNTERPOISE ROD.

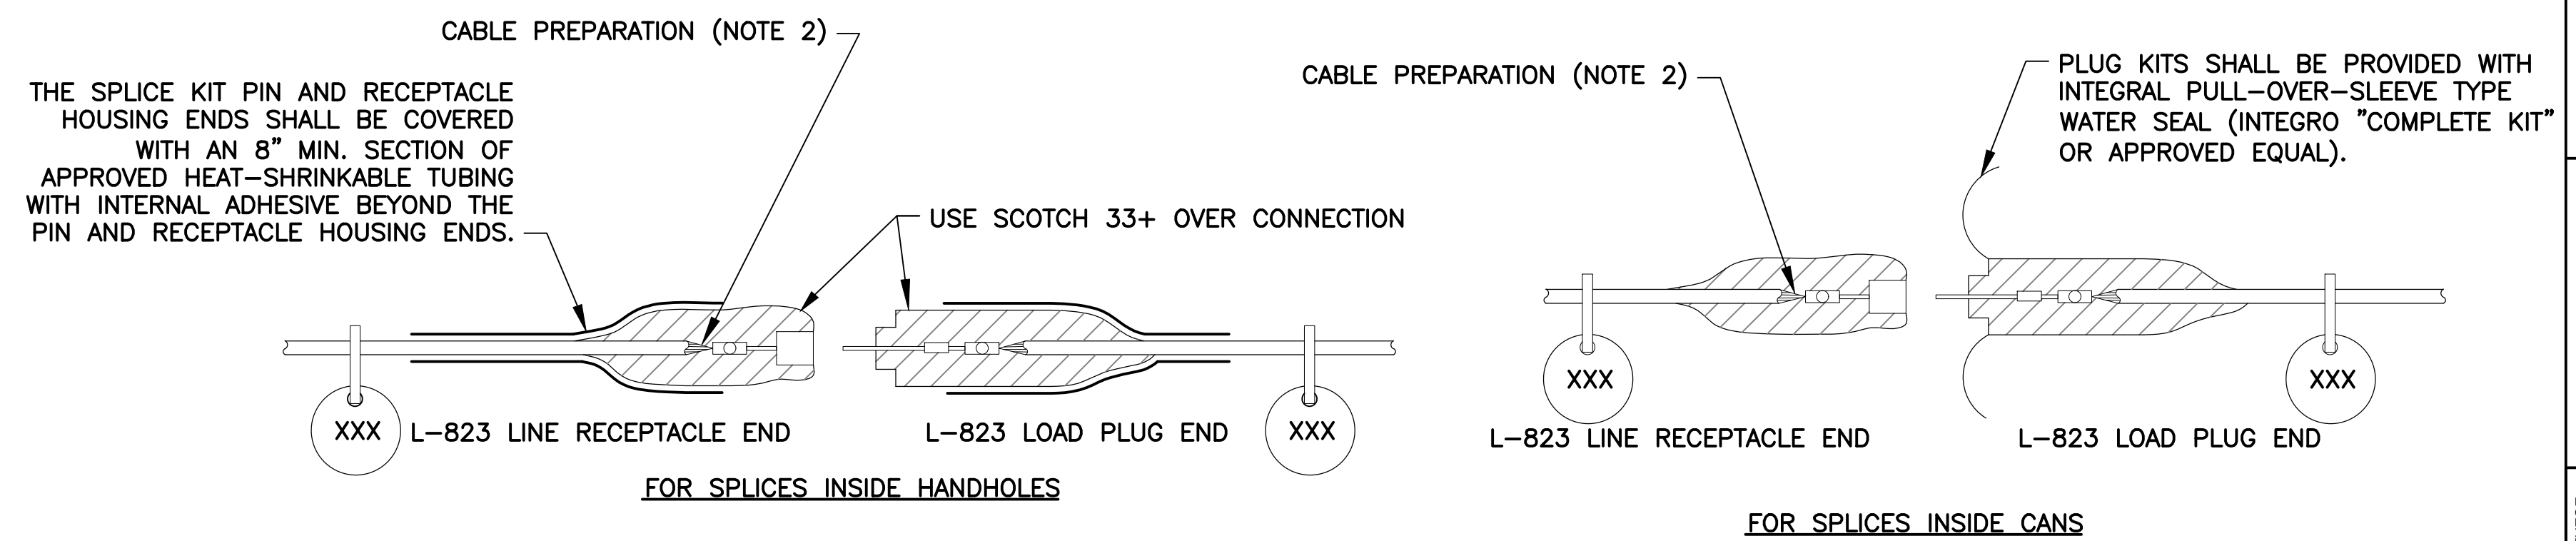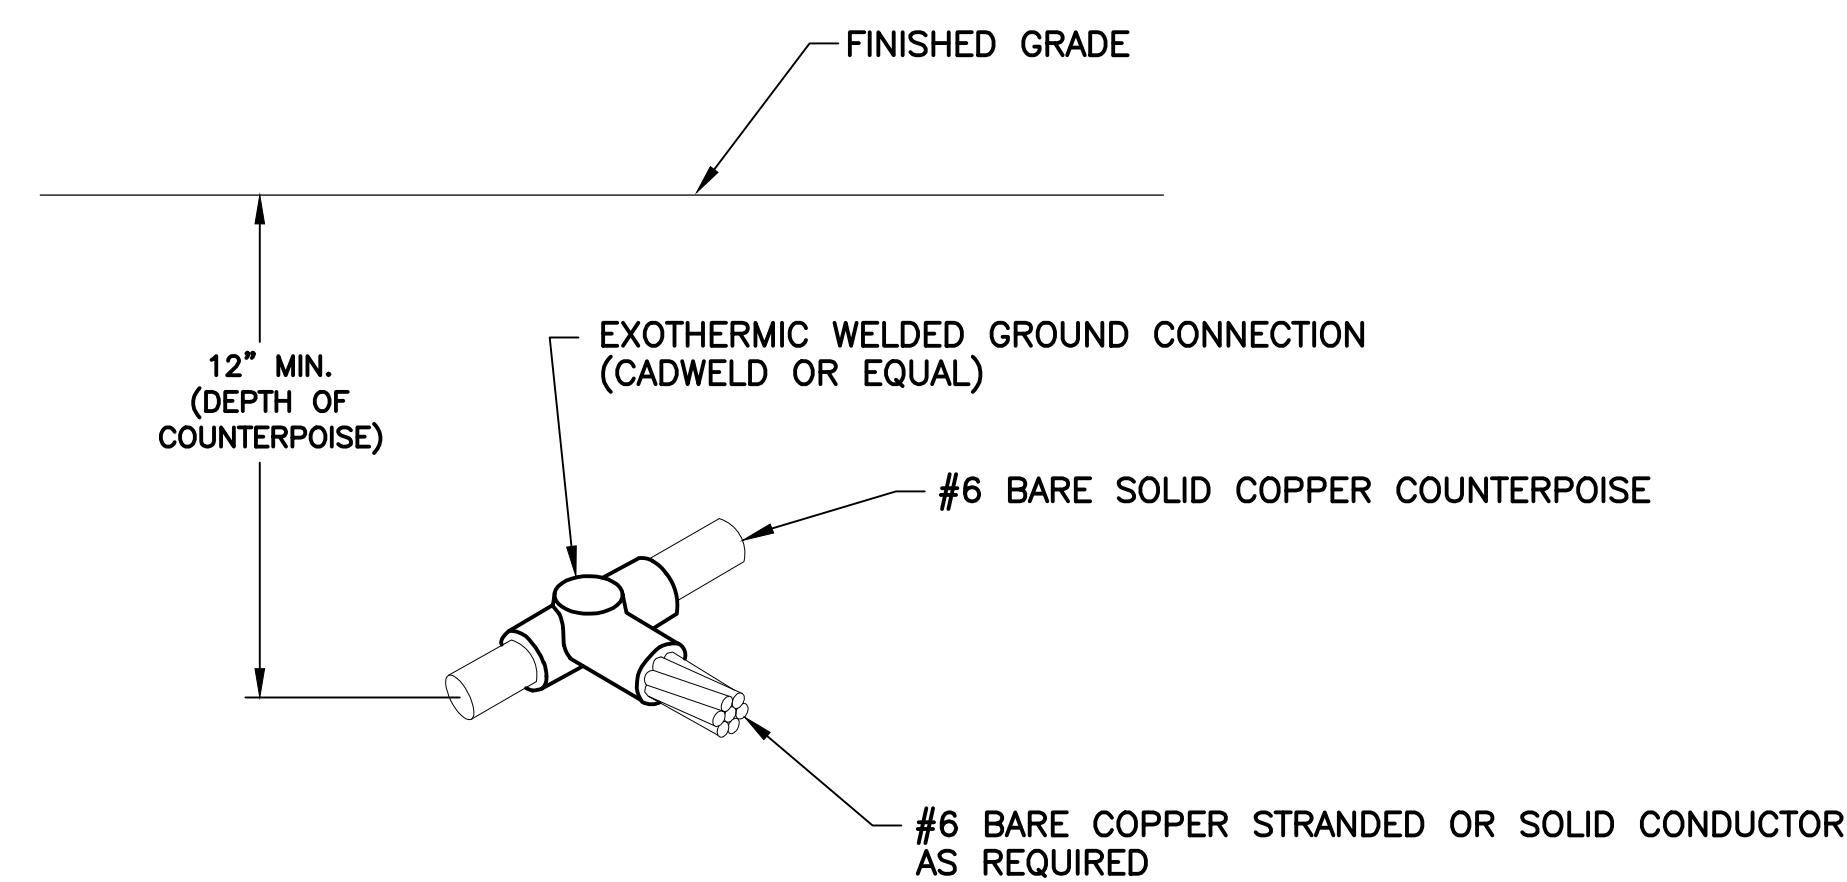


- NOTES

1. PROVIDE MALE AND FEMALE L-823 CONNECTORS AS REQUIRED ON EACH CONDUCTOR IN EACH BASE, HANDHOLE, OR MANHOLE TO ALLOW ISOLATION OF HOMERUN CIRCUIT, NO STRAIGHT-THROUGH ALLOWED.
2. ALL CABLE ENDS SHALL BE PREPARED WITH THE USE OF A TAPERING TOOL SPECIFICALLY DESIGNED FOR USE WITH L-824 CABLES.
3. PLUG AND RECEPTACLE END FITTINGS SHALL BE CRIMPED ONTO THE CONDUCTOR BY USE OF AN AIRPORT PERSONNEL ACCEPTED RATCHETING TYPE CRIMPING TOOL.
4. AT THE POINT OF CONNECTION WITH THE EXISTING FIELD CIRCUITS, INSTALL NEW L-823 PLUGS ON BOTH THE NEW AND EXISTING CABLES. VERIFY INSULATION TYPES OF BOTH NEW & EXISTING CABLES AND COORDINATE WITH TERMINATION KITS TO ASSURE PROPER AND WATERPROOF FIT.
5. INSTALL 33+VINYL-130C ELECTRICAL TAPE AND A SECOND LAYER OF RUBBER-33+VINYL ON CONNECTION AFTER PULLING SLEEVE OVER COMPLETE KIT.
6. THERE SHALL BE NO SPLICES BETWEEN LIGHTS, ONLY IN BASES OR HANDHOLES.
7. PROVIDE AND INSTALL NON-CONDUCTIVE CIRCUIT IDENTIFICATION TAGS ATTACHED TO EACH SIDE OF ALL CONNECTOR KITS.
8. ON THE CABLES FOR THE RUNWAY CIRCUIT, TAPE FROM THE BACK END OF THE CONNECTOR KIT ONTO CABLE FOR 3" EACH, RED PHASE TAPE FOR FASTER IDENTIFICATION AND MATCH EXISTING MANHOLE LAYOUTS.
9. ON THE CABLES FOR THE TAXIWAY AND SIGNAGE CIRCUITS, TAPE FROM THE BACK END OF THE CONNECTOR KIT ONTO CABLE FOR 3" EACH, BLUE THEN WHITE PHASE TAPE FOR SIGNS, BLUE ONLY PHASE TAPE FOR TAXIWAY EDGE LIGHTS, FOR FASTER IDENTIFICATION AND MATCH EXISTING MANHOLE LAYOUTS.

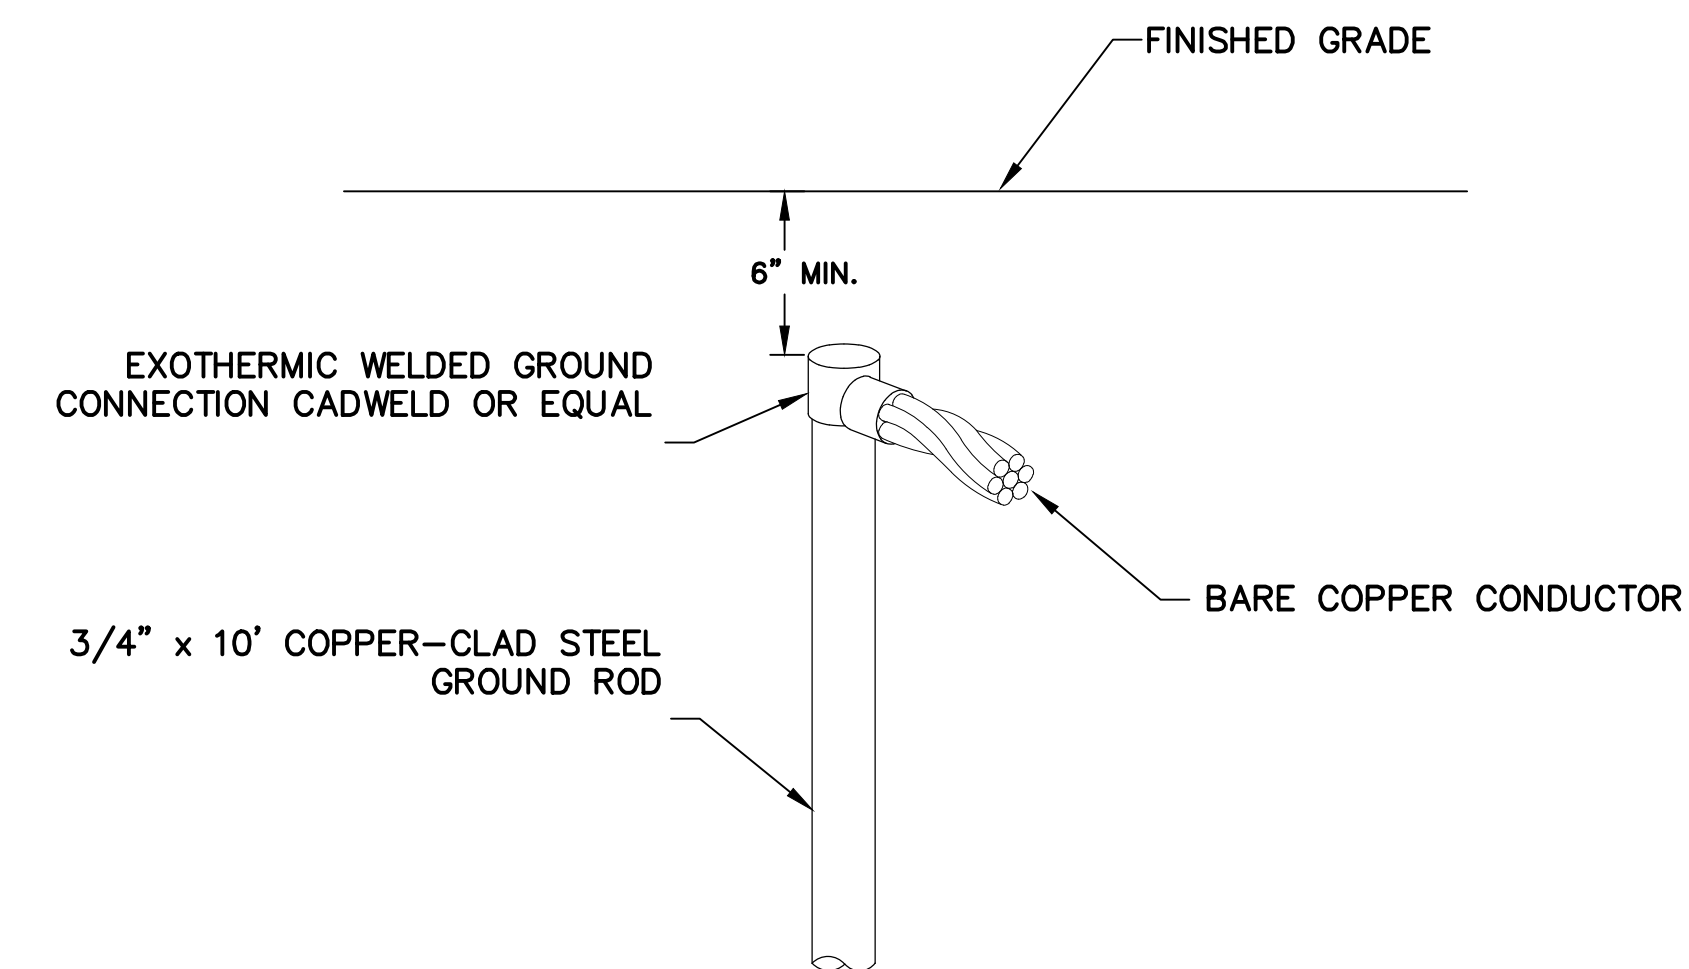

16719 East Palisades Blvd., Suite 202
Fountain Hills, AZ 85268
Phone: (480) 816-5541
Fax: (480) 816-5540

PER CITY OF PHOENIX CODE CHAPTER 2, SECTION 2-28. THESE PLANS ARE FOR OFFICIAL USE ONLY AND MAY NOT BE SHARED WITH OTHERS EXCEPT AS REQUIRED TO FULFILL THE OBLIGATIONS OF CONTRACTOR'S CONTRACT WITH THE CITY OF PHOENIX.

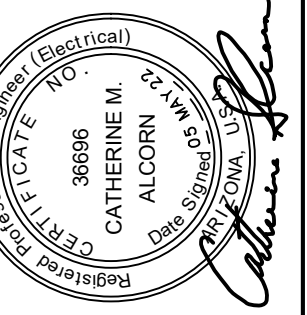[illegible]


PHX **PHX** **PHX**
CITY OF PHOENIX AVIATION DEPARTMENT
PHOENIX GOODYEAR AIRPORT
NEW APRON AND TAXIWAY CONNECTOR
AV41000077 FAA/ADOT

Designed by: SW
Drawn by: JBW
Checked by: CA
Date: May 2022
Dwg scale:


GROUNDING DETAILS

Sheet
Reference
Number:

EA-502

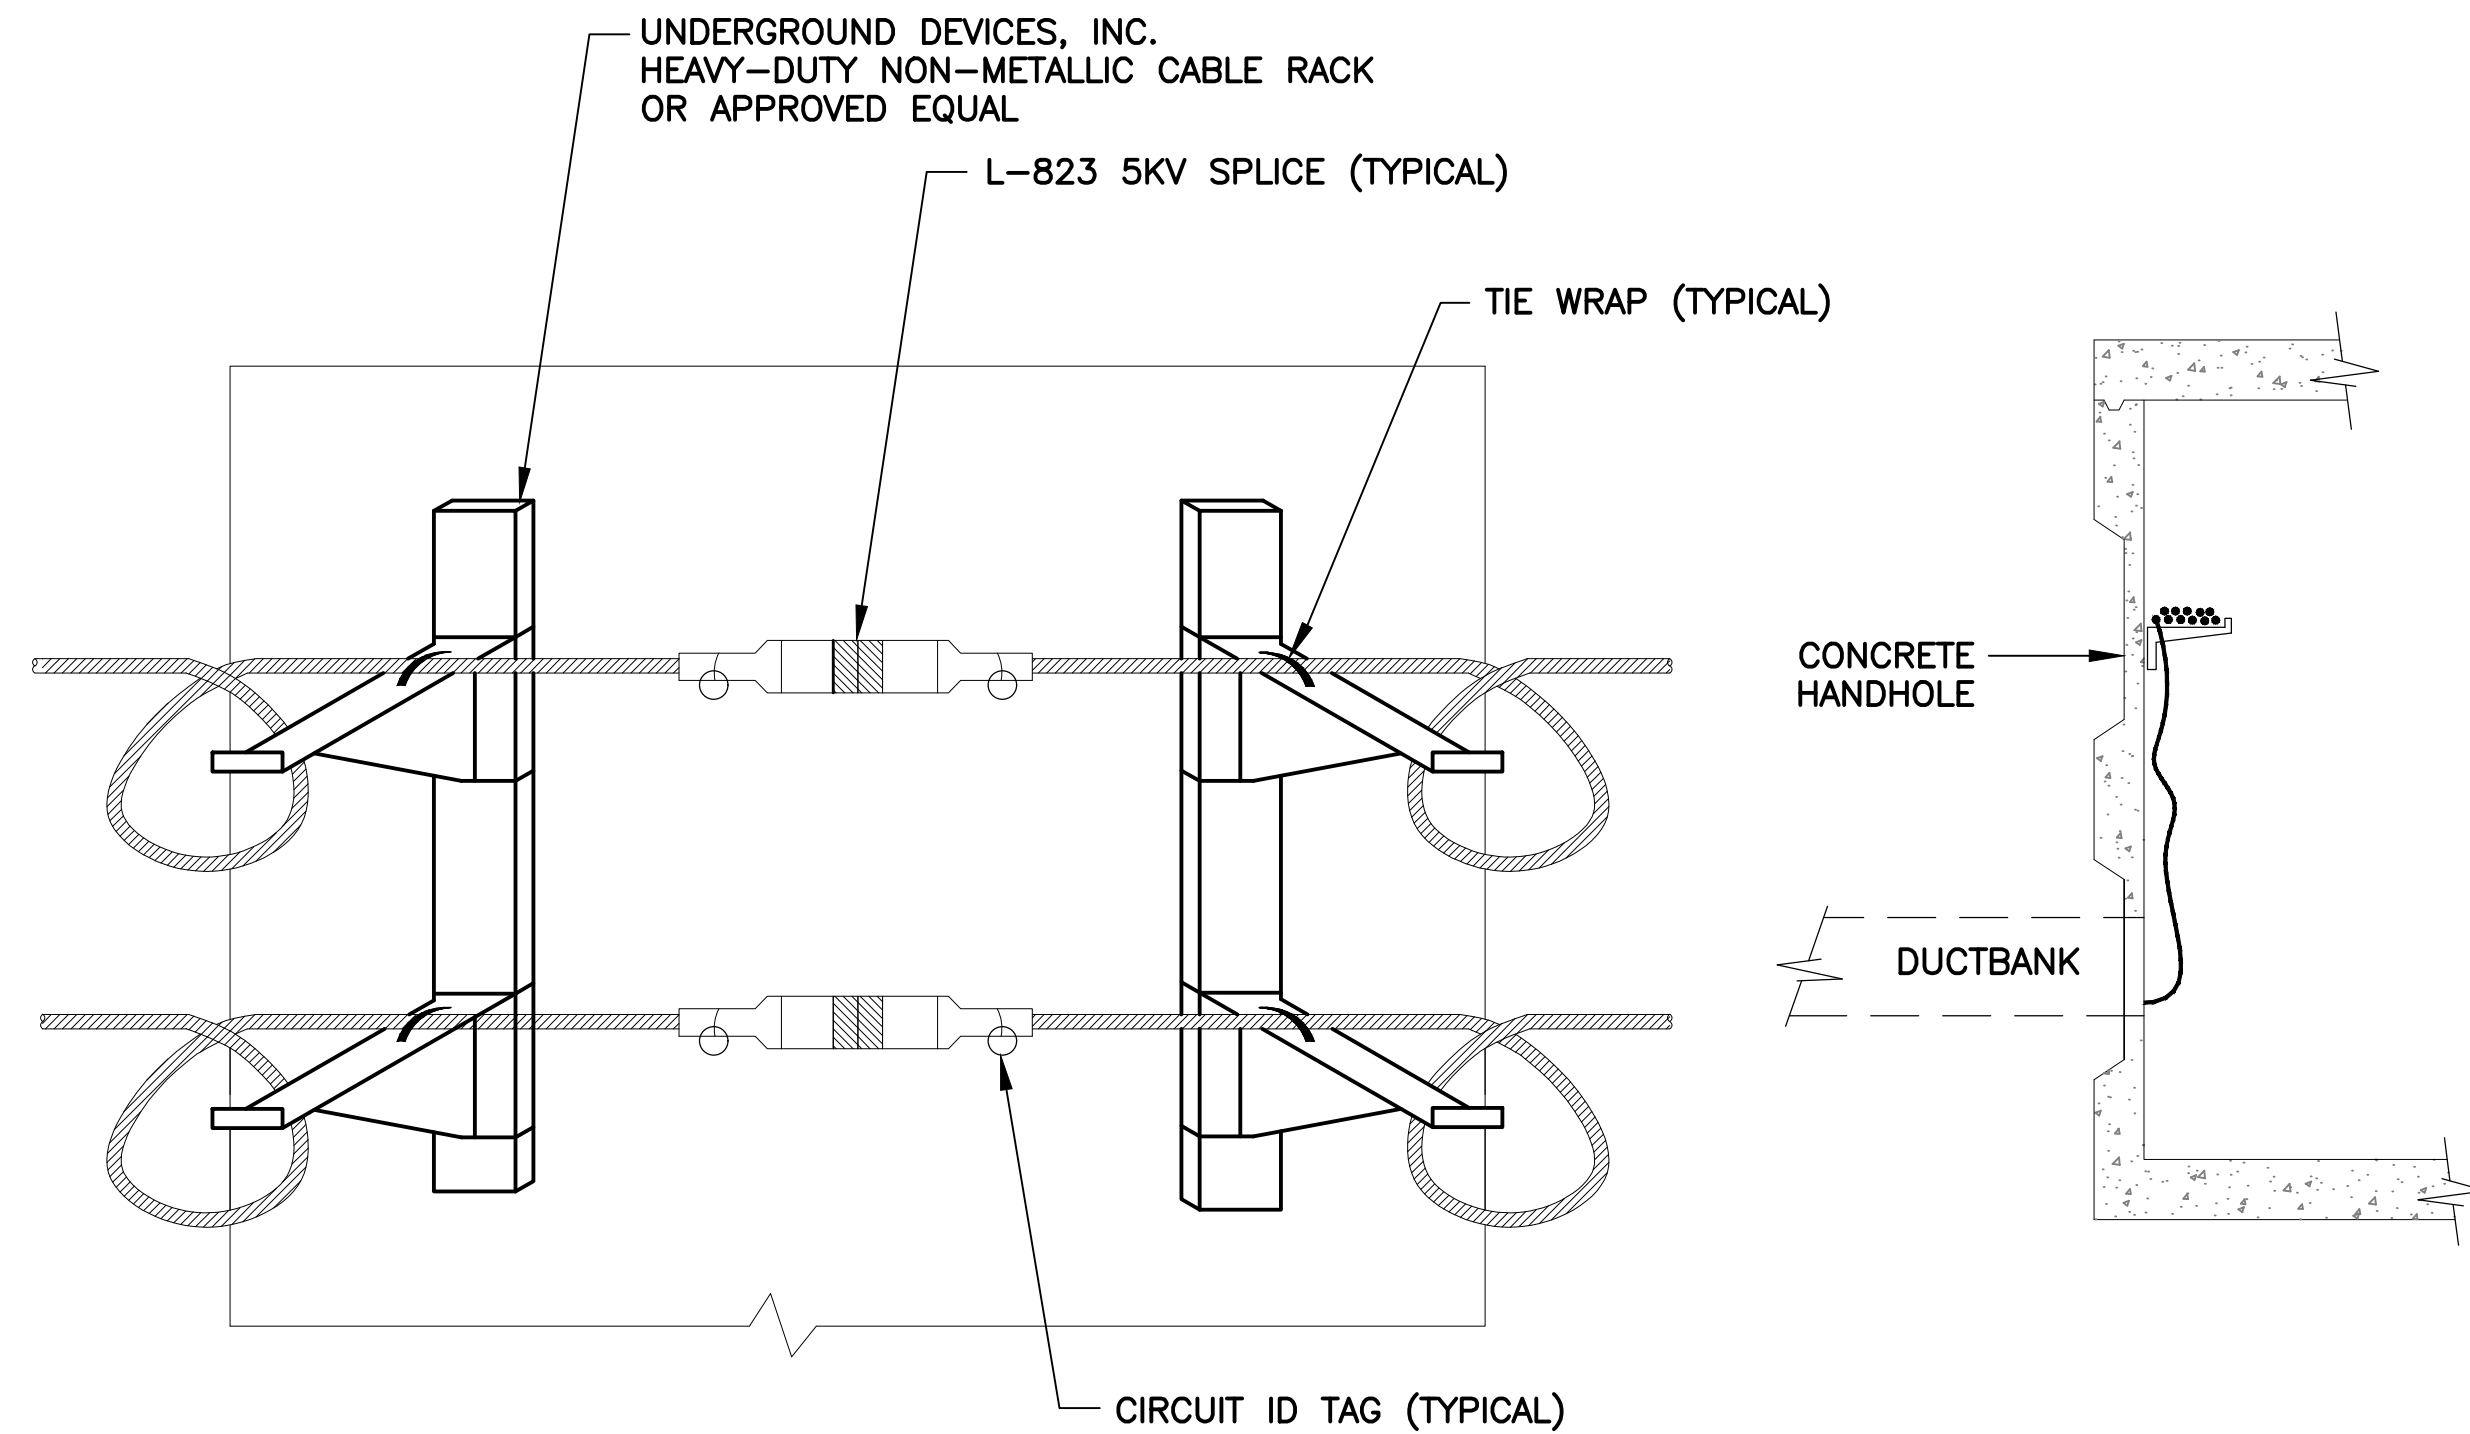


C CABLE RACKING DETAIL

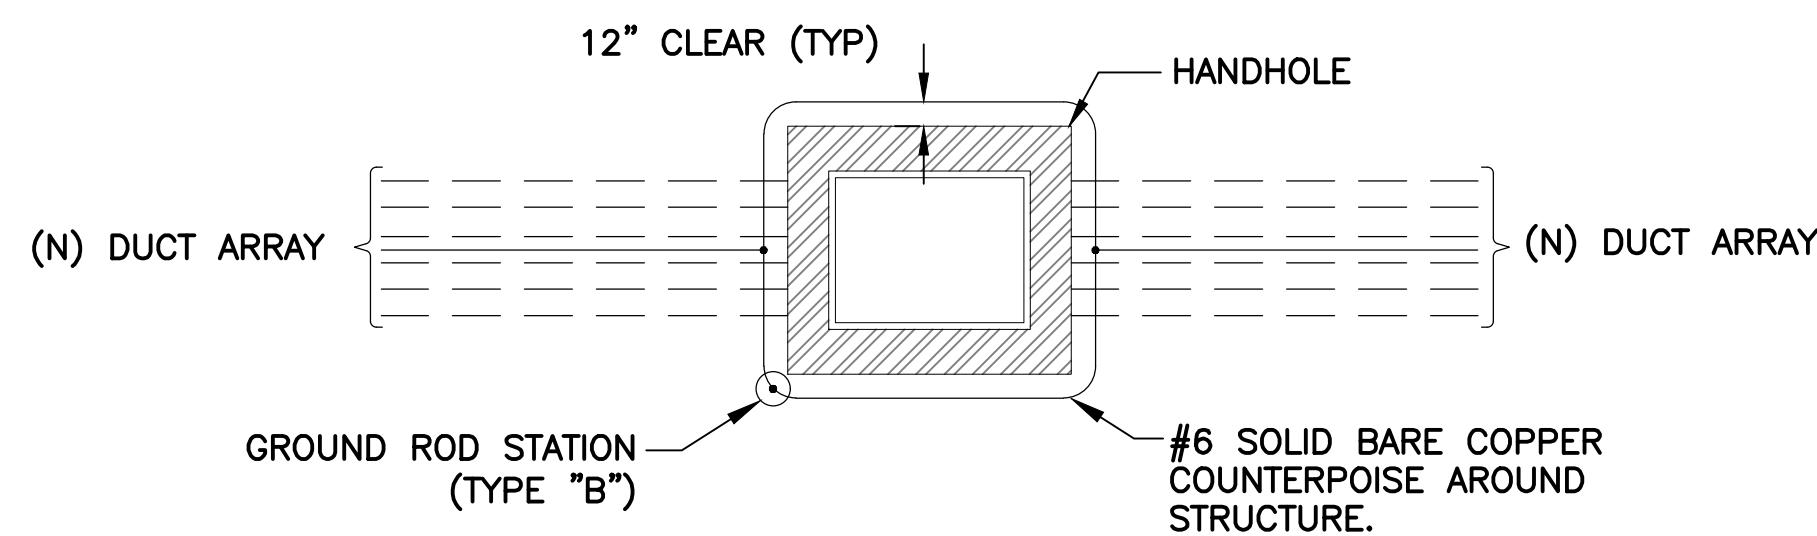

A HANDHOLE COUNTERPOISE DETAIL

NOTES:


ALL COUNTERPOISE WIRES FOR DUCTBANKS AND CONDUITS TO BE EXOTHERMICALLY WELDED TO COUNTERPOISE LOOP AROUND STRUCTURE

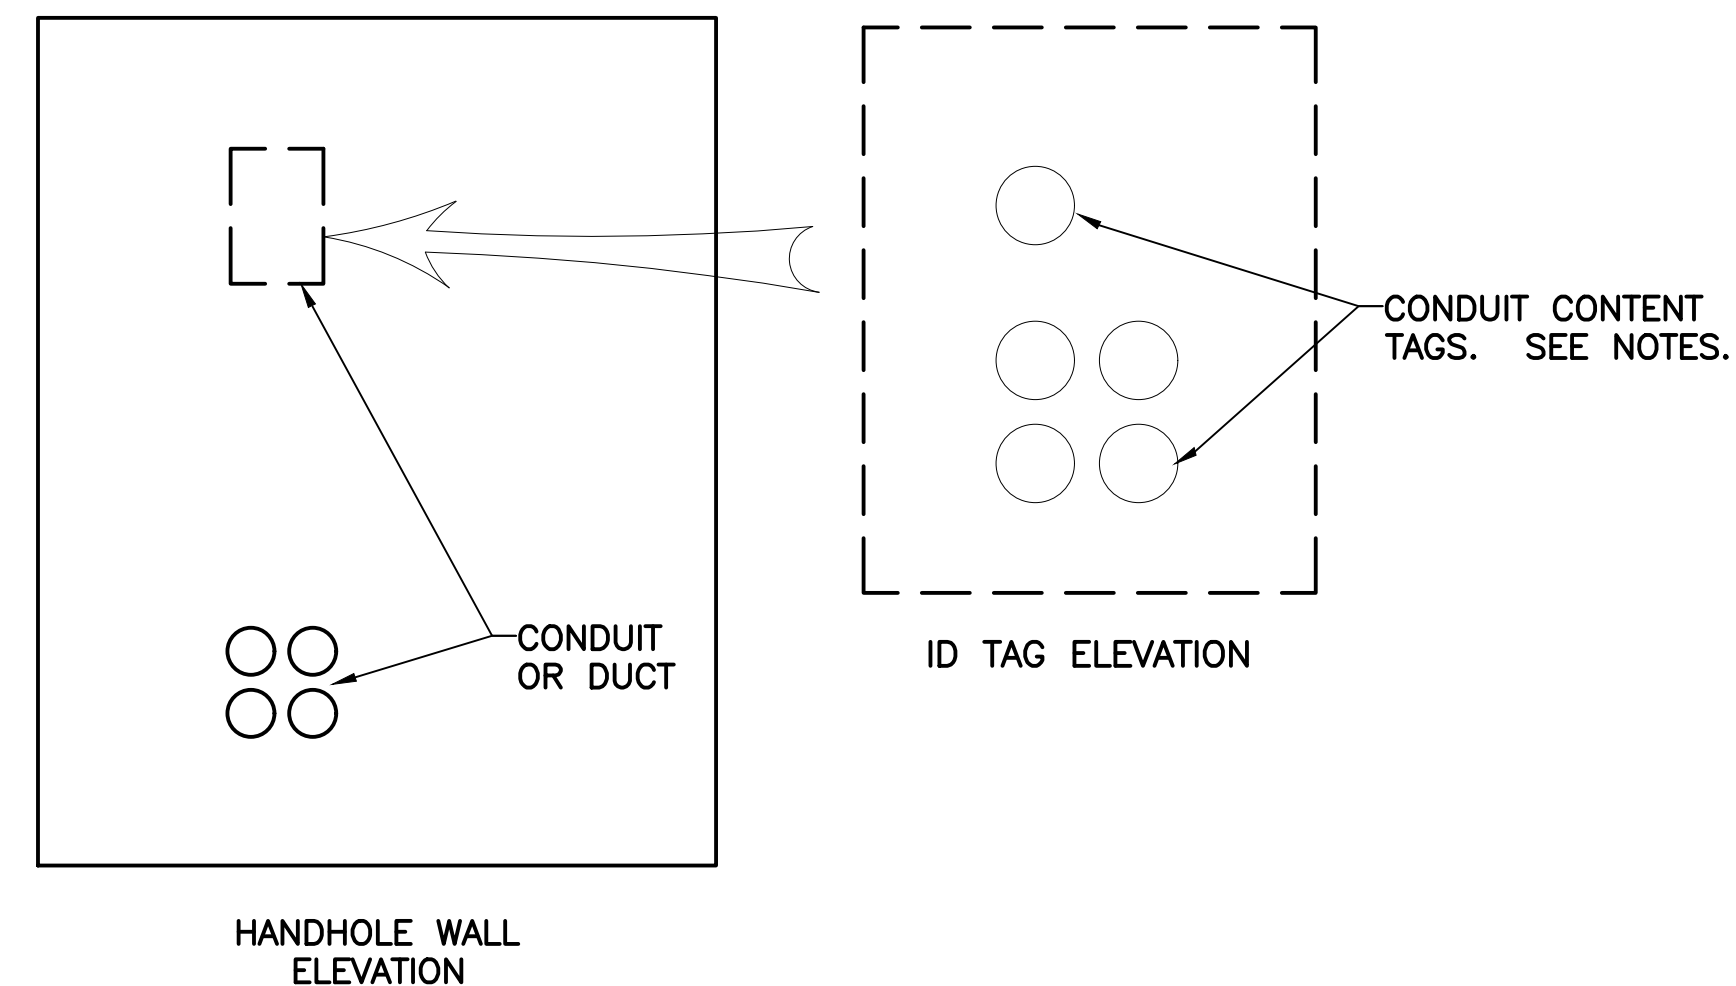

B CABLE ROUTING IDENTIFICATION TAG DETAIL


PLAQUE NOTES:

1. AFFIX ENGRAVED PHENOLIC TAGS TO THE WALL WITH SILICONE SEALANT ABOVE THE DUCT OR CONDUIT ENTRY IN A WAY THAT MIMICS THE ARRAY. WIRE BRUSH CONCRETE WALL TO ASSURE ADHESION.
2. THE TAGS SHALL BE APPROX 1"H x 2"L AND SHALL HAVE MINIMUM 1/4" LETTERING.

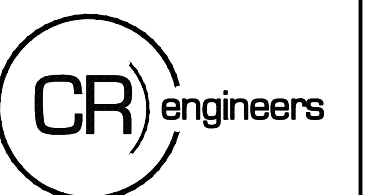

16719 East Palisades Blvd., Suite 202
Fountain Hills, AZ 85268
Phone: (480) 816-5541
Fax: (480) 816-5540

PER CITY OF PHOENIX CODE CHAPTER 2, SECTION 2-28. THESE PLANS ARE FOR OFFICIAL USE ONLY AND MAY NOT BE SHARED WITH OTHERS EXCEPT AS REQUIRED TO FULFILL THE OBLIGATIONS OF CONTRACTOR'S CONTRACT WITH THE CITY OF PHOENIX.

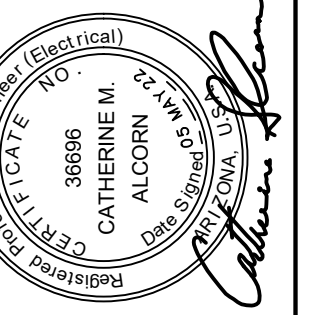

PER CITY OF PHOENIX CITY CODE CHAPTER 2, SECTION 2-28, THESE PLANS ARE FOR OFFICIAL USE ONLY AND MAY NOT BE SHARED WITH OTHERS EXCEPT AS REQUIRED TO FULFILL THE OBLIGATIONS OF YOUR CONTRACT WITH THE CITY OF PHOENIX.

NO.	REVISIONS / SUBMISSIONS	DATE


PHX DOT CYR
CITY OF PHOENIX AVIATION DEPARTMENT
PHOENIX GOODYEAR AIRPORT
NEW APRON AND TAXIWAY CONNECTOR
AV41000077 FAA/ADOT

Designed by: SW	Drawn by: JCA
Checked by: CA	Date: May 2022
Dwg scale:	

Sheet Overview Title
HANDHOLE DETAILS


Sheet Reference Number:

EA-503

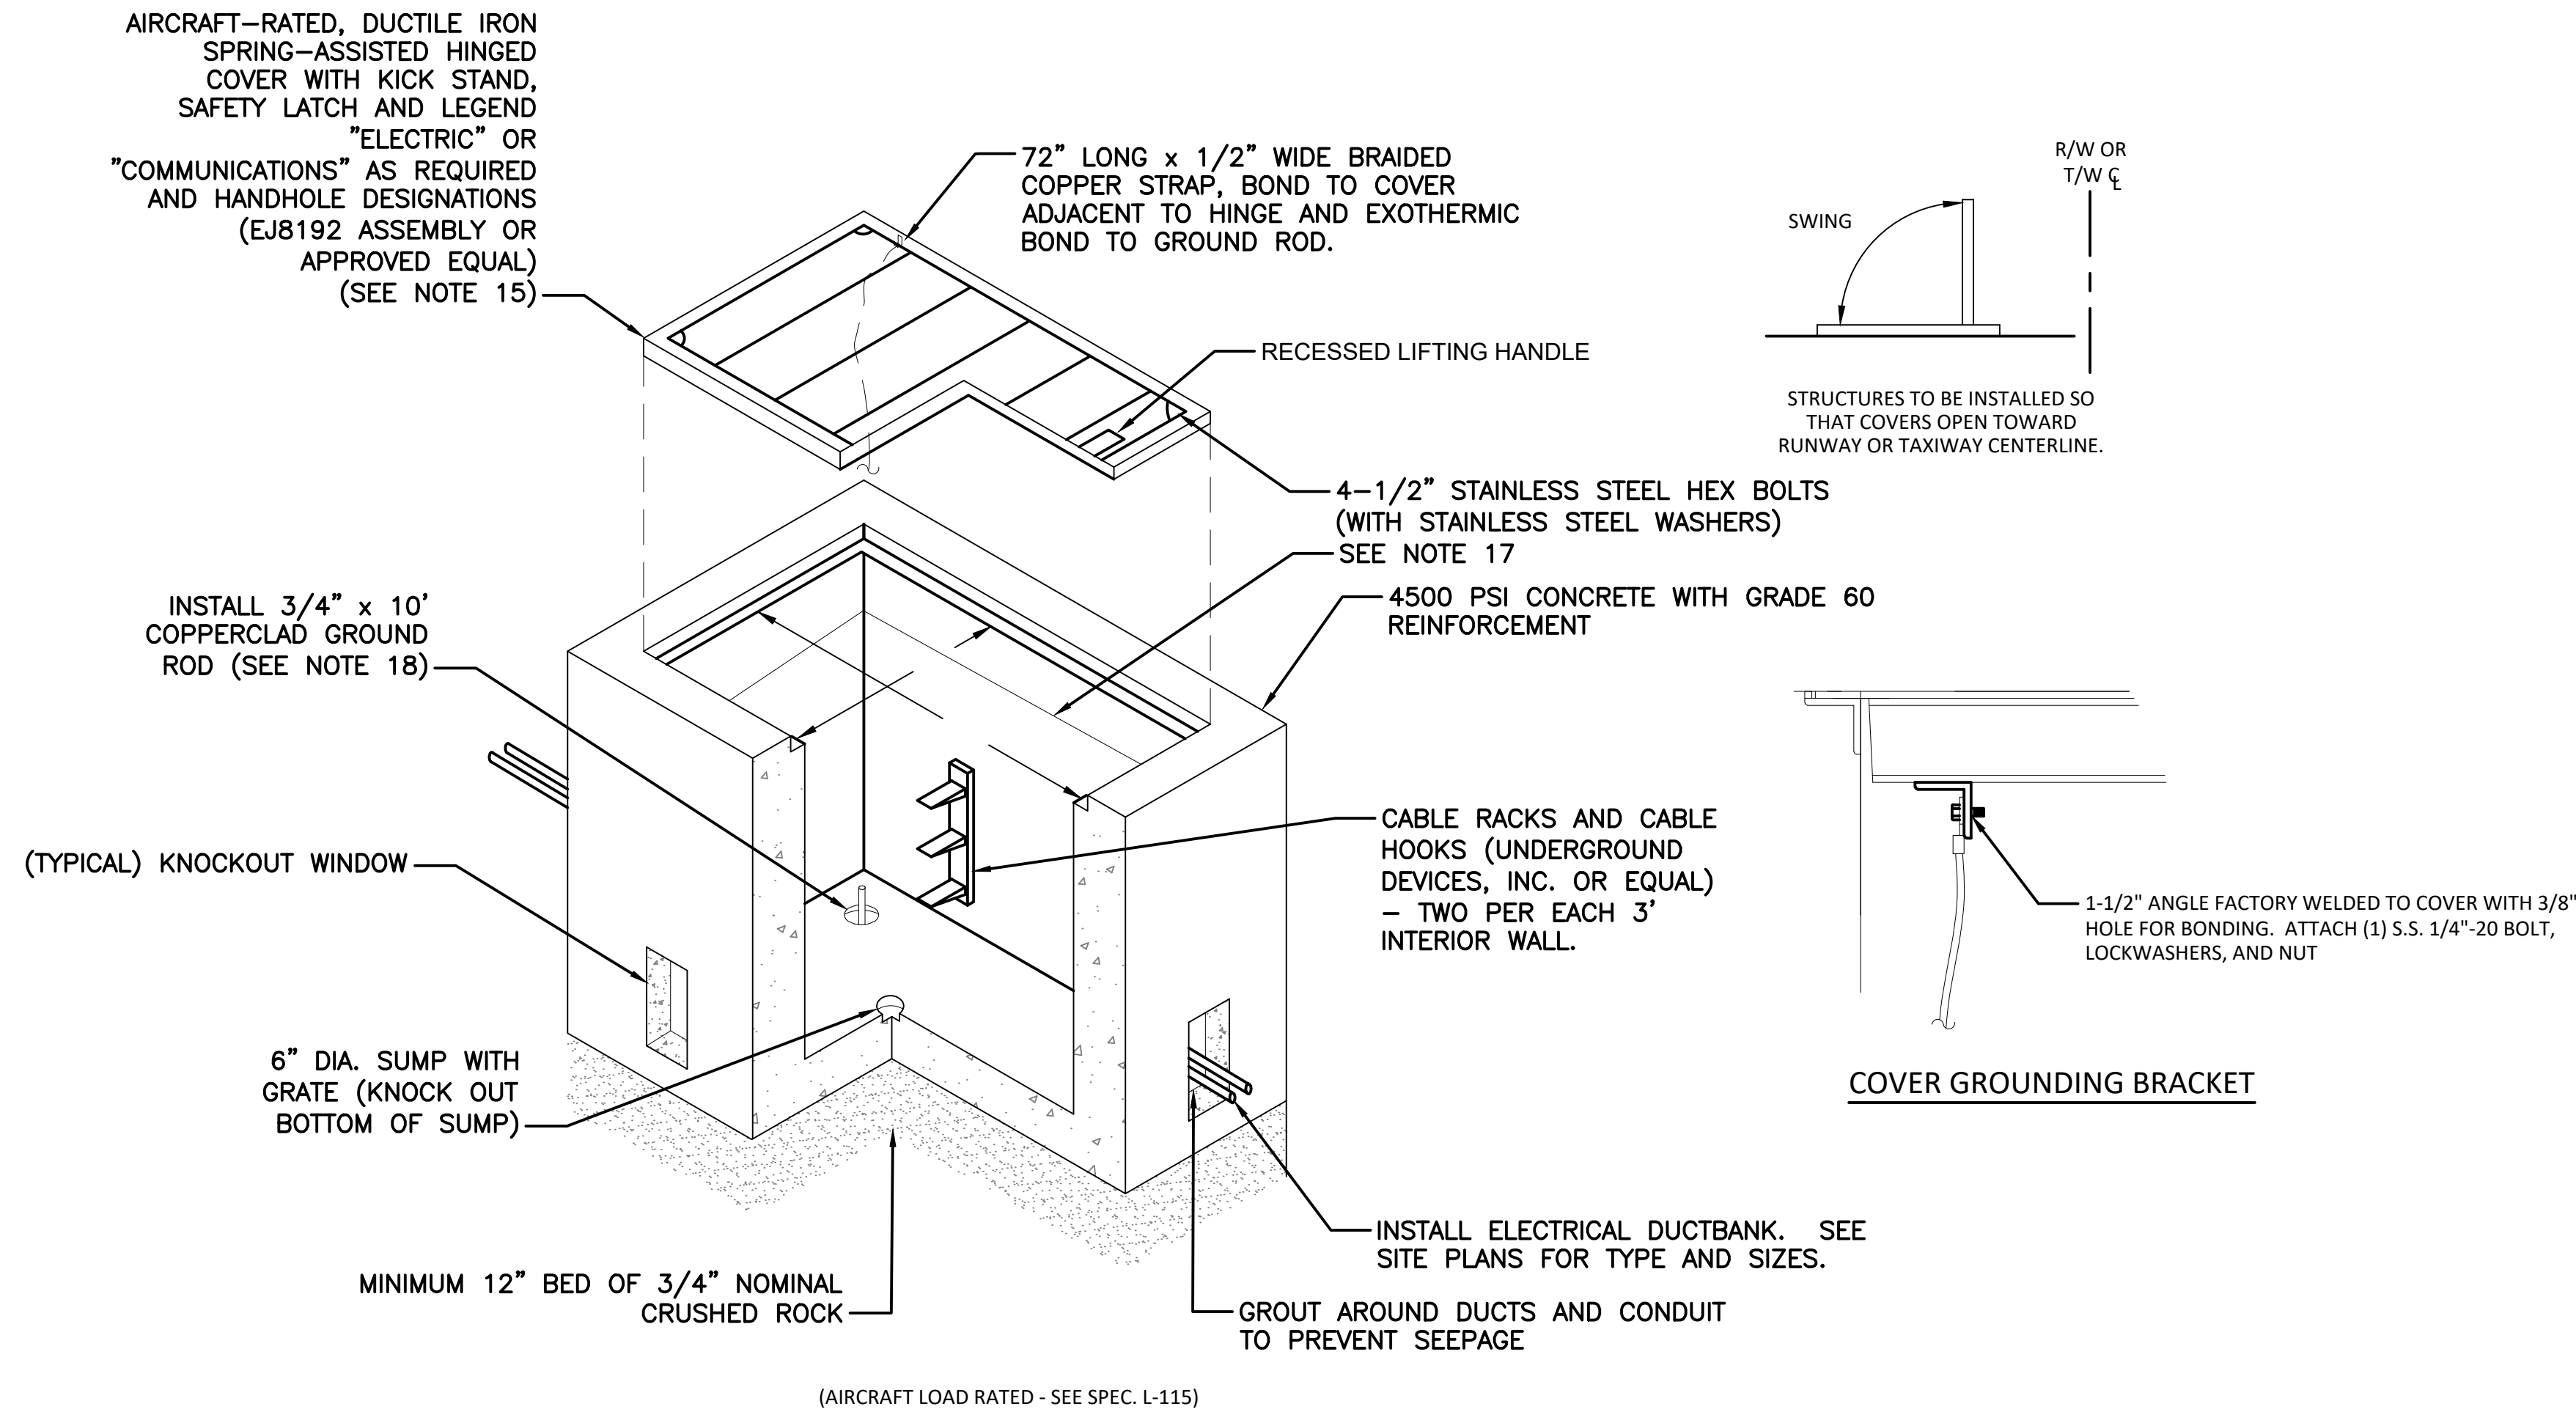

571
TYP

2'x3'x3' HANDHOLE DETAIL

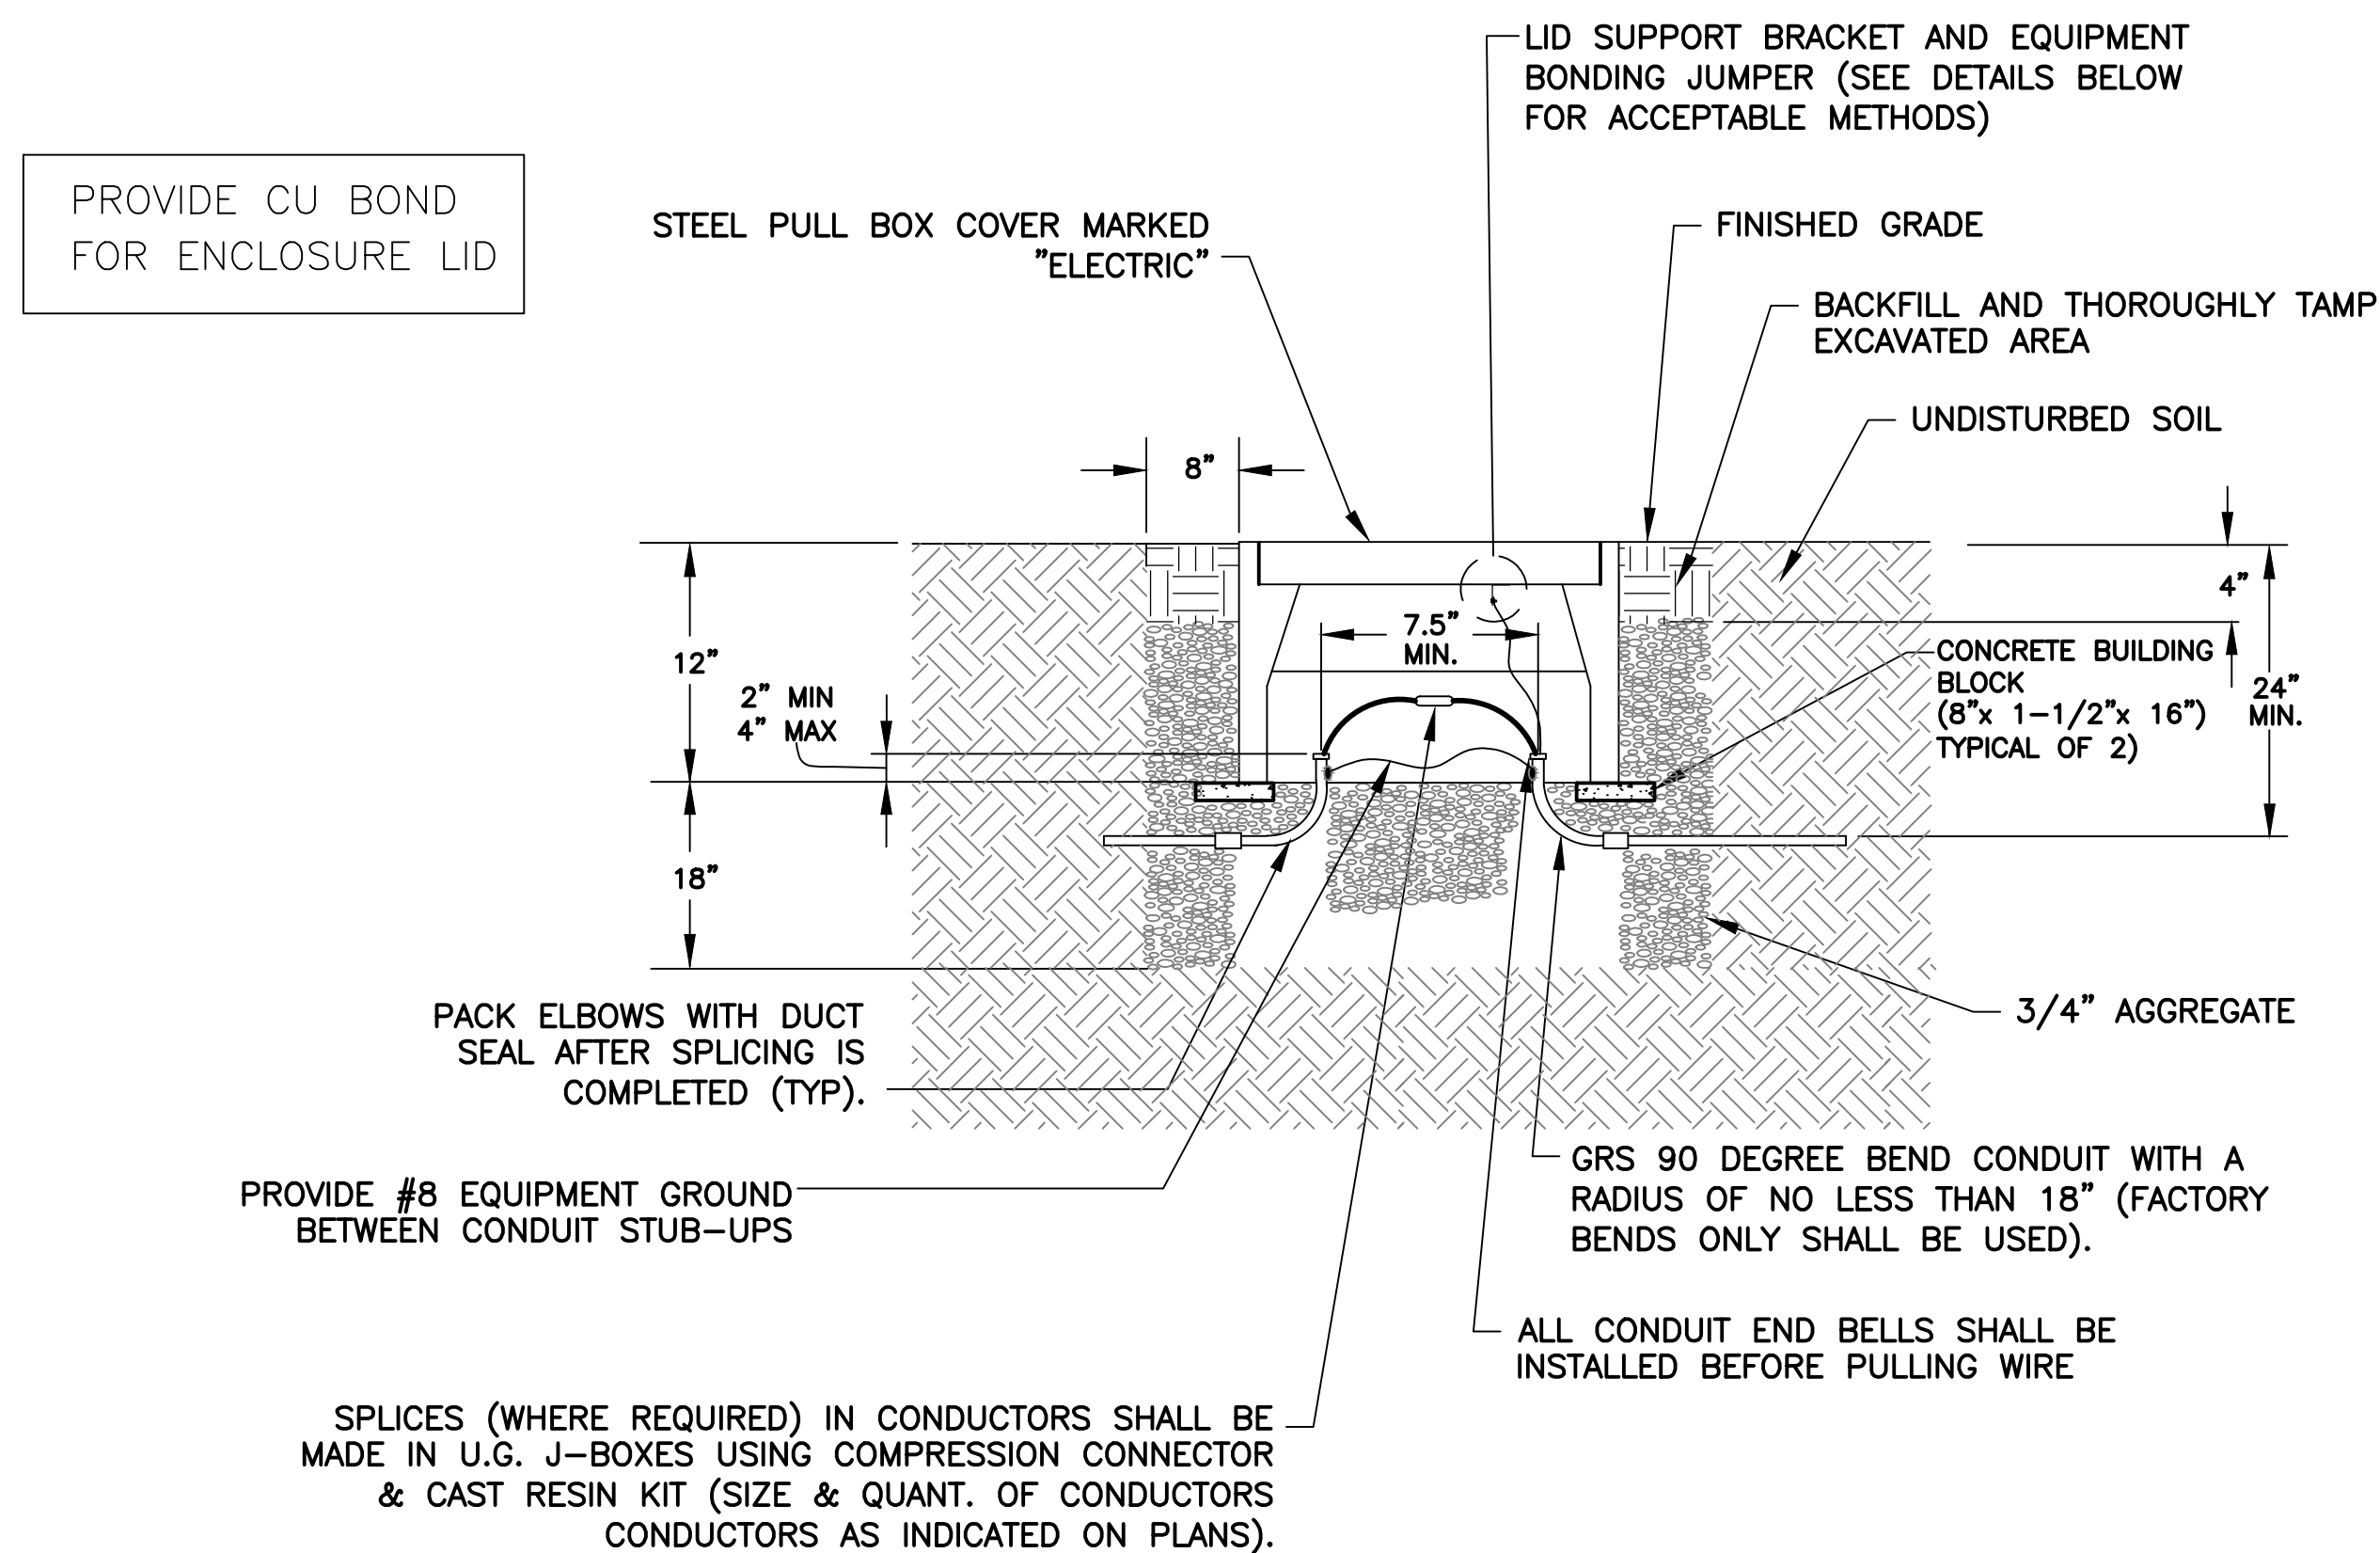


572
TYP

UNDERGROUND CONCRETE JUNCTION/PULL BOX DETAIL


GENERAL HANDHOLE INSTALLATION NOTES

- PRE-CAST AIRCRAFT-RATED CONCRETE HANDHOLE AND DUCTILE IRON COVER SHALL BE DESIGNED FOR A 60 KIPS CONCENTRATED WHEEL LOAD OVER A 12" X 24" AREA, OLD CASTLE PRE-CAST CONCRETE PRODUCTS OR APPROVED EQUAL.
- ALL CABLE THOUGH HANDHOLE SHALL HAVE SUFFICIENT SLACK SO CABLE AND CONNECTOR CAN BE BROUGHT TO SURFACE FOR SPLICING, PROVIDE MINIMUM TWELVE (12) FEET OF SLACK FOR EACH CABLE ENTERING HANDHOLE.
- EACH CABLE SHALL BE IDENTIFIED WITH CIRCUIT TAPE AND WIRE TAGS GIVING CIRCUIT IDENTIFICATION (BRADY #PWC-PK-6 OR APPROVED EQUAL).
- RACK AND SECURE ALL CABLES.
- TAG LIGHTING CIRCUIT CABLES IN ALL CONCRETE STRUCTURES (TWO REQUIRED PER CABLE).
- AT GROUND ROD OPENING, DRIVE GROUND ROD INTO EARTH LEAVING SIX (6) INCHES EXTENDING ABOVE FLOOR. SEAL HOLE WATERTIGHT WITH PORTLAND CEMENT GROUT AROUND ROD. DO NOT INSTALL THROUGH DRAIN SUMP.
- SUBMIT LAYOUT OF EACH HANDHOLE FOR APPROVAL BY ENGINEER, INDICATING ELECTRICAL DUCT, CONDUIT AND SPARE STUBOUTS.
- PROVIDE HANDHOLES WITH WATERTIGHT SPARE DUCT SLOTS IN EACH EMPTY FACE.
- EXCAVATION AND BACKFILL NECESSARY FOR THE CONSTRUCTION OF THE HANDHOLE SHALL BE PERFORMED IN ACCORDANCE WITH THE SPECIFICATION REQUIREMENTS.
- PROVIDE END BELLS FINISHED FLUSH WITH INTERIOR WALLS AND NON-SHRINK GROUT AROUND EACH CONDUIT ENTERING THE HANDHOLE VIA A CONDUIT STUBOUT.
- COVER SHALL BE 1" MAXIMUM ABOVE FINISHED GRADE. AREA SURROUNDING HANDHOLE SHALL BE GRADED TO DRAIN AWAY FROM HANDHOLE - INCIDENTAL (NP).
- BOND AND GROUND COVER AND FRAME TO ROD USING BRAIDED COPPER GROUND STRAP EQUIVALENT AMPACITY TO #2 AWG STRANDED COPPER WIRE.
- GRADE THE AREA AROUND THE HANDHOLE, 10' IN ALL DIRECTIONS, SUCH TO PREVENT WATER AND DIRT ACCUMULATION ACROSS THE TOP OF THE COVER AND ALLOW WATER TO DRAIN AWAY FROM THE HANDHOLE - INCIDENTAL (NP).
- INSTALL PULLING IRONS IN EACH FACE.
- PROVIDE MANUFACTURER DRAWINGS AND STRUCTURAL CALCULATIONS FOR ALL CONCRETE ELEMENTS OF HANDHOLES AND FABRICATED AIRCRAFT-RATED COVERS.
- CONNECT COUNTERPOISE TO GROUND ROD IN HANDHOLE. ROUTE AROUND HANDHOLES.
- A GROUND BUS OF 4/0 BARE COPPER SHALL BE EXOTHERMICALLY BONDED TO THE GROUND ROD AND LOOP THE CONCRETE STRUCTURE WALLS. THE GROUND BUS SHALL BE A MINIMUM OF ONE (1) FOOT (30 CM) ABOVE THE FLOOR OF THE STRUCTURE AND SEPARATE FROM OTHER CABLES. NO. 2 AMERICAN WIRE GAUGE (AWG) BARE COPPER PIG TAILS SHALL BOND THE GROUNDING BUS TO ALL CABLE TRAYS AND OTHER METAL HARDWARE WITHIN THE CONCRETE STRUCTURE. CONNECTIONS TO THE GROUNDING BUS SHALL BE EXOTHERMIC. IF AN EXOTHERMIC WELD IS NOT POSSIBLE, CONNECTION TO THE GROUNDING BUS SHALL BE MADE BY USING CONNECTOR APPROVED FOR DIRECT BURIAL IN SOIL OR CONCRETE PER UL 467. HARD CONNECTIONS MAY BE MECHANICAL USING A LUG DESIGNED FOR THAT PURPOSE.
- A GROUND ROD SHALL BE INSTALLED IN THE FLOOR OF ALL CONCRETE STRUCTURE SO THAT THE TOP OF ROD EXTENDS SIX (6) INCHES (150MM) ABOVE THE FLOOR. THE GROUND ROD SHALL BE INSTALLED WITHIN ONE (1) FOOT (30 CM) OF A CORNER OF THE CONCRETE STRUCTURE. GROUND RODS SHALL BE INSTALLED PRIOR TO CASTING THE BOTTOM SLAB. WHERE THE SOIL CONDITION DOES NOT PERMIT DRIVING THE GROUND ROD INTO THE EARTH WITHOUT DAMAGE TO THE GROUND ROD, THE CONTRACTOR SHALL DRILL A FOUR (4) INCH (100 MM) DIAMETER HOLE INTO THE EARTH TO RECEIVE THE GROUND ROD. THE HOLE AROUND THE GROUND ROD SHALL BE FILLED THROUGHOUT ITS LENGTH, BELOW SLAB, WITH PORTLAND CEMENT GROUT. GROUND RODS SHALL BE INSTALLED IN PRECAST BOTTOM SLAB OF STRUCTURES BY DRILLING A HOLE THROUGH BOTTOM SLAB AND INSTALLING THE GROUND ROD. BOTTOM SLAB PENETRATION SHALL BE SEALED WATERTIGHT WITH PORTLAND CEMENT GROUT AROUND THE GROUND ROD.

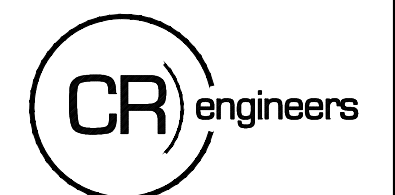


16719 East Palisades Blvd., Suite 202
Fountain Hills, AZ 85268
Phone: (480) 816-5541
Fax: (480) 816-5540

PER CITY OF PHOENIX CODE CHAPTER 2, SECTION 2-28. THESE PLANS ARE FOR OFFICIAL USE ONLY AND MAY NOT BE SHARED WITH OTHERS EXCEPT AS REQUIRED TO FULFILL THE OBLIGATIONS OF CONTRACTOR'S CONTRACT WITH THE CITY OF PHOENIX.

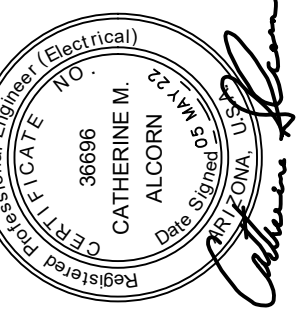

PER CITY OF PHOENIX CITY CODE CHAPTER 2, SECTION 2-28, THESE PLANS ARE FOR OFFICIAL USE ONLY AND MAY NOT BE SHARED WITH OTHERS EXCEPT AS REQUIRED TO FULFILL THE OBLIGATIONS OF YOUR CONTRACT WITH THE CITY OF PHOENIX.			
NO.	REVISIONS /	SUBMISSIONS	DATE

Designed by: SW	Drawn by: JCA
Checked by: CA	Date: May 2022
Dwg scale:	

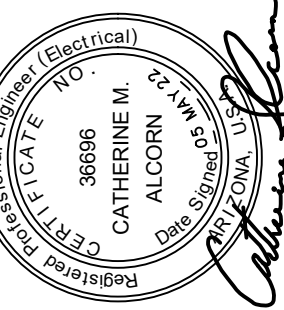


CONTRACT WITH THE CITY OF PHOENIX			
		REVISIONS / SUBMISSIONS	DATE

AV41000077 FAA/ADOT

CIP NO (S): AV41000077 FAA/ADOT

ELEVATED TAXIWAY EDGE LIGHT AND APRON LIGHT DETAILS

Sheet 56 of 61

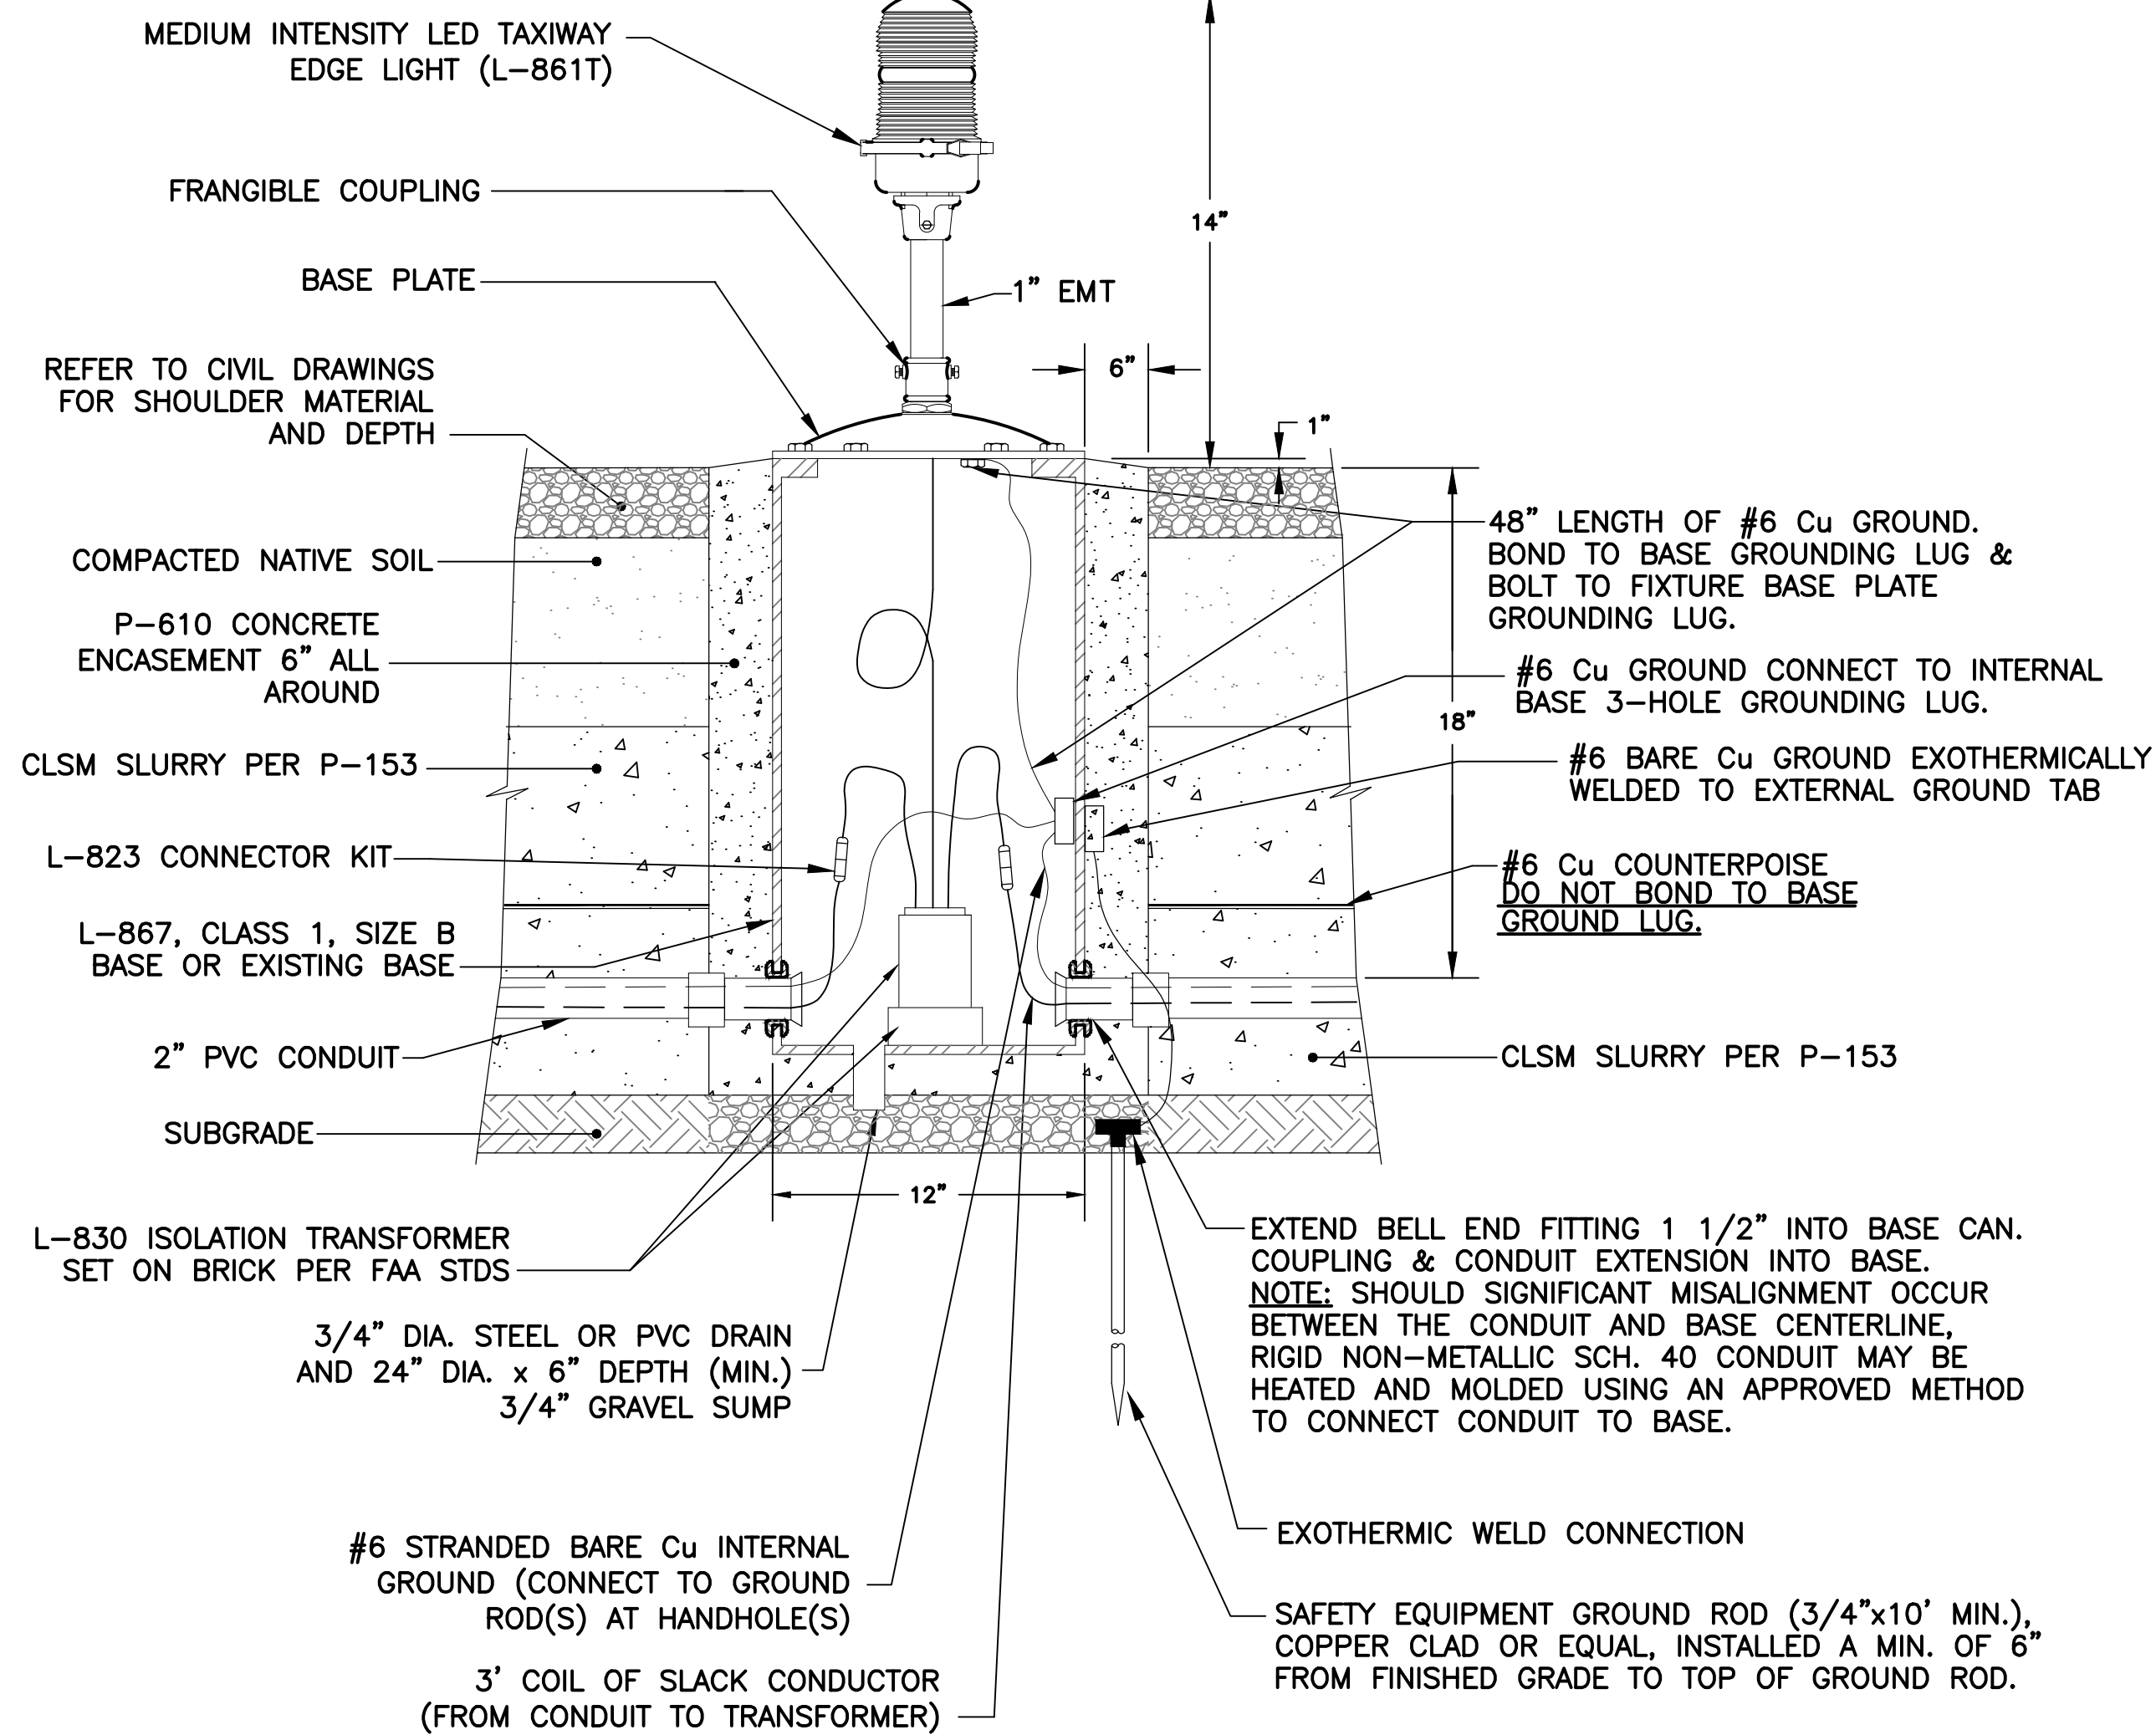

 ELEVATED TAXIWAY EDGE LIGHT DETAIL

DESIGN CRITERIA

–DESIGN STANDARD: AASHTO STANDARD
(SPECIFICATIONS FOR STRUCTURAL SUPPORTS FOR
HIGHWAYS SIGNS, LUMINAIRES, AND TRAFFIC SIGNALS,
2008 5TH EDITION WITH INTERIMS TO 2011.


-CONCRETE SHALL HAVE A MINIMUM 28-DAY COMPRESSIVE STRENGTH $F'_c = 4000$ PSI.

—BASIC WIND SPEED: 90 MPH (3 SECOND GUST)

—IMPORTANCE FACTOR: 1.0

—ELEVATION USED FOR WIND PRESSURE DESIGN: 80 FT.

-POLE DESIGN ATTACHMENTS OF ALL MEMBERS AND ANCHOR BOLTS SHALL BE DESIGNED BY POLE MANUFACTURER TO SATISFY THE ABOVE DESIGN CRITERIA.

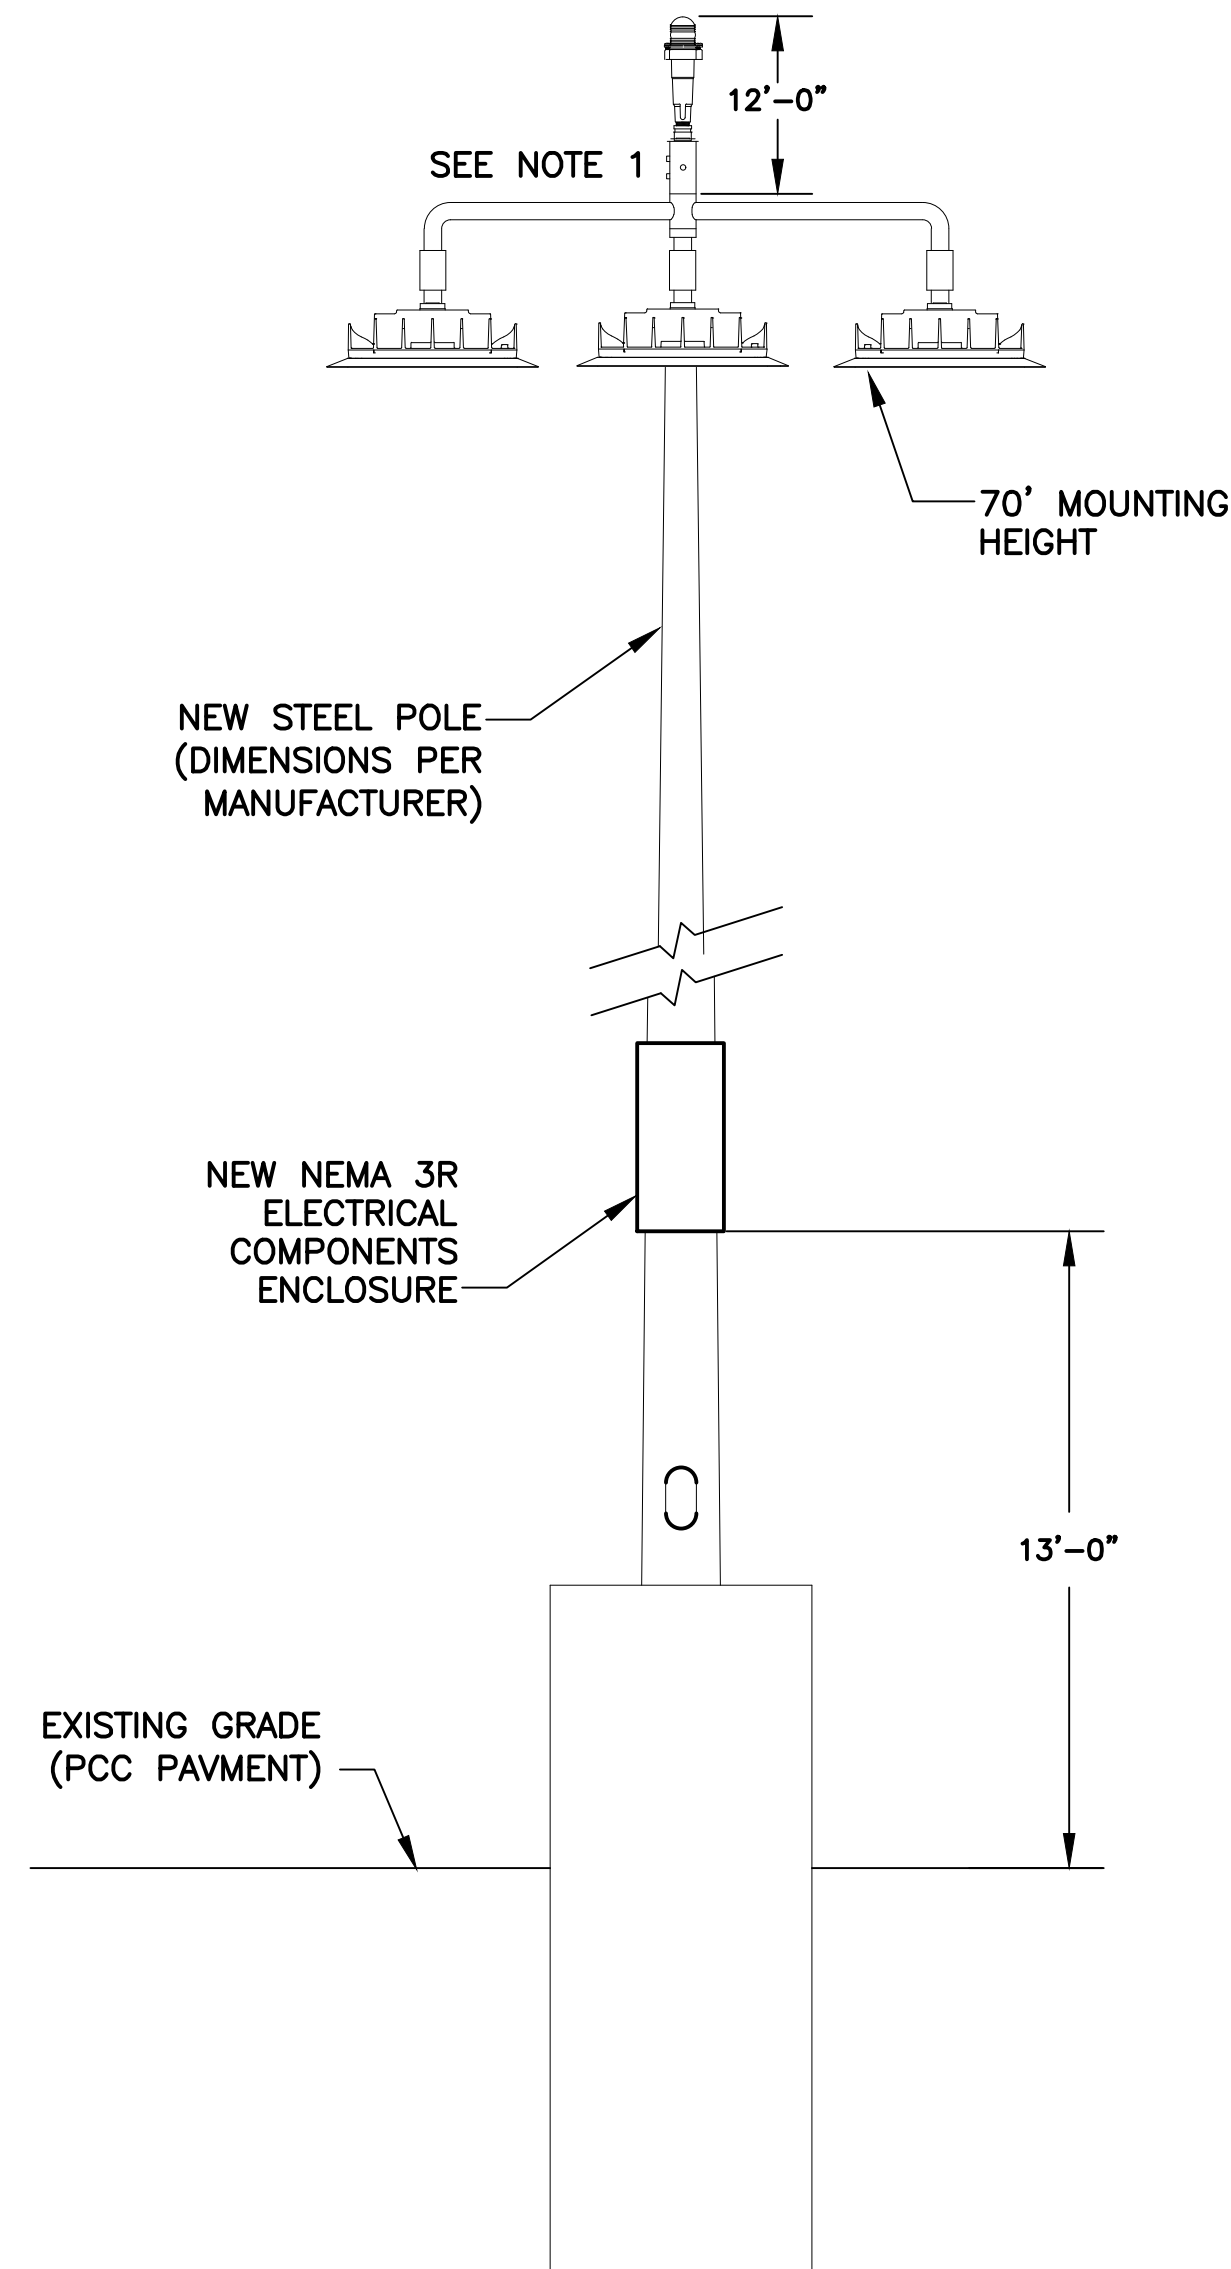


2 APRON LIGHTING
TYP (BID ALT #1)

1. NOTES

CONTRACTOR TO PROVIDE NEW FAA APPROVED 120V LED OBSTRUCTION LIGHT FIXTURES
MOUNTING ASSEMBLIES AND INSTALLATION.

2. APRON LIGHTING OR POLE MANUFACTURER SHALL PROVIDE MOUNTING PROVISIONS FOR OBSTRUCTION LIGHTS.

3. CONTRACTOR SHALL COORDINATE WITH APRON LIGHTING MANUFACTURER TO VERIFY THAT PROVISIONS FOR 480V TO 120V STEP DOWN TRANSFORMERS AND ANY PRE-WIRED HARNESS ARE INCLUDED WITH DRIVER AND POLE ASSEMBLIES FOR FEEDING OBSTRUCTION LIGHTS. IF NOT PROVISIONS ARE INCLUDED IN OEM EQUIPMENT, THE CONTRACTOR WILL BE REQUIRED TO PROVIDE AND INSTALL.

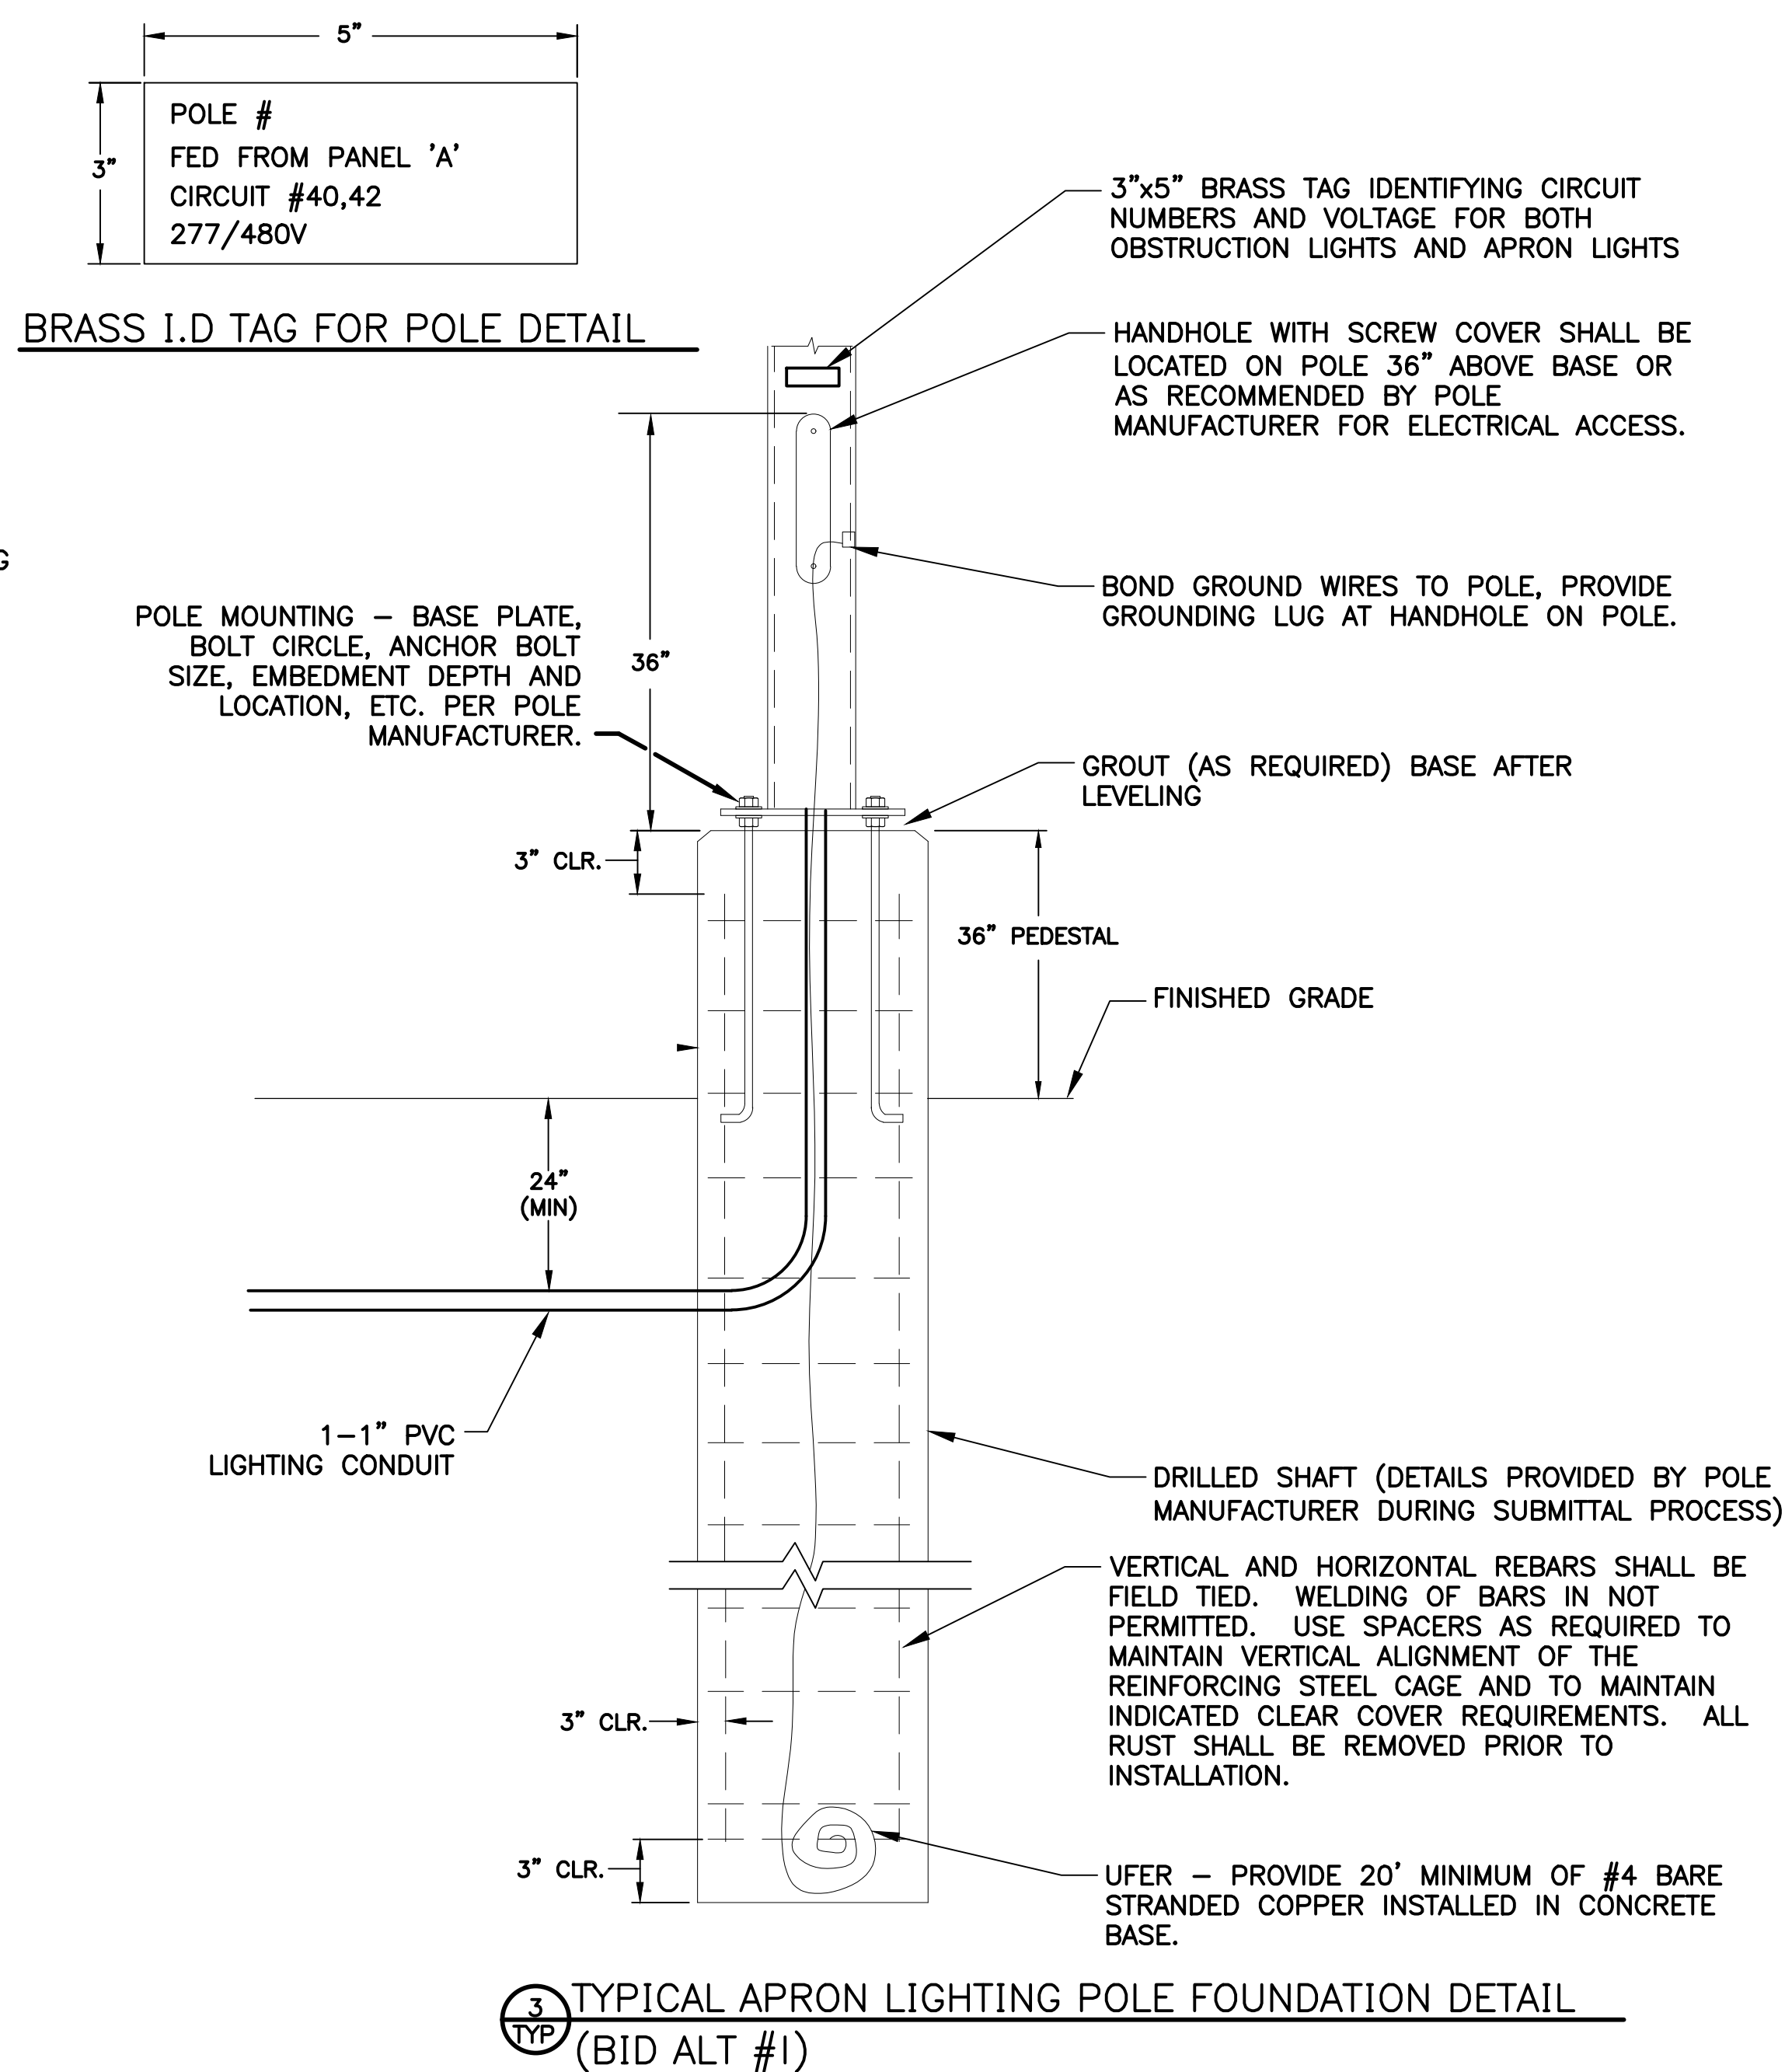

3
TYP

TYPICAL APRON LIGHTING POLE FOUNDATION DETAIL
(BID ALT #1)

NOTE FOR DETAIL 3

1. THE POLE CONCRETE BASE DETAIL IS SHOWN FOR ELECTRICAL ROUGH-IN AND SHALL NOT BE USED FOR THE ACTUAL BASE CONSTRUCTION. STRUCTURAL DETAILS PROVIDED BY MANUFACTURER, SEALED AND SIGNED BY LICENSED ARIZONA STRUCTURAL ENGINEER.

2. GENERAL DIMENSIONS FOR 120' POLES ARE 4' DIAMETER X 22' EMBEDMENT DEPTH.

LIGHTING FIXTURE SCHEDULE (BID ALT #1)						
DRAWING SYMBOL CALLOUT	PICTORIAL	LAMPS	MOUNTING	DESCRIPTION	MANUFACTURER MODEL No.	REMARKS
		3-LED 240 WATTS 5700 CCT 75 CRI	POLE	SLIM, LOW PROFILE DESIGN: LOW COPPER DIECAST ALUMINUM, POWDER-COAT PAINTED HOUSING, TOOL LESS LAMP COVER, 1020ma CURRENT FEED, UL LISTED, IP65 RATED,	MUSCO LIGHTING TLC-LED-600	FIXTURE OR DRIVER CABINET SHALL BE PROVIDED WITH SEVEN PIN HUBBEL/GATEWAY CONTROL AND TRANSFORMER TO FEED OBSTRUCTION LIGHT.
					OR EQUAL	

PER CITY OF PHOENIX CODE CHAPTER 2, SECTION 2-28. THESE PLANS ARE FOR OFFICIAL USE ONLY AND MAY NOT BE SHARED WITH OTHERS EXCEPT AS REQUIRED TO FULFILL THE OBLIGATIONS OF CONTRACTOR'S CONTRACT WITH THE CITY OF PHOENIX.



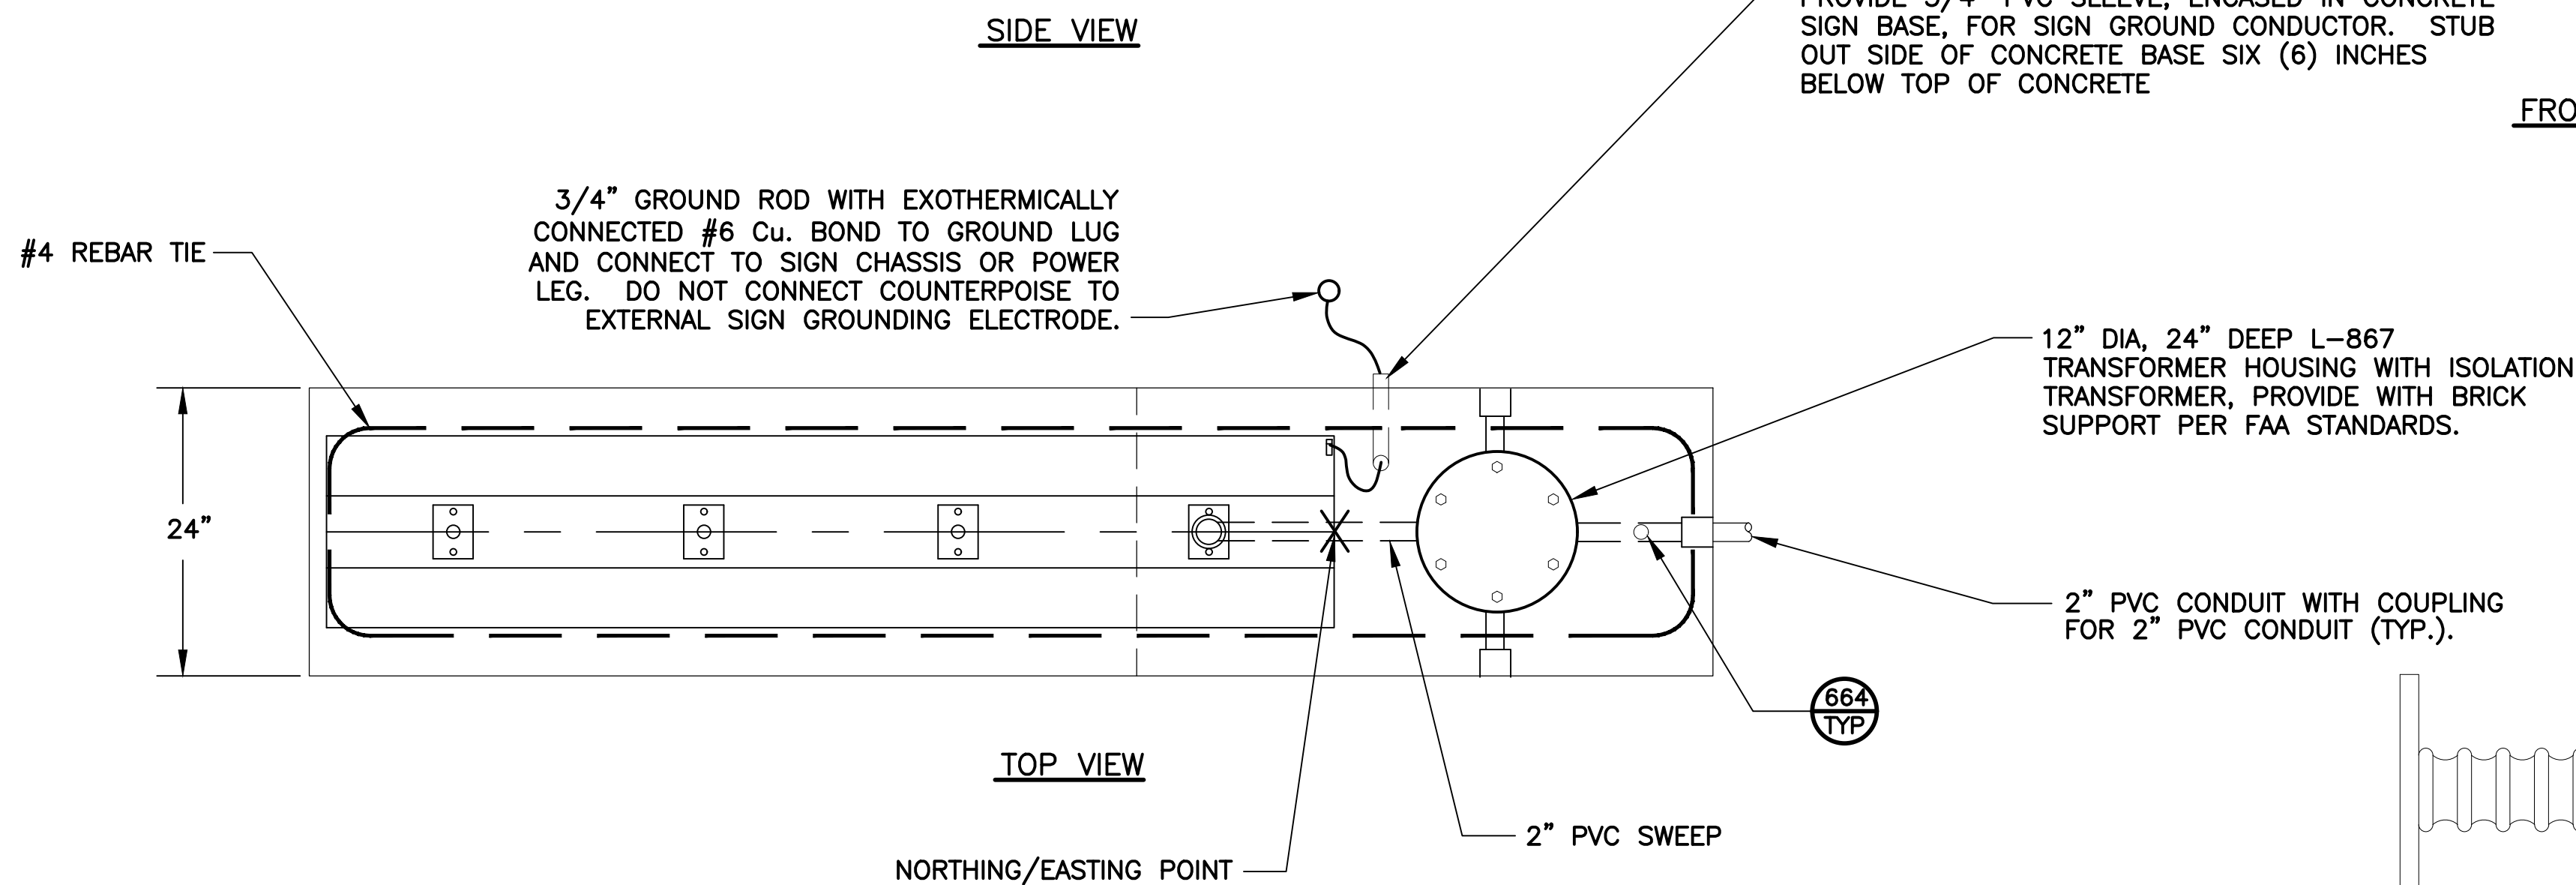
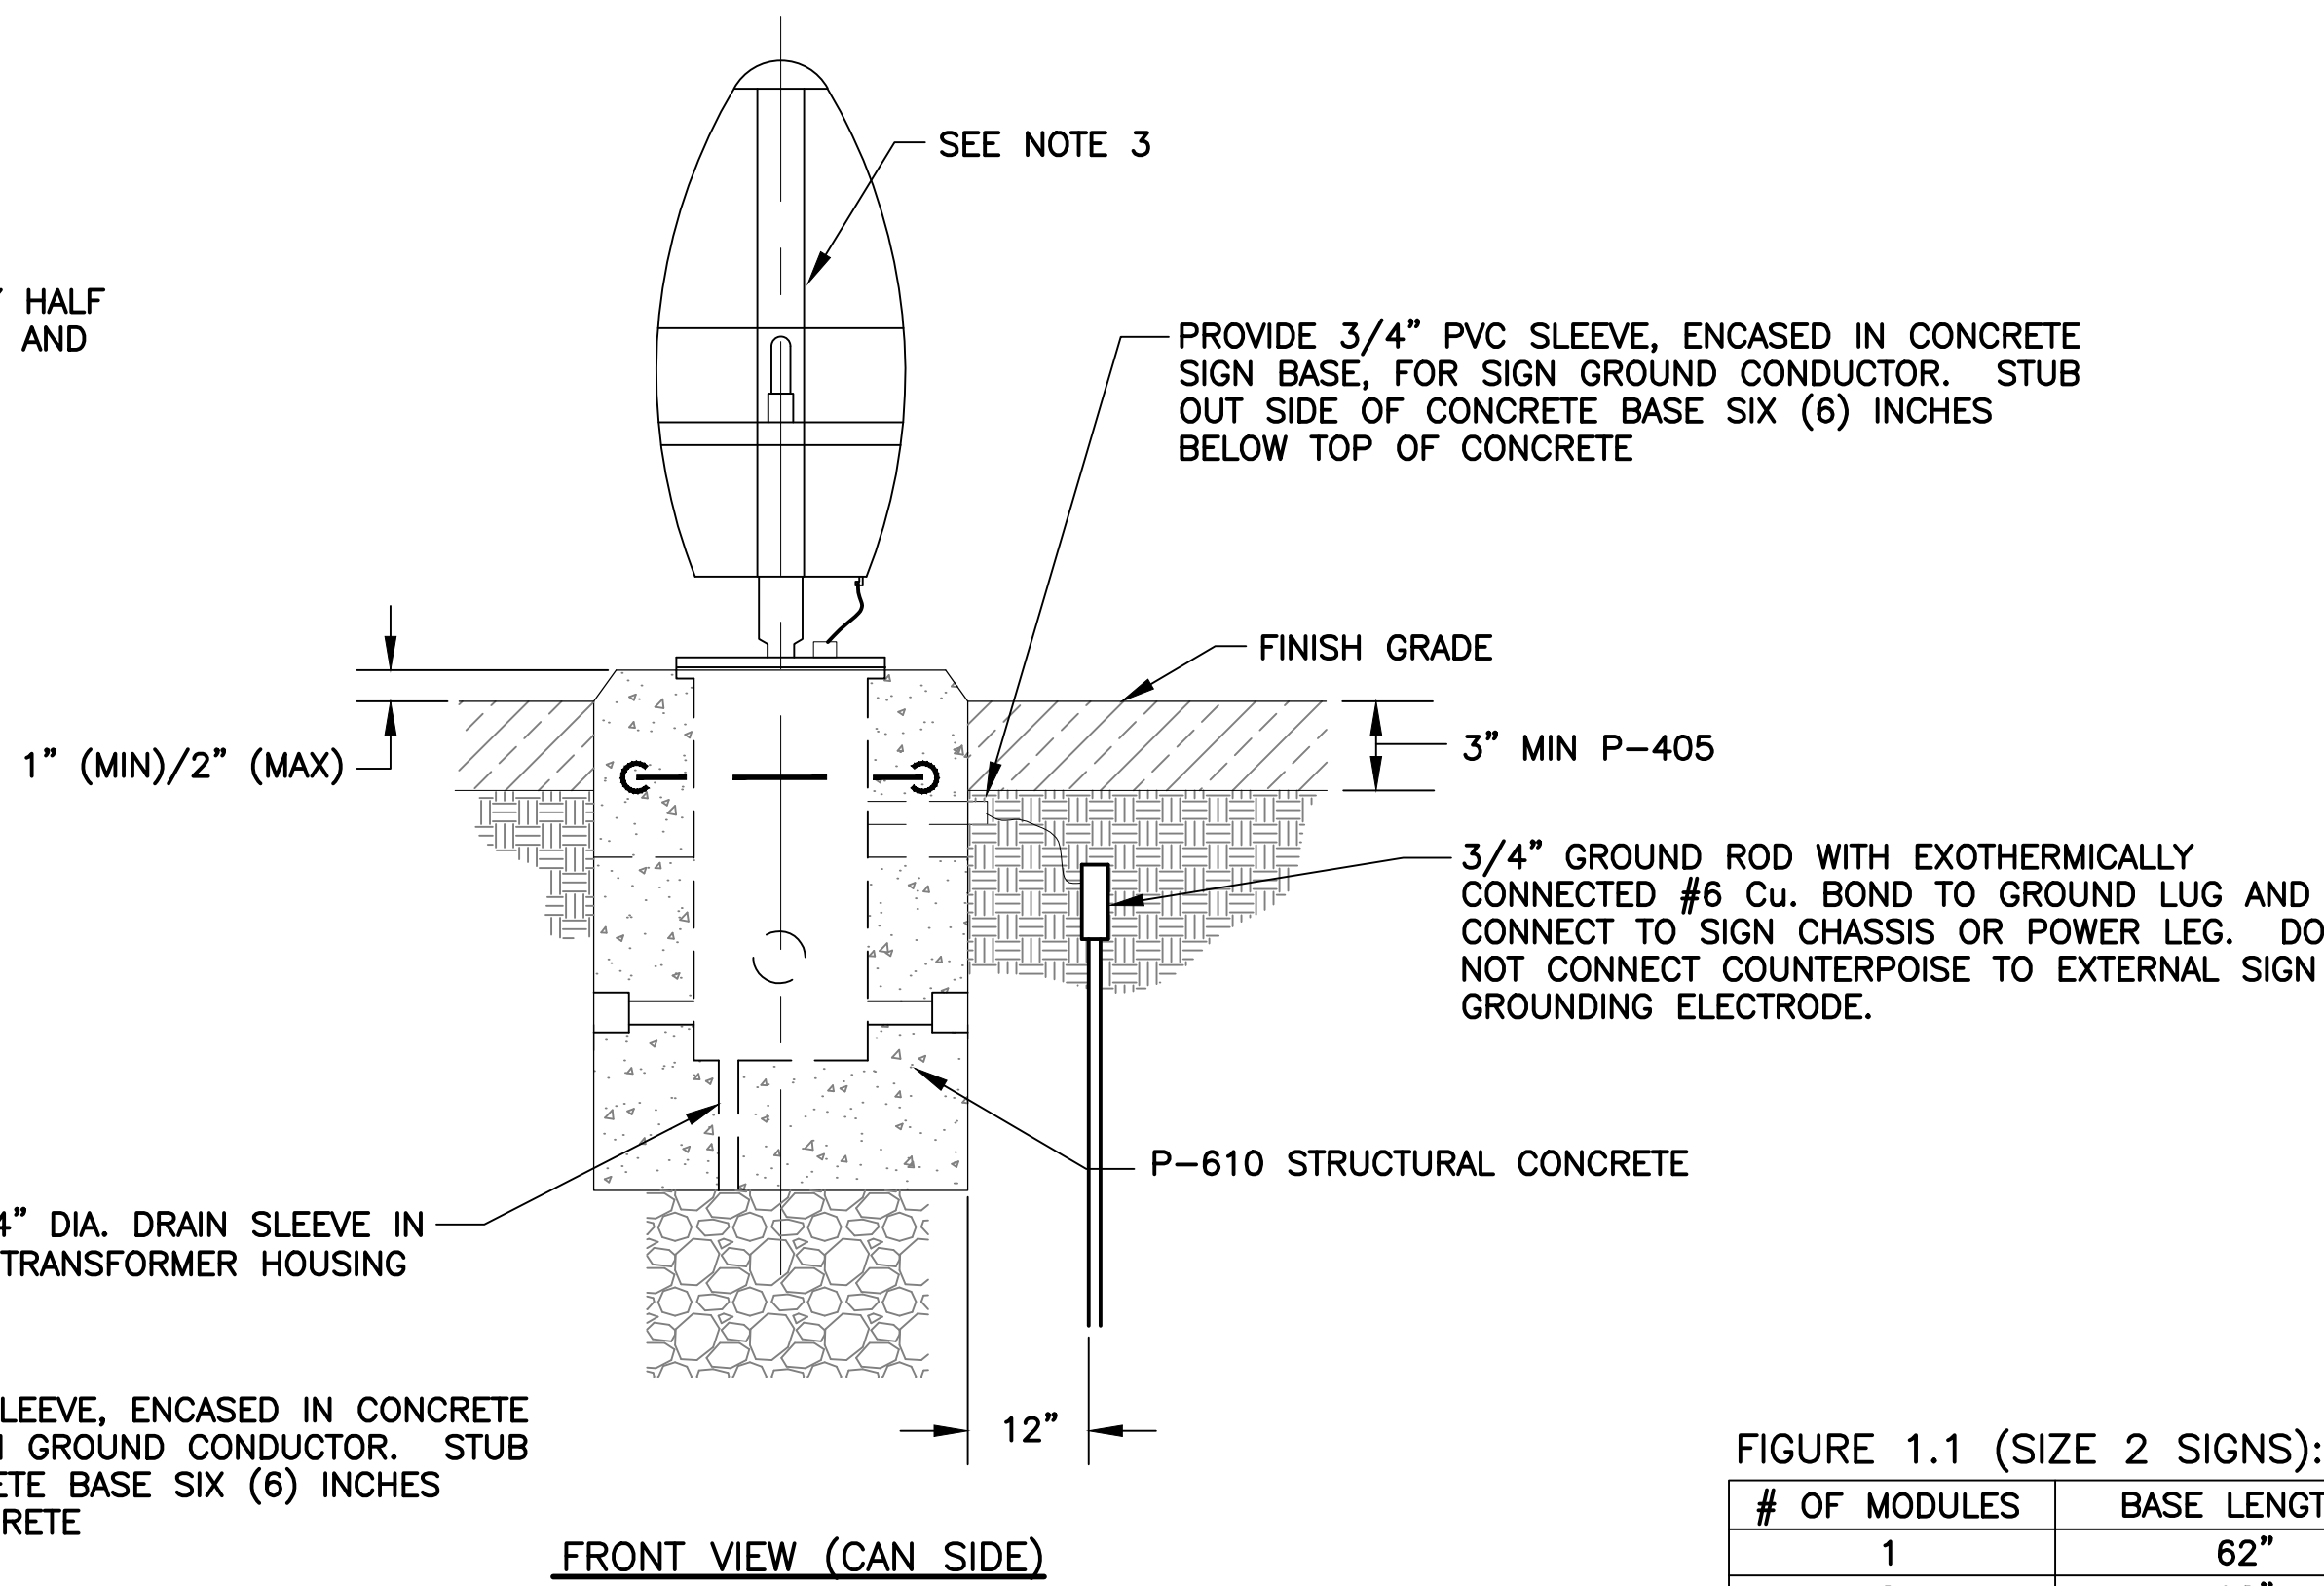
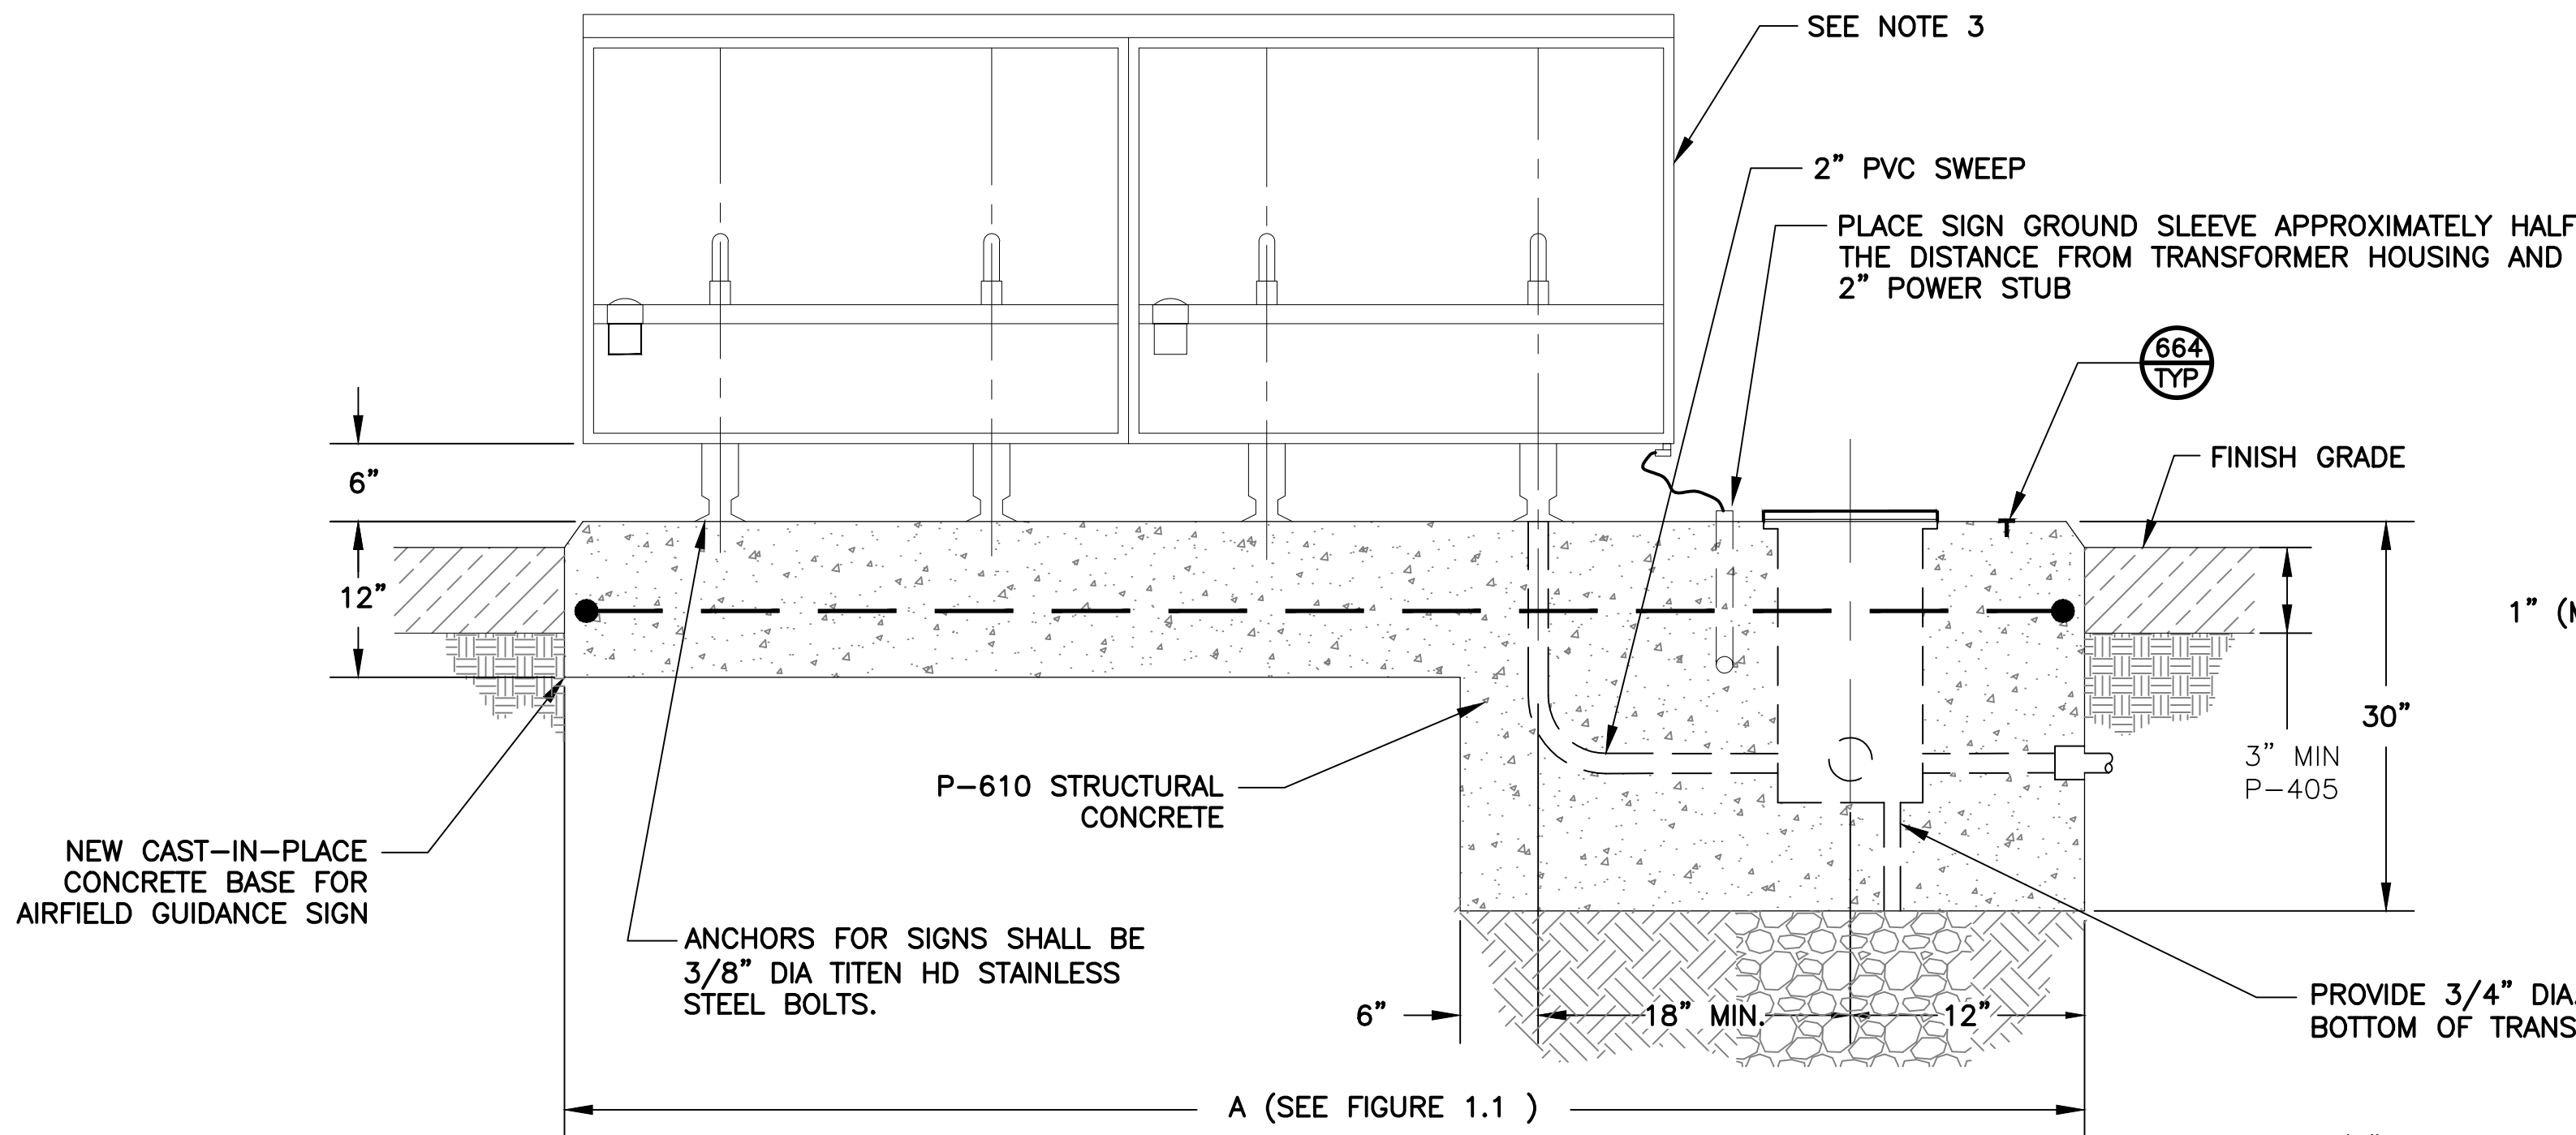


FIGURE 1.1 (SIZE 2 SIGNS):

# OF MODULES	BASE LENGTH (A)
1	62"
2	98"
3	135"
4	171"

* ALL LENGTHS SHOWN ARE MINIMUM

NEW CAST-IN-PLACE CONCRETE BASE FOR AIRFIELD GUIDANCE SIGN

NOTES

1. NEW CAST-IN-PLACE CONCRETE BASE SHOWN WITH A TWO MODULE SIGN FOR ILLUSTRATIVE PURPOSES ONLY. SEE FIGURE 1.1 FOR ACTUAL LENGTH OF BASE NEEDED FOR MULTIPLE MODULE SIGNS.
2. TRANSFORMER HOUSING SHALL BE ORIENTED AT TAXIWAY/RUNWAY EDGE PER COP/GYR STANDARDS.
3. SIGNS SHALL BE EQUIPPED WITH DISCONNECTING SWITCH AND WEATHERPROOF COVER ON INBOARD OF SIGN.


SIGN HEIGHTS AND LOCATION DISTANCES FOR TAXIWAY GUIDANCE SIGNS

SIGN SIZE	LEGEND HEIGHT	LEGEND PANEL HEIGHT	INSTALLED * (MAX.)	PERPENDICULAR DISTANCE FROM DEFINED PAVEMENT EDGE TO NEAR SIDE OF SIGN
2	15"	24"	36"	20' - 35'

* THE HEIGHT REFERRED TO IN THIS COLUMN IS THE DISTANCE FROM TOP OF THE SIGN TO GRADE MEASURED AT THE SIDE OF THE SIGN THAT IS NEAREST TO THE APPLICABLE RUNWAY, TAXIWAY, OR APRON. IN ACCORDANCE WITH PARAGRAPH 14, THIS HEIGHT SHOULD BE REDUCED, IF NECESSARY, TO PROVIDED THE REQUIRED 12-INCH CLEARANCE BETWEEN THE TOP OF THE SIGN AND THE CRITICAL AIRCRAFT.

(SEE FAA ADVISORY CIRCULAR 150/5340-18G FOR FURTHER INFORMATION AND CLARIFICATION)

SERVCO BRONZE MARKER


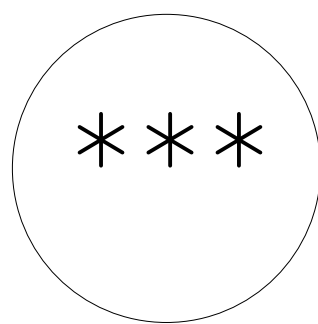


***= TWN
= SG
= RGL
= RW 3-21

CIRCUIT IDENTIFICATION MARKER



NOTE:

1. STAMP CIRCUIT IDENTIFICATION INTO BASE MARKER WITH 1/2" CHARACTERS.
2. PROVIDE CIRCUIT ID MARKERS AT NEW SIGN BASES AND JUNCTION CANS.

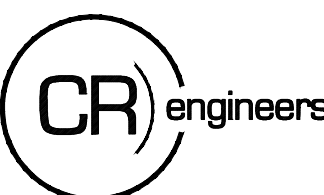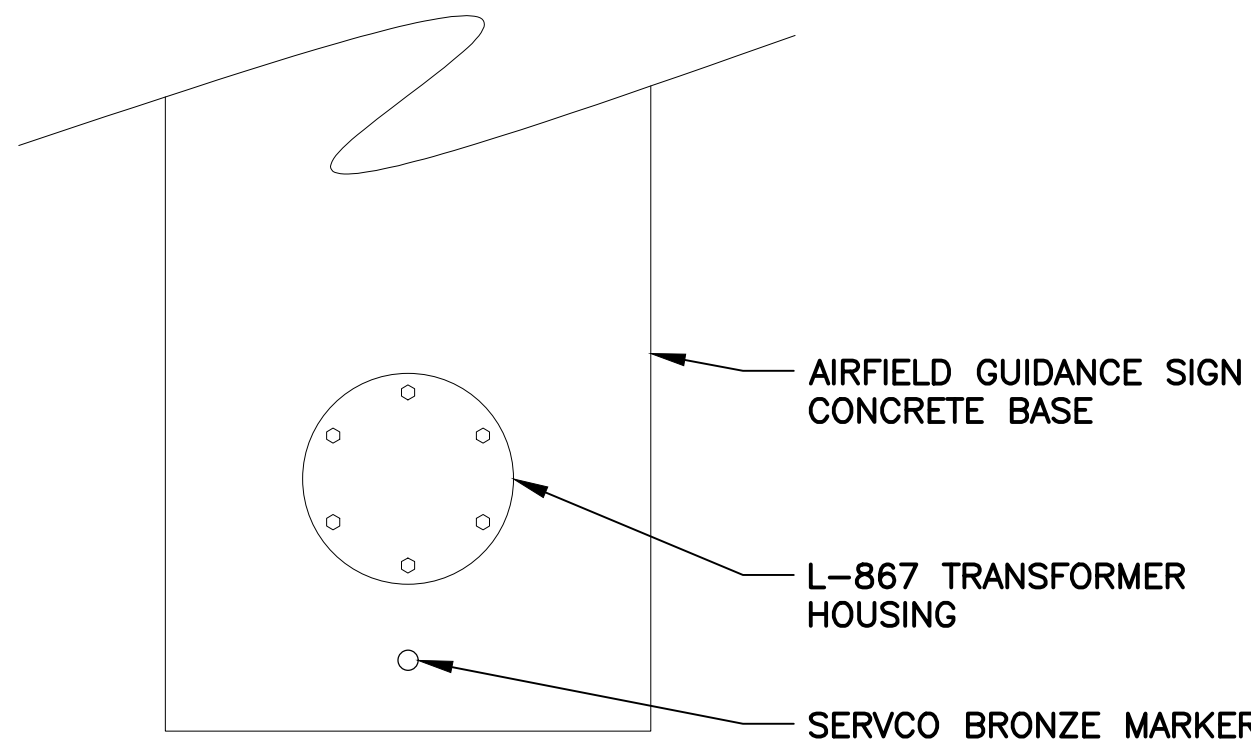

16719 East Palisades Blvd., Suite 202
Fountain Hills, AZ 85268
Phone: (480) 816-5541
Fax: (480) 816-5540

PER CITY OF PHOENIX CODE CHAPTER 2, SECTION 2-28. THESE PLANS ARE FOR OFFICIAL USE ONLY AND MAY NOT BE SHARED WITH OTHERS EXCEPT AS REQUIRED TO FULFILL THE OBLIGATIONS OF CONTRACTOR'S CONTRACT WITH THE CITY OF PHOENIX.

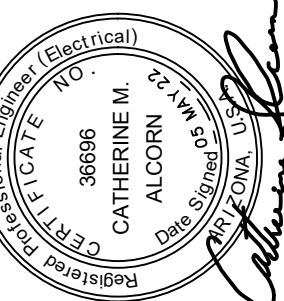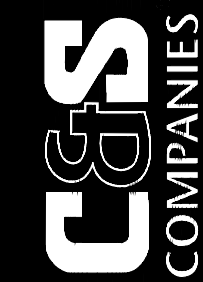

NO.	REVISIONS / SUBMISSIONS	DATE

PHX DOT CYR
CITY OF PHOENIX AVIATION DEPARTMENT
PHOENIX GOODYEAR AIRPORT
NEW APRON AND TAXIWAY CONNECTOR
AV41000077 FAA/ADOT


Designed by: SW	Drawn by: JBW
Checked by: CA	Date: May 2022
Dwg scale:	

AIRFIELD GUIDANCE SIGN
BASE DETAILS

Sheet
Reference
Number:


EA-506

Sheet 57 of 61

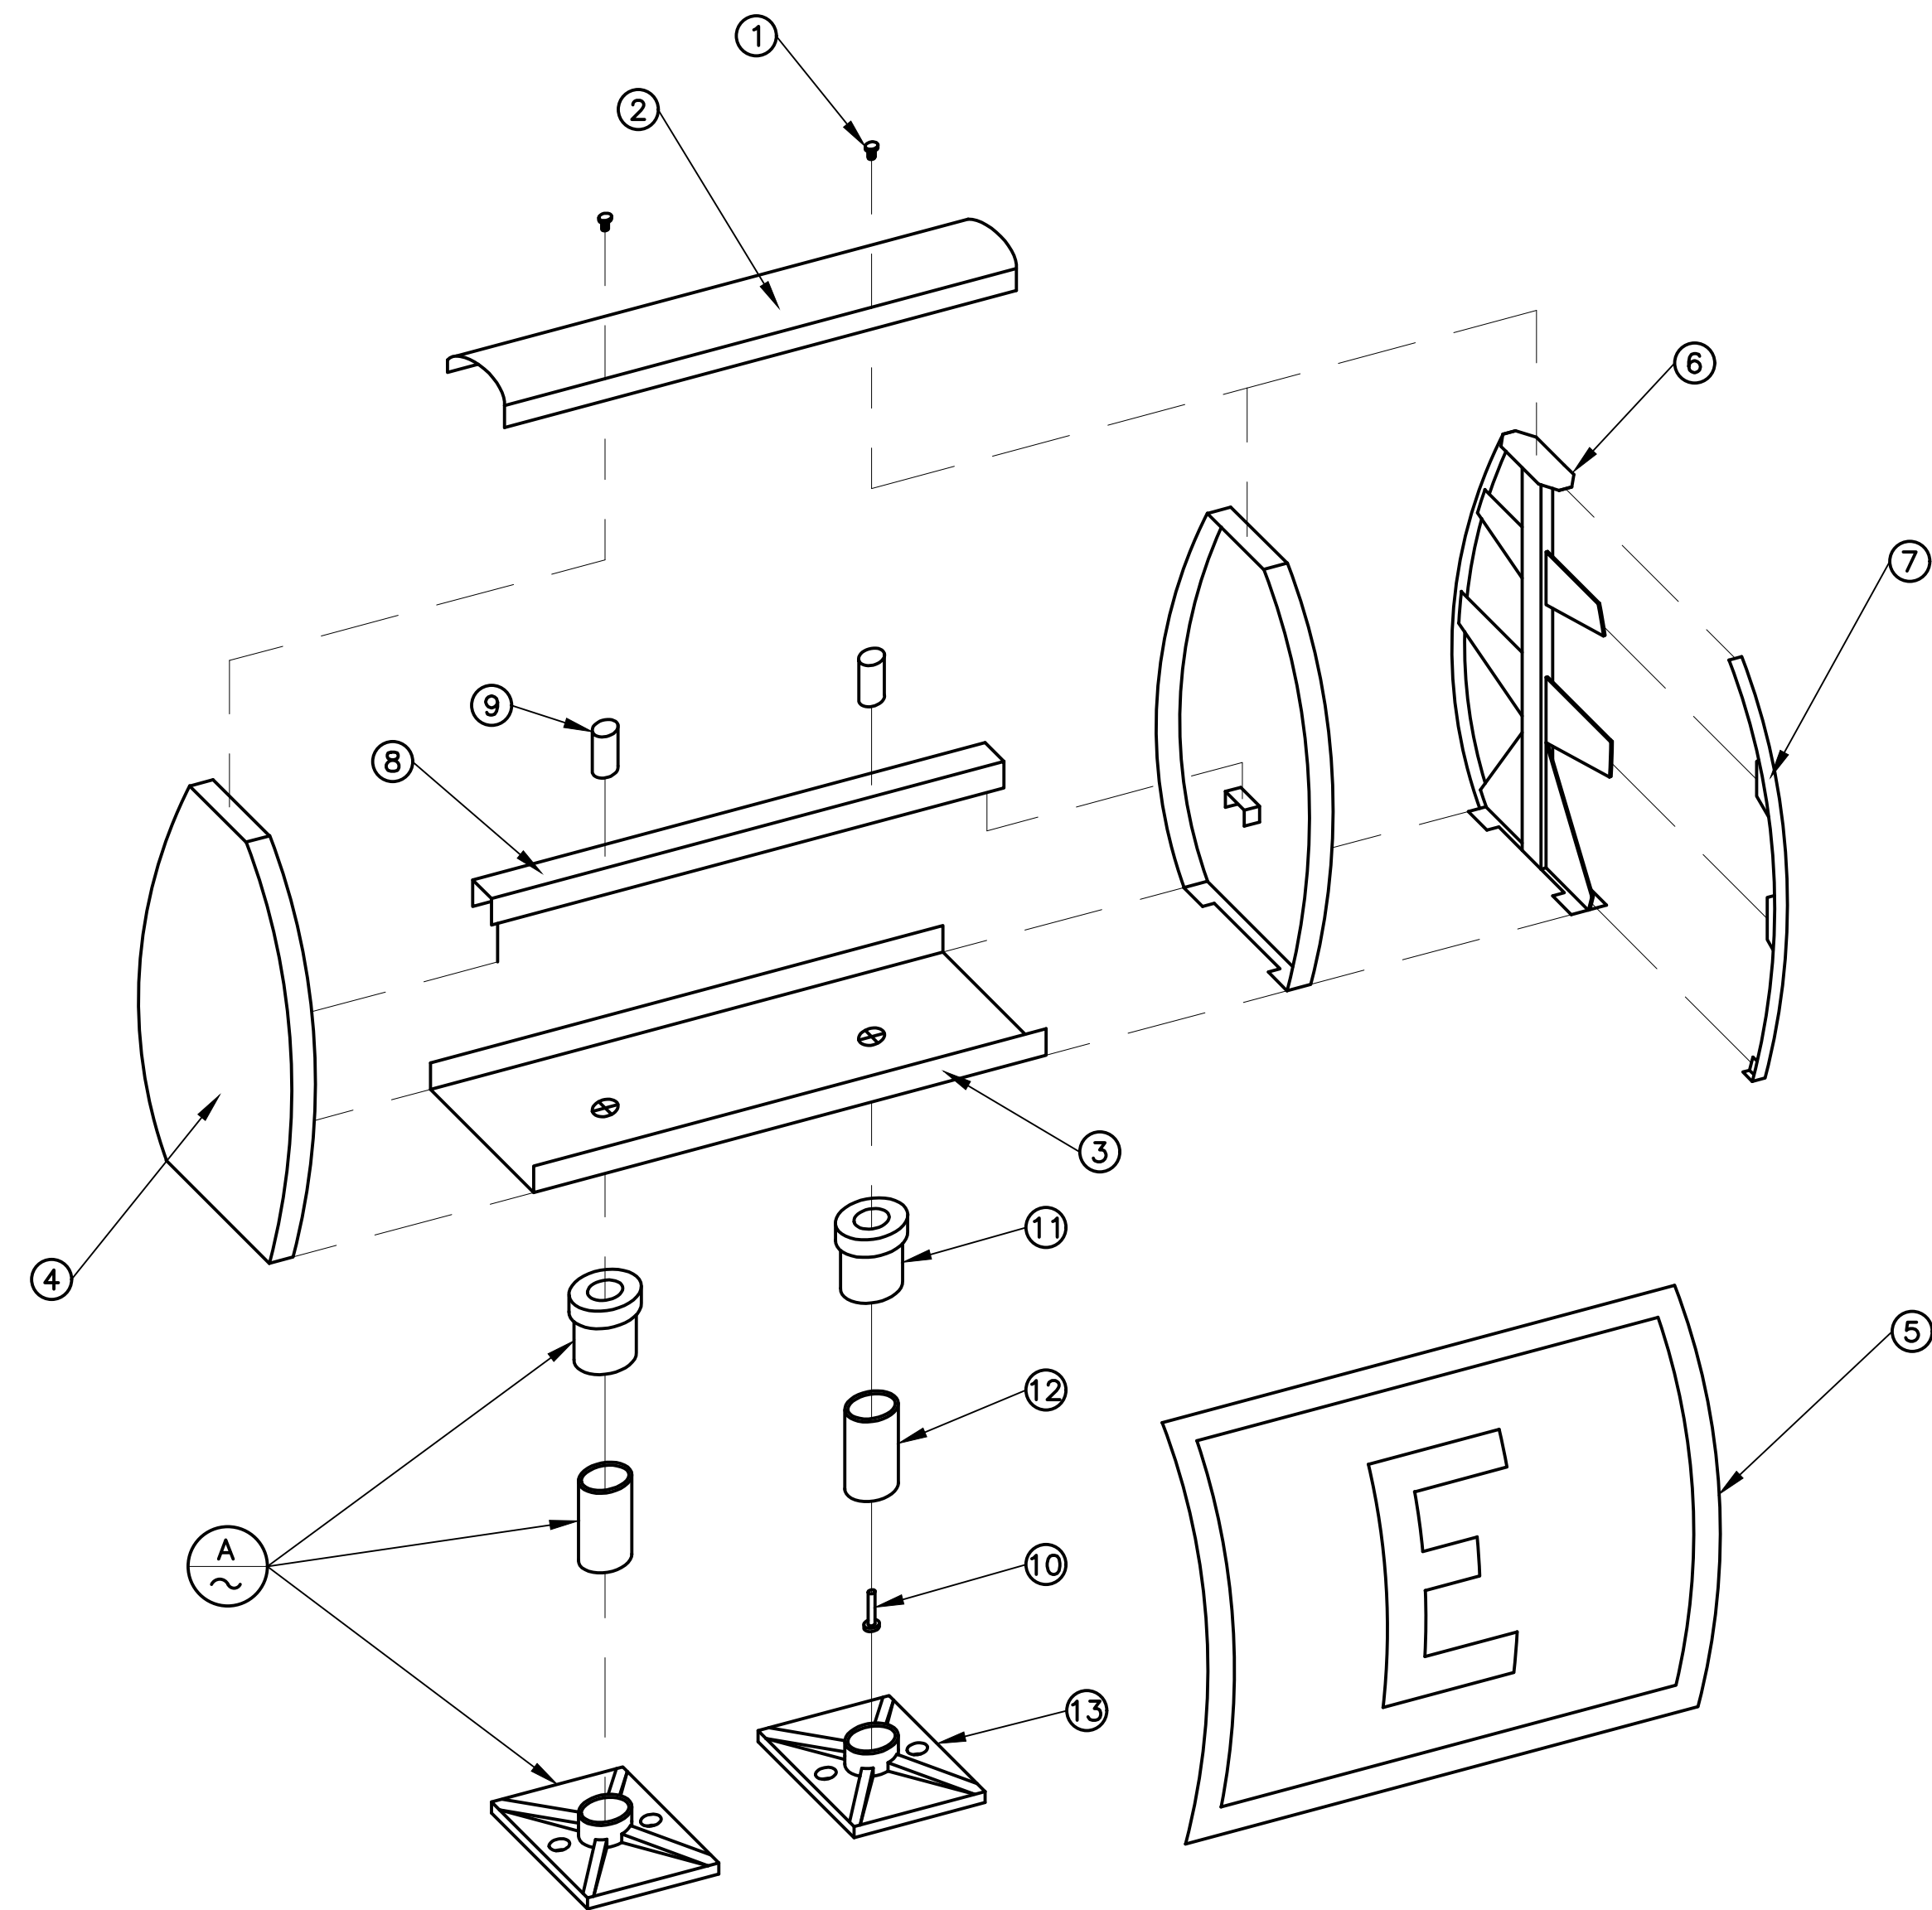


1. TURN FASTENERS
2. TOP COVER (SEE NOTE 4)
3. BASE (SIGN BOTTOM)
4. END PANEL (SEE NOTE 3)
5. LEGEND PANEL
6. SUPPORT JUNCTION
7. FACE INSERT PANEL JOINT
8. LAMP MOUNTING BAR
9. LAMP SOCKET
10. FAA L-823 PLUG
11. SLIP FLANGE
12. FRANGIBLE COUPLING (6" LENGTH)
13. FLOOR FLANGE

- NOTES:**
1. NEW AIRFIELD SIGNS SHALL BE OF A CURVED FACE DESIGN TO MAINTAIN SIMILAR APPEARANCE TO THAT OF EXISTING SIGNAGE AND TO FACILITATE ARRAY MODIFICATIONS.
2. WHEN JOINING TWO (2) SIGNS FOR ONE ARRAY, PROVIDE NEW SIZE 1 SUPPORT JUNCTION (TREE) AND SIZE 2 FACE INSERT PANEL JOINT (TRACK) OF THE CORRECT COLOR ADDED. DO NOT PROVIDE END PANELS IN THE MIDDLE OF THE ARRAY.
3. PROVIDE EXTERNAL DISCONNECT SWITCH IN WEATHERPROOF ENCLOSURE.
4. PROVIDE CURVED SIGN TOPS THAT PROVIDE ADDITIONAL SIGN PANEL SUPPORT IF AVAILABLE BY MANUFACTURER.

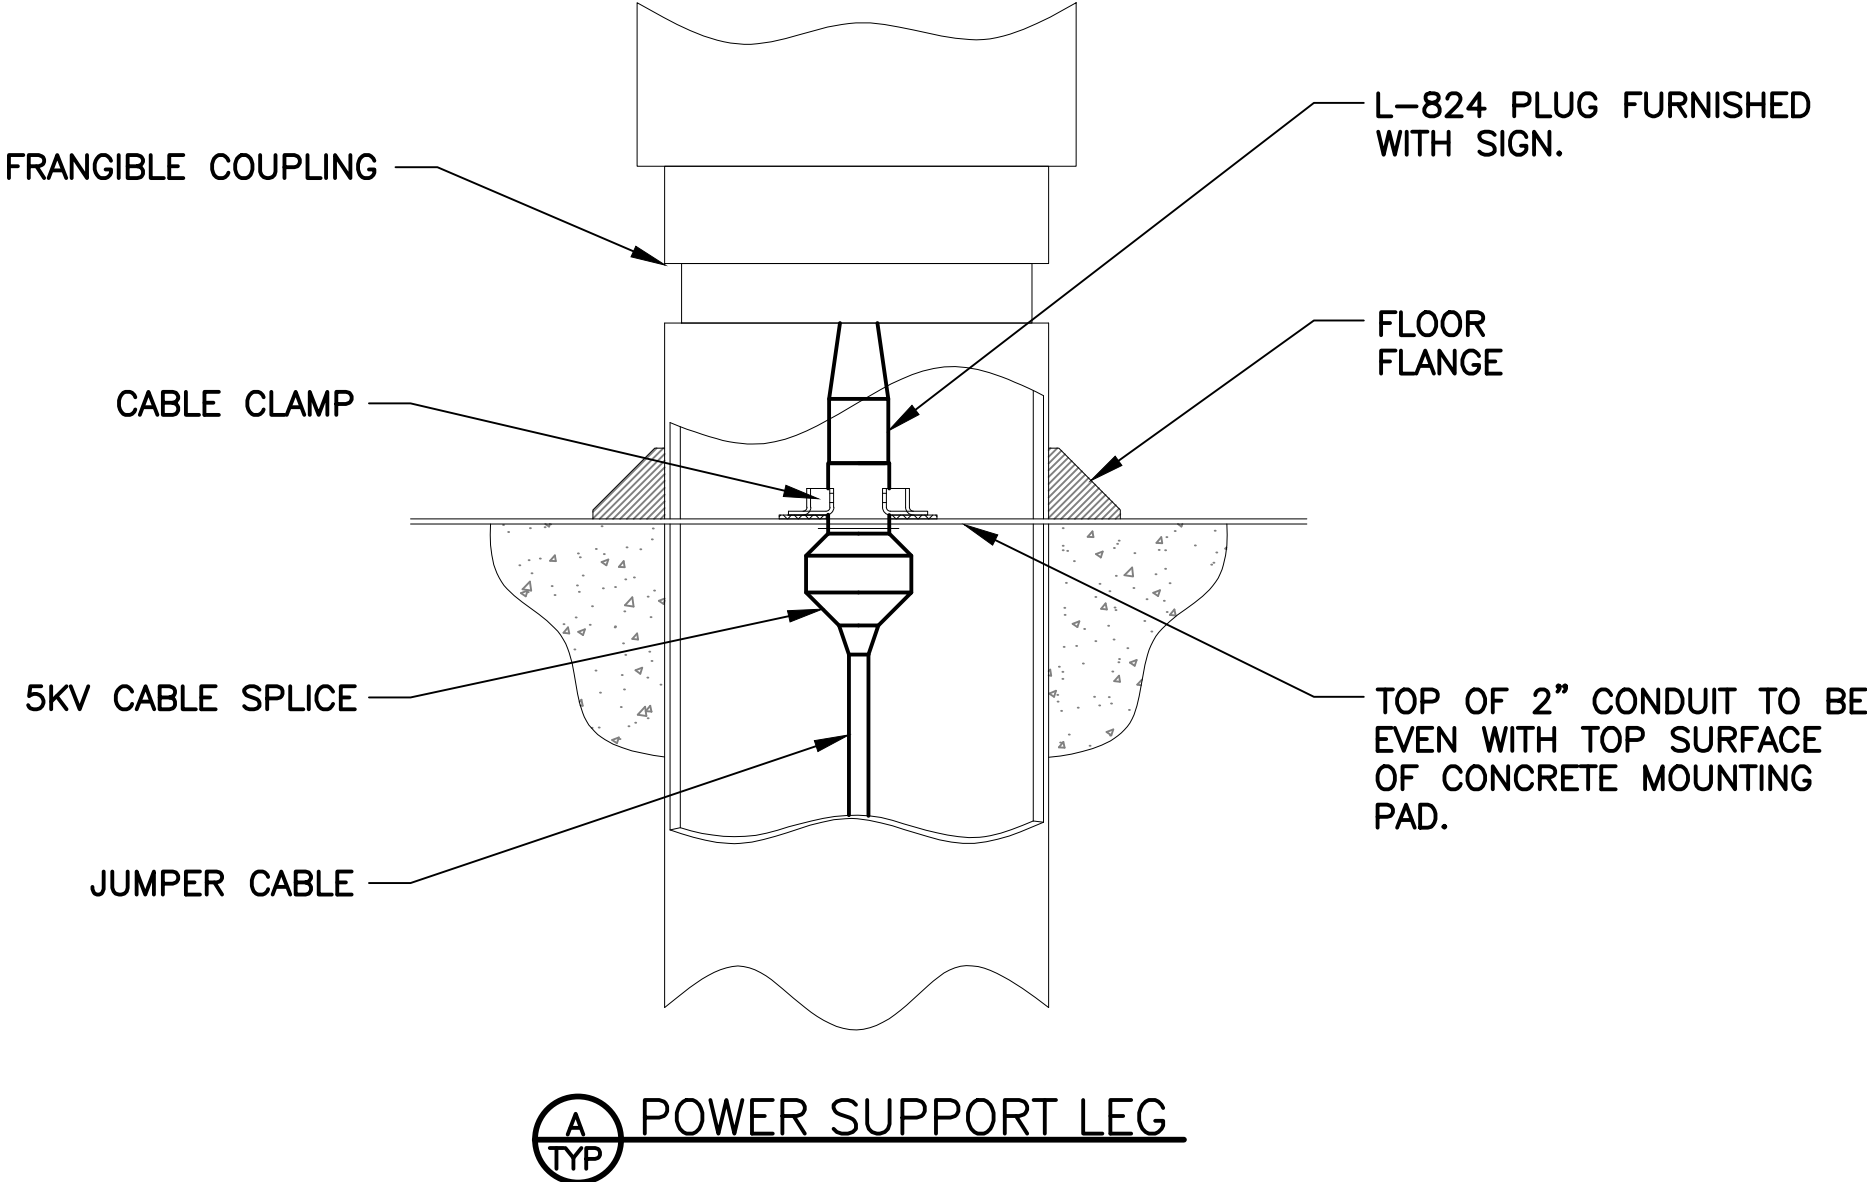

CRengineers
16719 East Palisades Blvd., Suite 202
Fountain Hills, AZ 85268
Phone: (480) 816-5541
Fax: (480) 816-5540

PER CITY OF PHOENIX CODE CHAPTER 2, SECTION 2-28. THESE PLANS ARE FOR OFFICIAL USE ONLY AND MAY NOT BE SHARED WITH OTHERS EXCEPT AS REQUIRED TO FULFILL THE OBLIGATIONS OF CONTRACTOR'S CONTRACT WITH THE CITY OF PHOENIX.

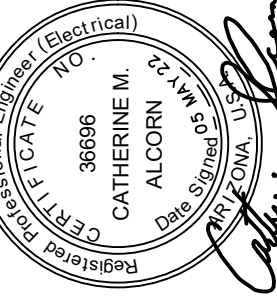

REGISTERED PROFESSIONAL ENGINEER (Electrical)
39696
CATHERINE M. ALCORN
DESIGN
PHOENIX, AZ 85004

NO.	REVISIONS / SUBMISSIONS	DATE



CITY OF PHOENIX AVIATION DEPARTMENT
PHOENIX GOODYEAR AIRPORT
NEW APRON AND TAXIWAY CONNECTOR

AV41000077 FAA/ADOT

CIP NO.(S): AV41000077 FAA/ADOT

Designed by: SW
Drawn by: JBW
Checked by: CA
Date: May 2022
Dwg scale:

Sheet Overview Title


AIRFIELD GUIDANCE SIGN
DETAILS

Sheet Reference Number:

EA-507

Sheet 58 of 61

EXISTING COPPER CONDUCTOR/CONDUIT SCHEDULE	
3.55	3-#6, #10 GND, 1"C (EXISTING)
4.55	4-#6, #10 GND, 1"C (EXISTING)
4.70	2-#4, #10 GND, 1 1/4"C - PER NEC 10'-0" TAP RULE (EXISTING)
3.95	3-#2, #2 NEUTRAL, #8 GND, 1 1/2"C (EXISTING)
3.230	3-4/0, #4 GND, 2"C (NEW)
3.255	2 SETS OF THE FOLLOWING-3-250 KCMIL, 250 KCMIL NEUTRAL, 1/0 GND, 3"C (EXISTING)

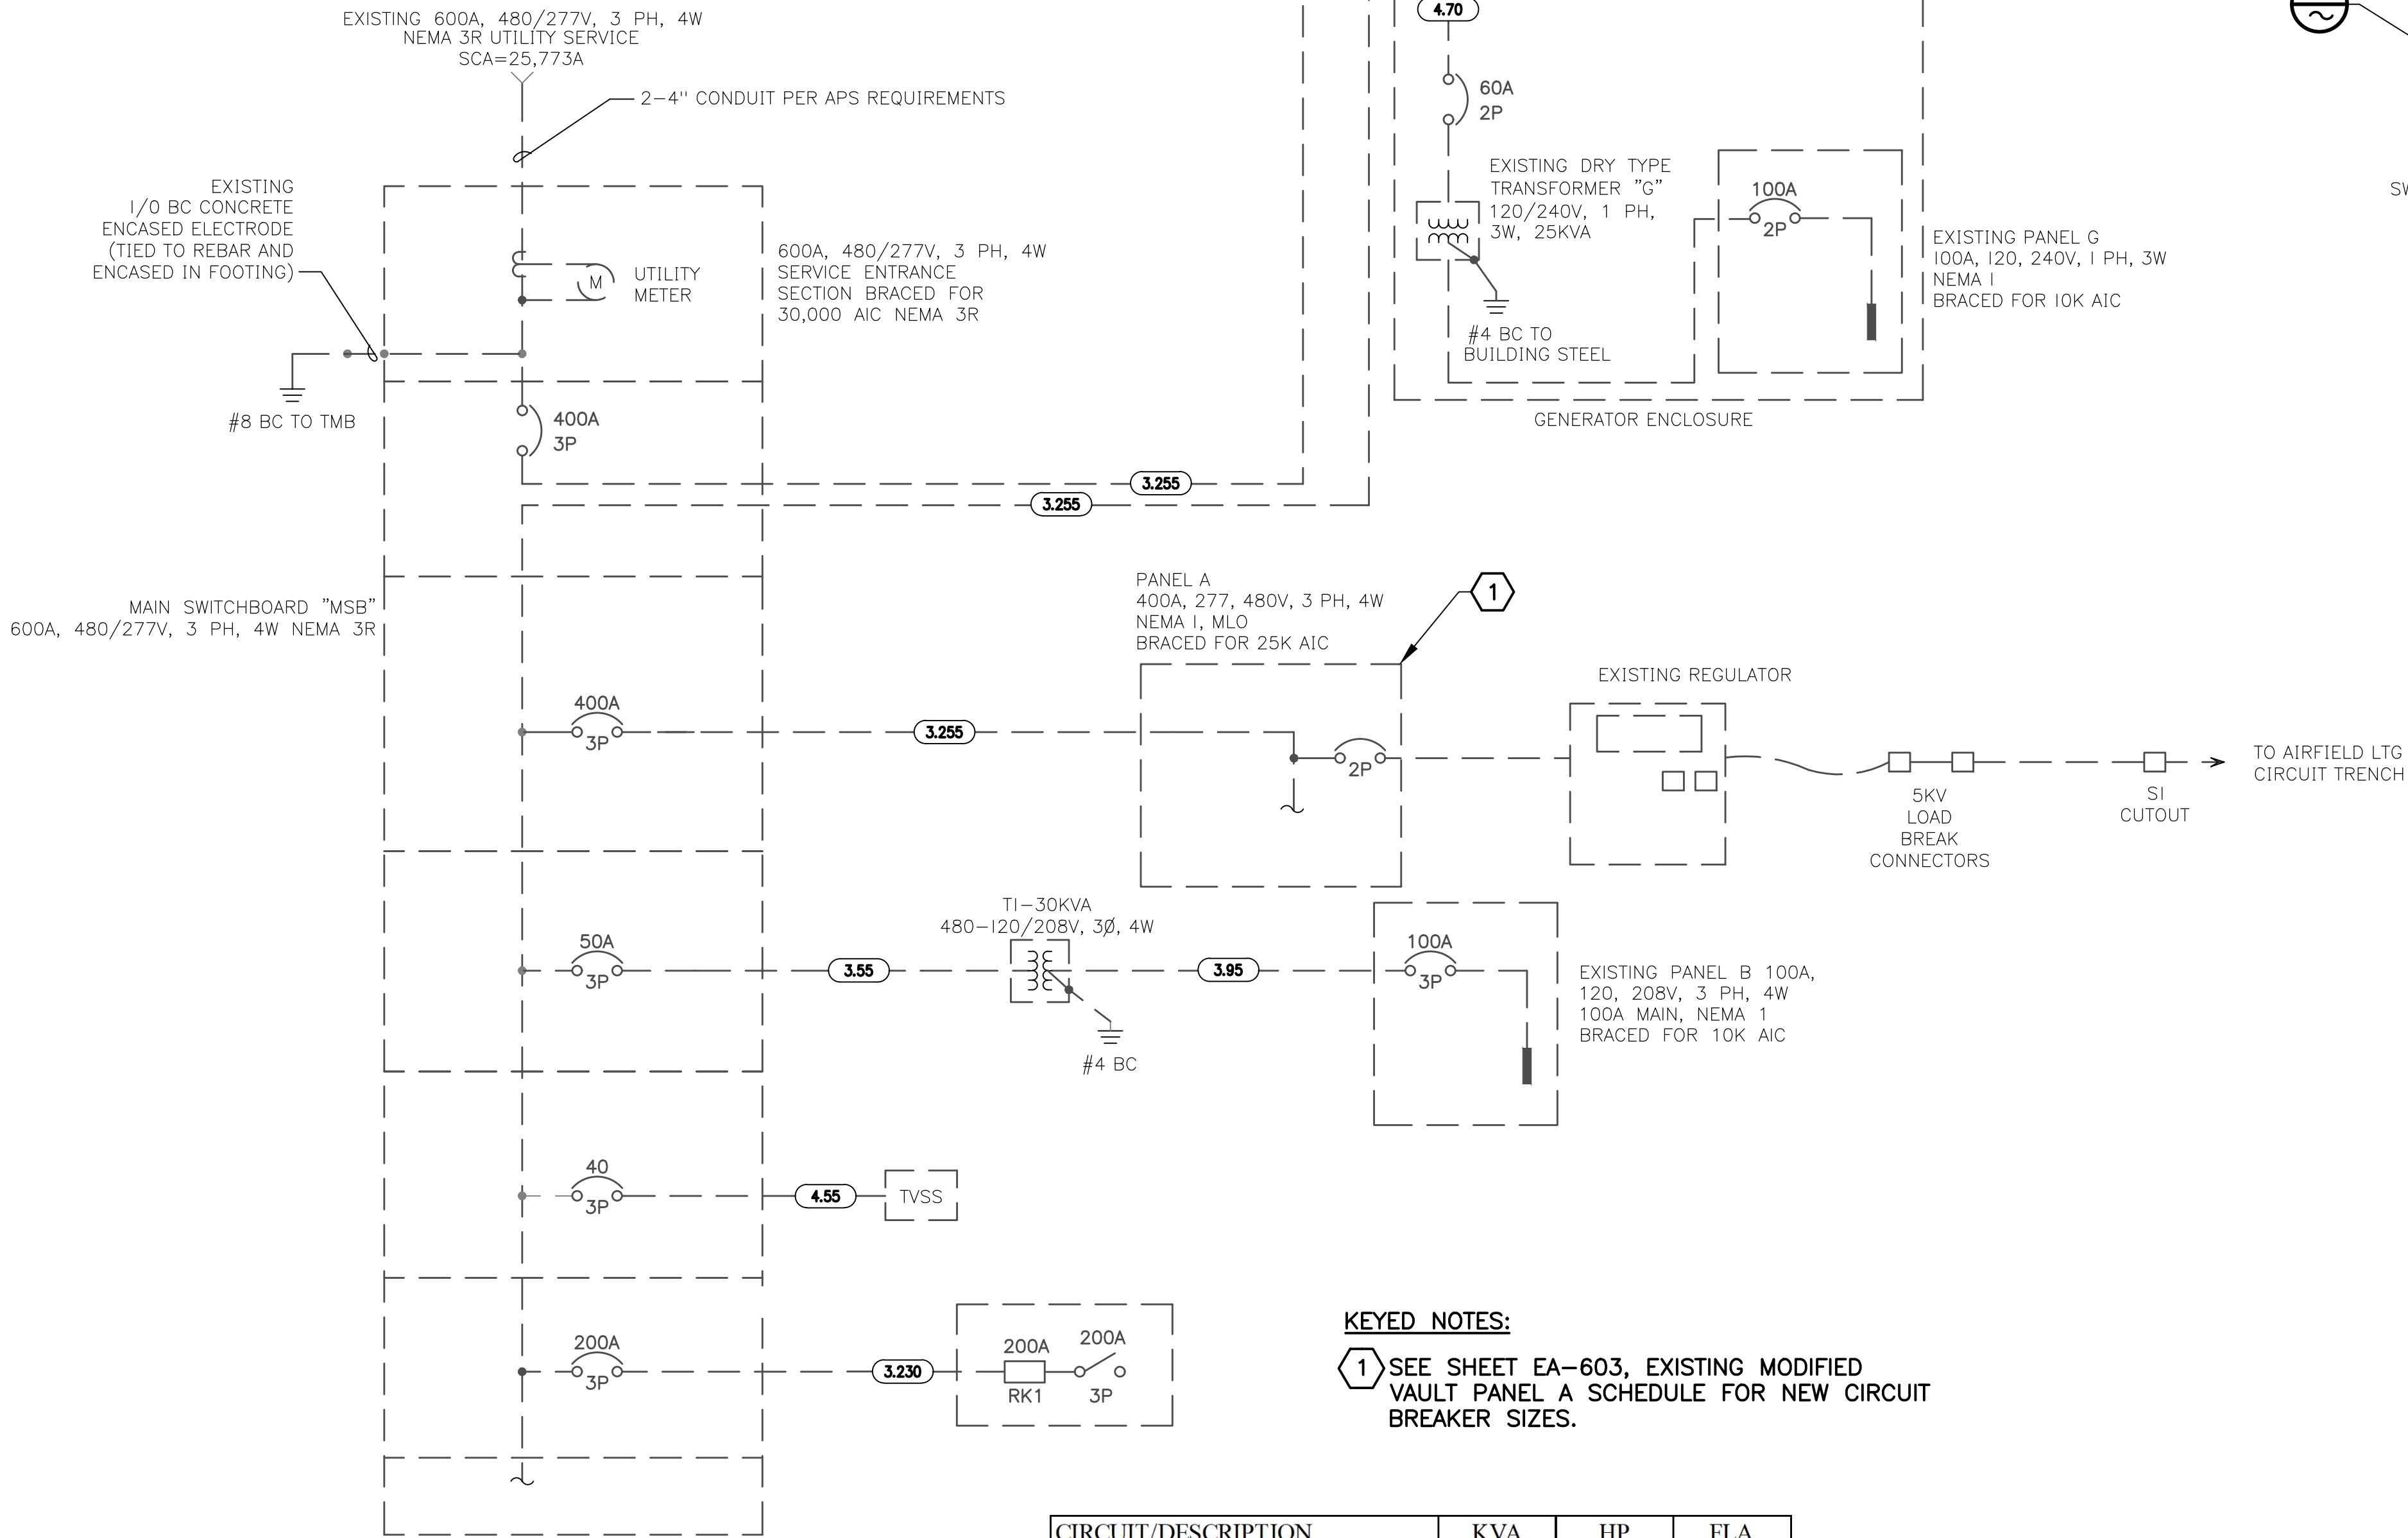


A SINGLE LINE DIAGRAM SES AT VAULT
(BID ALT #1)

CIRCUIT/DESCRIPTION	KVA	HP	FLA
Panel A (Modified Loads)	28.6		103.3
Existing Panel B	4.3		9.0
Existing Panel G	5.2		10.8
SUBTOTAL			123.1
+ 25% OF LARGEST MOTOR			0.0
TOTAL AMPS @ 480V/3PHASE			123.1
EXISTING SERVICE SIZE (AMPS)			600.0

B LOAD CALCULATIONS SES AT VAULT
(BID ALT #1)

KEYED NOTES:

- 1 SEE SHEET EA-603, EXISTING MODIFIED VAULT PANEL A SCHEDULE FOR NEW CIRCUIT BREAKER SIZES.

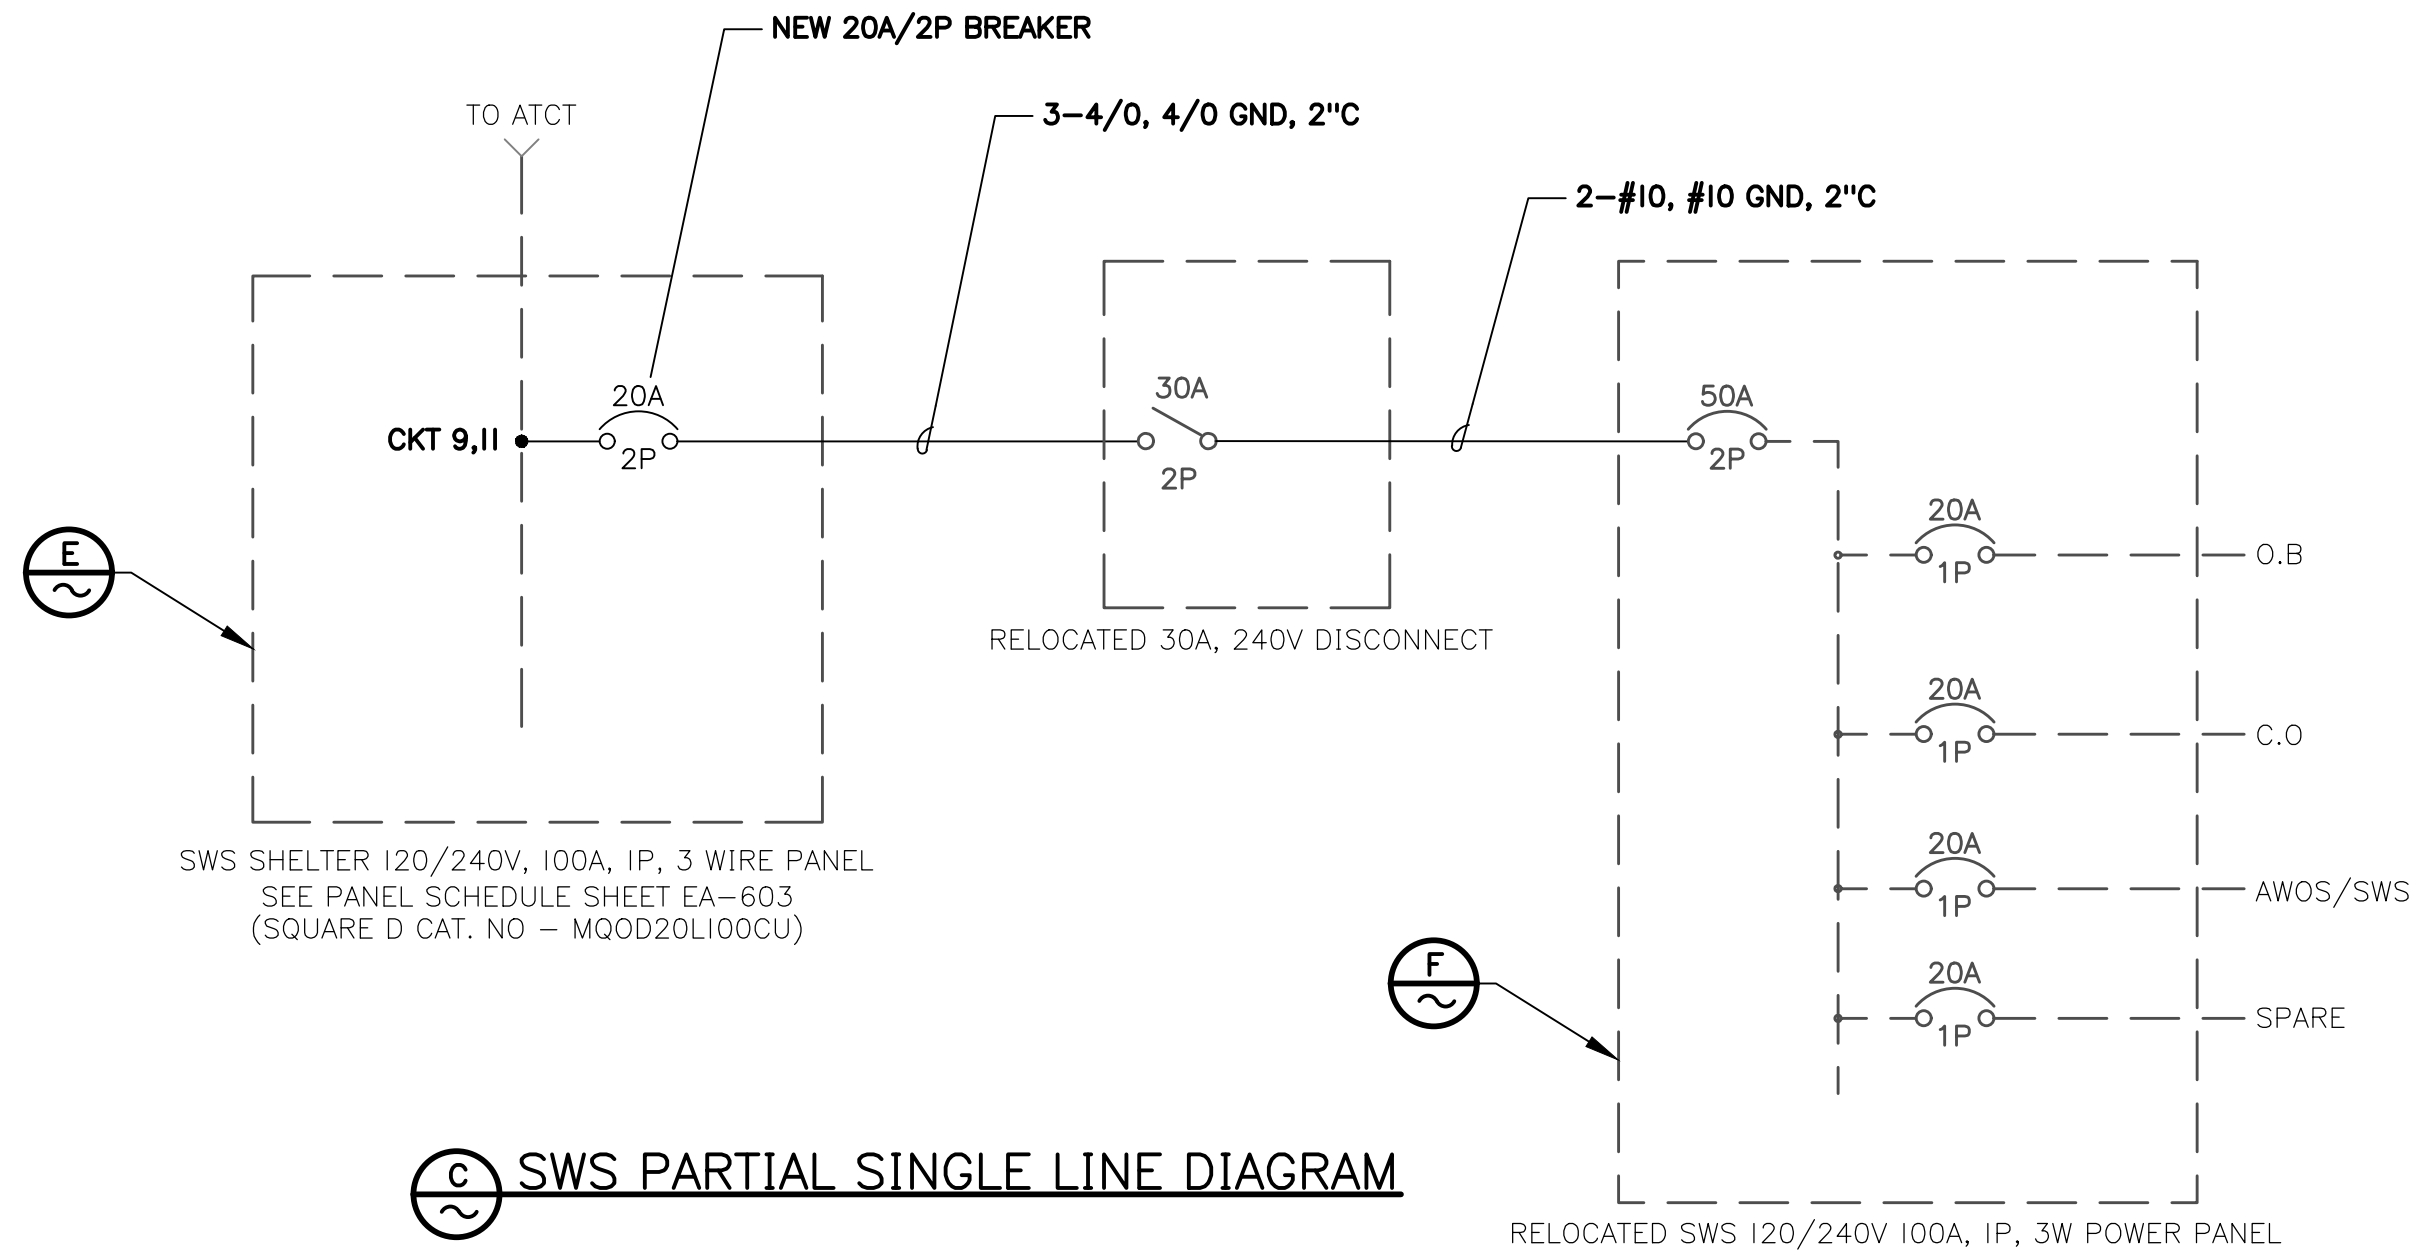


C SWS PARTIAL SINGLE LINE DIAGRAM

CIRCUIT/DESCRIPTION	KVA	HP	FLA
EXISTING PEAK DEMAND	22.9		110.0
METER #AW8212			
FUTURE ASOS	6.9		33.2
SUBTOTAL			143.2
+ 25% OF LARGEST MOTOR			0.0
TOTAL AMPS @ 208V/3PHASE			143.2
EXISTING SERVICE SIZE (AMPS)			400.0


D LOAD CALCULATIONS SES AT ATCT



E EXISTING SWS PANEL AND SCHEDULE

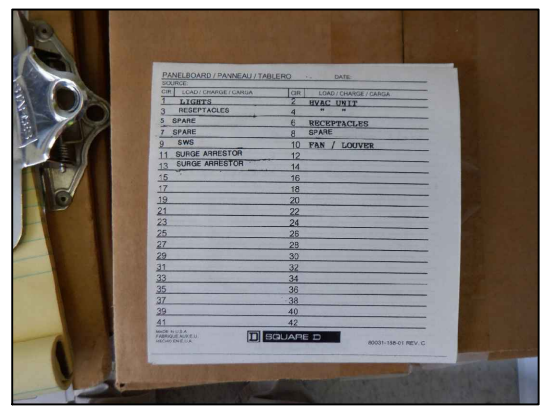

F EXISTING SWS POWER PANEL

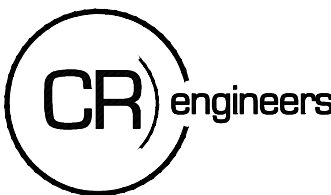

16719 East Palisades Blvd., Suite 202
Fountain Hills, AZ 85268
Phone: (480) 816-5541
Fax: (480) 816-5540


PER CITY OF PHOENIX CODE CHAPTER 2, SECTION 2-28. THESE PLANS ARE FOR OFFICIAL USE ONLY AND MAY NOT BE SHARED WITH OTHERS EXCEPT AS REQUIRED TO FULFILL THE OBLIGATIONS OF CONTRACTOR'S CONTRACT WITH THE CITY OF PHOENIX.

NO.	REVISIONS / SUBMISSIONS	DATE

Designed by: SW	Drawn by: JBW
Checked by: CA	Date: May 2022
Dwg scale:	

PANEL: A		VOLTAGE: 480/277V		MAIN CB: MLO		BUS AMPS: 400A	
CB TYPE: BOLT-ON		MOUNTING: SURFACE		BRACING: 25K AIC		BKR AIC: 25K	
CIRCUIT DESCRIPTION	BKR	CIRCUIT	PHASE A	PHASE B	PHASE C	CIRCUIT	BKR
7.5KW CCR (R/W 3-21)	30	1	2000				
	/					2	40
	2	3		2000			/
						4	2
10KW CCR (T/W A SOUTH)	40	5			4166		
	/					6	40
	2	7	4166				/
						8	2
7.5KW CCR (SIGNS)	30	9		2277			
	/			1666		10	30
	2	11			2277		/
					1666	12	2
SPARE (FUTURE CCR)	50	13					
	/					14	50
	2	15					/
						16	2
SPARE (FUTURE CCR)	50	17					
	/				551	18	20 / 1
	2	19					/
			180			20	20 / 1
SPARE (FUTURE CCR)	50	21					
	/			5218		22	25
	2	23					/
					5218	24	
SPACE		25					
			5218			26	3
HP-2	25	27		5218			
	/			600		28	20
		29			5218		/
					600	30	2
	3	31	5218				
			800			32	20
REILS SOUTH	20	33		600			/
	/			800		34	2
	2	35			600		
					800	36	20
SPACE		37					/
			800			38	2
4KW CCR RUNWAY GUARD LIGHTS (RGLs)	15	39		1500			
	/			1335		40	20
	2	41			1500		/
					1335	42	2
CONNECTED KVA PER PHASE			18.4	21.2	23.9	NOTES: PROVIDE BREAKER TYPE HED4	
CONNECTED AMPS PER PHASE			66.4	76.6	86.4	SIEMENS SENTRON SERIES; 25K AIC RATED MINIMUM	
25% OF CONTINUOUS & LIGHTING LOAD (KVA)			2.0	2.7	3.4	AT 480VAC	
LARGEST MOTOR (25%)							
CODE KVA PER PHASE			21.7	25.2	28.6		
CODE AMPS PER PHASE AT 277V			78.2	91.0	103.3		

A EXISTING PANEL A SCHEDULE (LOCATED IN VAULT)
(BID ALT #1)

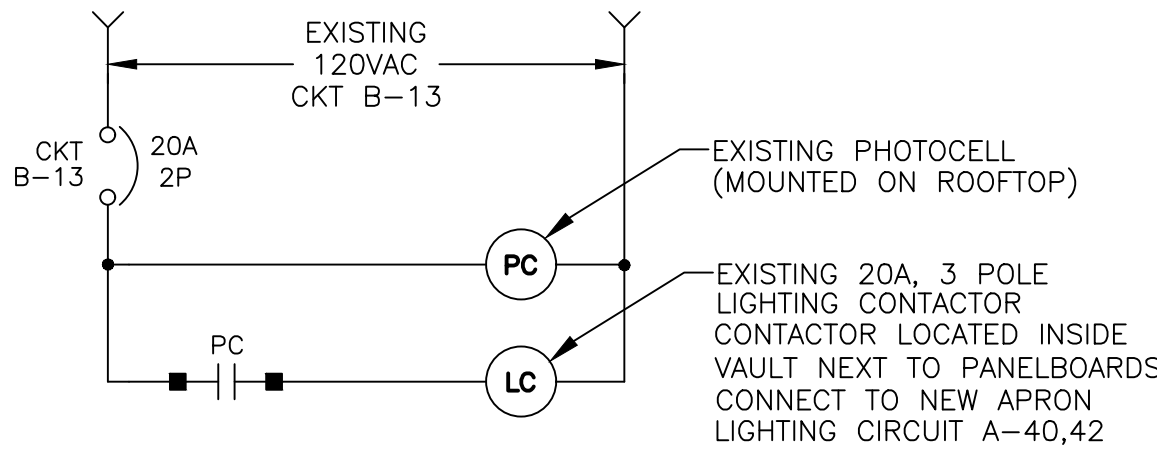

B EXISTING LIGHTING CONTROL SCHEMATIC
(BID ALT #1)


(SEE NOTES 1 AND 2)

PANEL: SWS		VOLTAGE: 120/240		MAIN CB: 100A		BUS AMPS: 100A	
CB TYPE: BOLT-ON		MOUNTING: SURFACE		BRACING: 10,000		BKR AIC: 10,000	
CIRCUIT DESCRIPTION	BKR	CIRCUIT	LINE 1	LINE 2	CIRCUIT	BKR	CIRCUIT DESCRIPTION
LIGHTS	20/1	1			2	20	HVAC UNIT
RECEPTACLES	20/1	3			4	2	
SPARE	20/1	5			6	20/1	RECEPTACLES
SPARE	20/1	7			8	20/1	SPARE
RELOCATED SWS	20	9			10	20/1	FAN/LOUVER
	2	11			12		
SURGE ARRESTOR	20	13			14		
	2	15			16		
		17			18		
		19			20		
CONNECTED KVA PER PHASE			0.0	0.0	NOTES: NEW INDICATED IN RED		
CONNECTED AMPS PER PHASE			0.0	0.0	NEW BREAKERS TO MATCH EXISTING IN BRACING AND TYPE		
25% OF CONTINUOUS & LIGHTING LOAD (KVA)			0.0	0.0			
LARGEST MOTOR (25%)			0.0	0.0			
CODE KVA PER PHASE			0.0	0.0			
CODE AMPS PER PHASE AT 120V			0.0	0.0			

A EXISTING PANEL SWS SCHEDULE



NOTES:

- EXISTING SURGE ARRESTOR IS LOCATED ON CIRCUITS 11-13. 20A/2P BREAKER TO BE RELOCATED TO CIRCUIT 13-15.
- EXISTING SWS ON A 20/1P BREAKER ON CIRCUIT 9. TO BE REPLACED WITH A 20A/2P BREAKER AND PLACED ON CIRCUIT 9-11.
- NO NEW LOADS ADDED TO PANEL SWS.

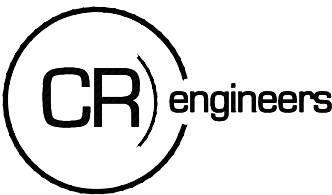

16719 East Palisades Blvd., Suite 202
Fountain Hills, AZ 85268
Phone: (480) 816-5541
Fax: (480) 816-5540

PER CITY OF PHOENIX CODE CHAPTER 2, SECTION 2-28. THESE PLANS ARE FOR OFFICIAL USE ONLY AND MAY NOT BE SHARED WITH OTHERS EXCEPT AS REQUIRED TO FULFILL THE OBLIGATIONS OF CONTRACTOR'S CONTRACT WITH THE CITY OF PHOENIX.

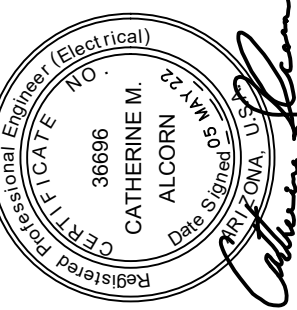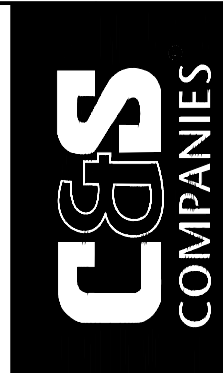

PER CITY OF PHOENIX CITY CODE CHAPTER 2, SECTION 2-28, THESE PLANS ARE FOR OFFICIAL USE ONLY AND MAY NOT BE SHARED WITH OTHERS EXCEPT AS REQUIRED TO FULFILL THE OBLIGATIONS OF YOUR CONTRACT WITH THE CITY OF PHOENIX.				NO.		REVISIONS / SUBMISSIONS		DATE



CITY OF PHOENIX AVIATION DEPARTMENT
PHOENIX GOODYEAR AIRPORT
NEW APRON AND TAXIWAY CONNECTOR

AV41000077 FAA/ADOT

Designed by: SW	Drawn by: JBW
Checked by: CA	Date: May 2022
Dwg scale:	

CIP NO.(S): AV41000077 FAA/ADOT

Sheet Overview Title	PANEL SCHEDULE AND LIGHTING CONTROL SCHEMATIC
----------------------	--

Sheet Reference Number:

EA-603